



KARACHI NEIGHBORHOOD IMPROVEMENT PROJECT (KNIP)

REHABILITATION & UPGRADATION OF BOAT BASIN TO SCHON CHOWRANGI WITH PEDESTRIAN TRAIL & GIZRI SPORTS GROUND


ELECTRICAL TENDER DRAWINGS

VOL-III
AUGUST - 2021



G3 ENGINEERING CONSULTANTS (PVT.) LTD.

Consulting Engineers – Architects – Planners

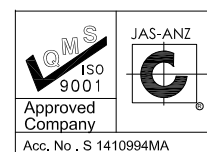

JAS-ANZ

ISO 2000-9001

CERTIFIED

COMPANY


LIST OF DRAWINGS
ELECTRICAL DRAWINGS

S.NO	DRAWING DETAIL	DRAWING NO.
1.	LIST OF DRAWING	0249/FS/00
2.	MAIN LEGENDS	0249/ML/01
3.	FOOD STREET POWER DISTRIBUTION LAYOUT	0249/FS/02
4.	FOOD STREET LIGHTING LAYOUT	0249/FS/03
5.	PEDESTRIAN TRAIL ELECTRICAL LAYOUT	0249/PT/04
6.	PEDESTRIAN TRAIL BRIDGE LIGHTING PLAN	0249/PT/05
7.	FOOD STREET SERVICE DUCT LAYOUT PLAN	0249/FS/06
8.	FOOD STREET POWER DISTRIBUTION SYSTEM DETAIL	0249/FS/07
9.	TOILET BLOCK FOOD STREET ILLUMINATION LAYOUT PLAN	0249/FS/TB/07A
10.	ST-5 ILLUMINATION LAYOUT PLAN	0249/PARKS/08
11.	ST-5 POWER DISTRIBUTION LAYOUT PLAN	0249/PARKS/09
12.	ST-5 CCTV LAYOUT PLAN	0249/PARKS/10
13.	ST-5 PUBLIC ADDRESS SYSTEM LAYOUT PLAN	0249/PARKS/11
14.	ST-06 ILLUMINATION LAYOUT PLAN	0249/PARKS/12
15.	ST-06 POWER DISTRIBUTION LAYOUT PLAN	0249/PARKS/13
16.	ST-06 CCTV LAYOUT PLAN	0249/PARKS/14
17.	ST-06 PUBLIC ADDRESS SYSTEM LAYOUT PLAN	0249/PARKS/15
18.	ST-06 (LIBRARY BLOCK) ILLUMINATION LAYOUT PLAN	0249/PARKS/16
19.	ST-08 ILLUMINATION LAYOUT PLAN	0249/PARKS/17
20.	ST-08 POWER DISTRIBUTION LAYOUT PLAN	0249/PARKS/18
21.	ST-08 CCTV LAYOUT PLAN	0249/PARKS/19
22.	ST-08 PUBLIC ADDRESS SYSTEM LAYOUT PLAN	0249/PARKS/20
23.	ST-09 ILLUMINATION LAYOUT PLAN	0249/PARKS/21
24.	ST-09 POWER DISTRIBUTION LAYOUT PLAN	0249/PARKS/22
25.	ST-09 CCTV LAYOUT PLAN	0249/PARKS/23
26.	ST-09 PUBLIC ADDRESS SYSTEM LAYOUT PLAN	0249/PARKS/24
27.	ST-09 (CANTEEN) ILLUMINATION LAYOUT PLAN	0249/PARKS/25
28.	TOILET BLOCK- PARKS ILLUMINATION LAYOUT PLAN	0249/PARKS/TB/26
29.	GUARD ROOMS PARKS ILLUMINATION LAYOUT	0249/PARKS/GD/27
30.	LIGHTING DETAILS	0249/PARKS/28
31.	SERVICE ROAD ILLUMINATION AND POWER DISTRIBUTION LAYOUT	0249/SR/29
32.	SINGLE LINE DIAGRAM LAYOUT	0249/SR/30
33.	SINGLE LINE DIAGRAM (ST-05)	0249/SLD/031
34.	SINGLE LINE DIAGRAM (ST-06)	0249/SLD/032
35.	SINGLE LINE DIAGRAM (ST-08)	0249/SLD/033
36.	SINGLE LINE DIAGRAM (ST-09)	0249/SLD/034
37.	SINGLE LINE DIAGRAM (FOOD STREET)	0249/SLD/035
38.	SINGLE LINE DIAGRAM (PEDESTRIAN TRAIL)	0249/SLD/036

CLIENT:



 PROJECT
IMPLEMENTATION
UNIT (PIU) KNIP



CONSULTANTS:

**G3 ENGINEERING
CONSULTANTS (PVT)LTD.**
House No.57-M Gulberg-II, Lahore, Pakistan

Tel : (92-42) 35441641, 35441642
Fax : (92-42) 35441645
E-mail : info@g3ec.com
URL : www.g3ec.com

PROJECT:

REHABILITATION & UP GRADATION OF
BOAT BASIN TO SCHON CHOWRANGI
WITH PEDESTRIAN TRAIL

NOTES:

1. ALL DIMENSIONS ARE IN FEET UNLESS OTHERWISE SPECIFIED.
2. THIS DRAWING IS AN INTELLECTUAL PROPERTY OF G3 ENGINEERING CONSULTANTS (PVT.) LTD. AND CANNOT BE REPRINTED OR REPRODUCED WITHOUT PRIOR APPROVAL OF G3.

REVISIONS:

No.	DESCRIPTION	DATE

TENDER DRAWINGS

DRAWING TITLE:

LIST OF DRAWINGS

DRAWN BY: Engr. M.RAFFEH	DATE: Aug 2021
ELECTRICAL ENGINEER: Engr. Ghulam Daraz Shaikh	
APPROVED BY: SAYED ALI ABBAS GILLANI	
DRAWING NO: 0249/FS/00	REV: 4
SCALE (A3): N.T.S	SHEET: 1/16


LIGHT FIXTURES

S.NO	SYMBOLS	DESCRIPTION
1		POST TOP LED LIGHT
2		ARCHITECTURAL POLE
3		SINGLE ARM POLE
4		DOUBLE ARM POLE
5		OUTDOOR GARDEN SPIKE LIGHT
6		LED FLOOD LIGHT 100 WATT
7		DOWN LIGHT FIXTURE WITH 10WATT SMD LAMP
8		LED BOLLARD LIGHT
9		
10		WATER TIGHT WALL BRACKET LIGHT


WIRING ACCESSORIES

S.NO	SYMBOLS	DESCRIPTION	MOUNTING HEIGHT
1		10 AMPS, ONE WAY AND TWO WAYS GANG TYPE SWITCH NUMBER OF SWITCHES ON SWITCH PLATE	3'-6" F.F.L
2		5 AMPS 3-PIN COMBINED SWITCH SOCKET	0'-9" F.F.L
3		5 AMPS 3-PIN COMBINED SWITCH SOCKET	3'-6" F.F.L
4		3 PIN FLAT SWITCH SOCKET 13 AMPS,	0'-9" F.F.L
5		15 AMPS 3-ROUND PIN SWITCH SOCKET	0'-9" F.F.L
6		15 AMPS 3-ROUND PIN SWITCH SOCKET	3'-6" F.F.L
7		WIRING IN 3/4" OR 1" DIA PVC CONDUIT	-IN WALL/ -BUF/BUG/ BIS
8		MEDICAL EQUIPMENT PANEL BOARD	4'-0" F.F.L OR AS REQ.
9		DISTRIBUTION BOARD FOR LIGHTING CIRCUIT & SMALL POWER	4'-0" F.F.L OR AS REQ.

 CLOSE CIRCUIT T.V SYSTEM

S.NO	SYMBOLS	DESCRIPTION	MOUNTING HEIGHT
1		MONITOR	AS PER SITE
2		CLOSE CIRCUIT TV CAMERA	-ON WALL 7'-0" -ON SLAB
3		CCTV JUNCTION BOX	6" TO 9" BELOW SLAB BUT ABOVE FALSE CEILING
4		WIRING IN 1"Ø PVCC FOR CCTV SYSTEM	ON SLAB/ BUG/BUF/BIS
5		NETWORK VIDEO RECORDER	AS PER SITE

 PUBLIC ADDRESS SYSTEM

S.NO	SYMBOLS	DESCRIPTION	MOUNTING HEIGHT
1		CIRCULAR TYPE LOUD SPEAKER	ON FALSE CEILING
		WALL SPEAKER	ON WALL
2		AMPLIFIER	RACK MOUNTED
3		PUBLIC ADDRESS JUNCTION BOX	4'-0" F.F.L OR AS REQ
4		WIRING IN 1"Ø PVCC FOR PUBLIC ADDRESS SYSTEM	BIS OR ON SLAB AFC

MAIN LEGEND

CLIENT:



PROJECT
IMPLEMENTATION
UNIT (PIU) KNIP



CONSULTANTS:

**G3 ENGINEERING
CONSULTANTS (PVT) LTD.**
House No.57-M Gulberg-III, Lahore, Pakistan



Tel : (92-42) 35441641, 35441642
Fax : (92-42) 35441645
E-mail : info@g3ec.com
URL : www.g3ec.com

PROJECT:

REHABILITATION & UP GRADATION OF
BOAT BASIN TO SCHON CHOWRANGI
WITH PEDESTRIAN TRAIL

NOTES:

- ALL DIMENSIONS ARE IN FEET UNLESS OTHERWISE SPECIFIED.
- THIS DRAWING IS AN INTELLECTUAL PROPERTY OF G3 ENGINEERING CONSULTANTS (PVT.) LTD. AND CANNOT BE REPRINTED OR REPRODUCED WITHOUT PRIOR APPROVAL OF G3.

REVISIONS:


No.	DESCRIPTION	DATE

TENDER DRAWINGS

DRAWING TITLE:

MAIN LEGENDS

DRAWN BY: Engr. M.RAFFEH	DATE: Aug 2021
ELECTRICAL ENGINEER: Engr. Ghulam Daraz Shaikh	
APPROVED BY: SAYED ALI ABBAS GILLANI	
DRAWING NO: 0249/ML/01	REV: 4
SCALE (A3): N.T.S	SHEET: 0/0

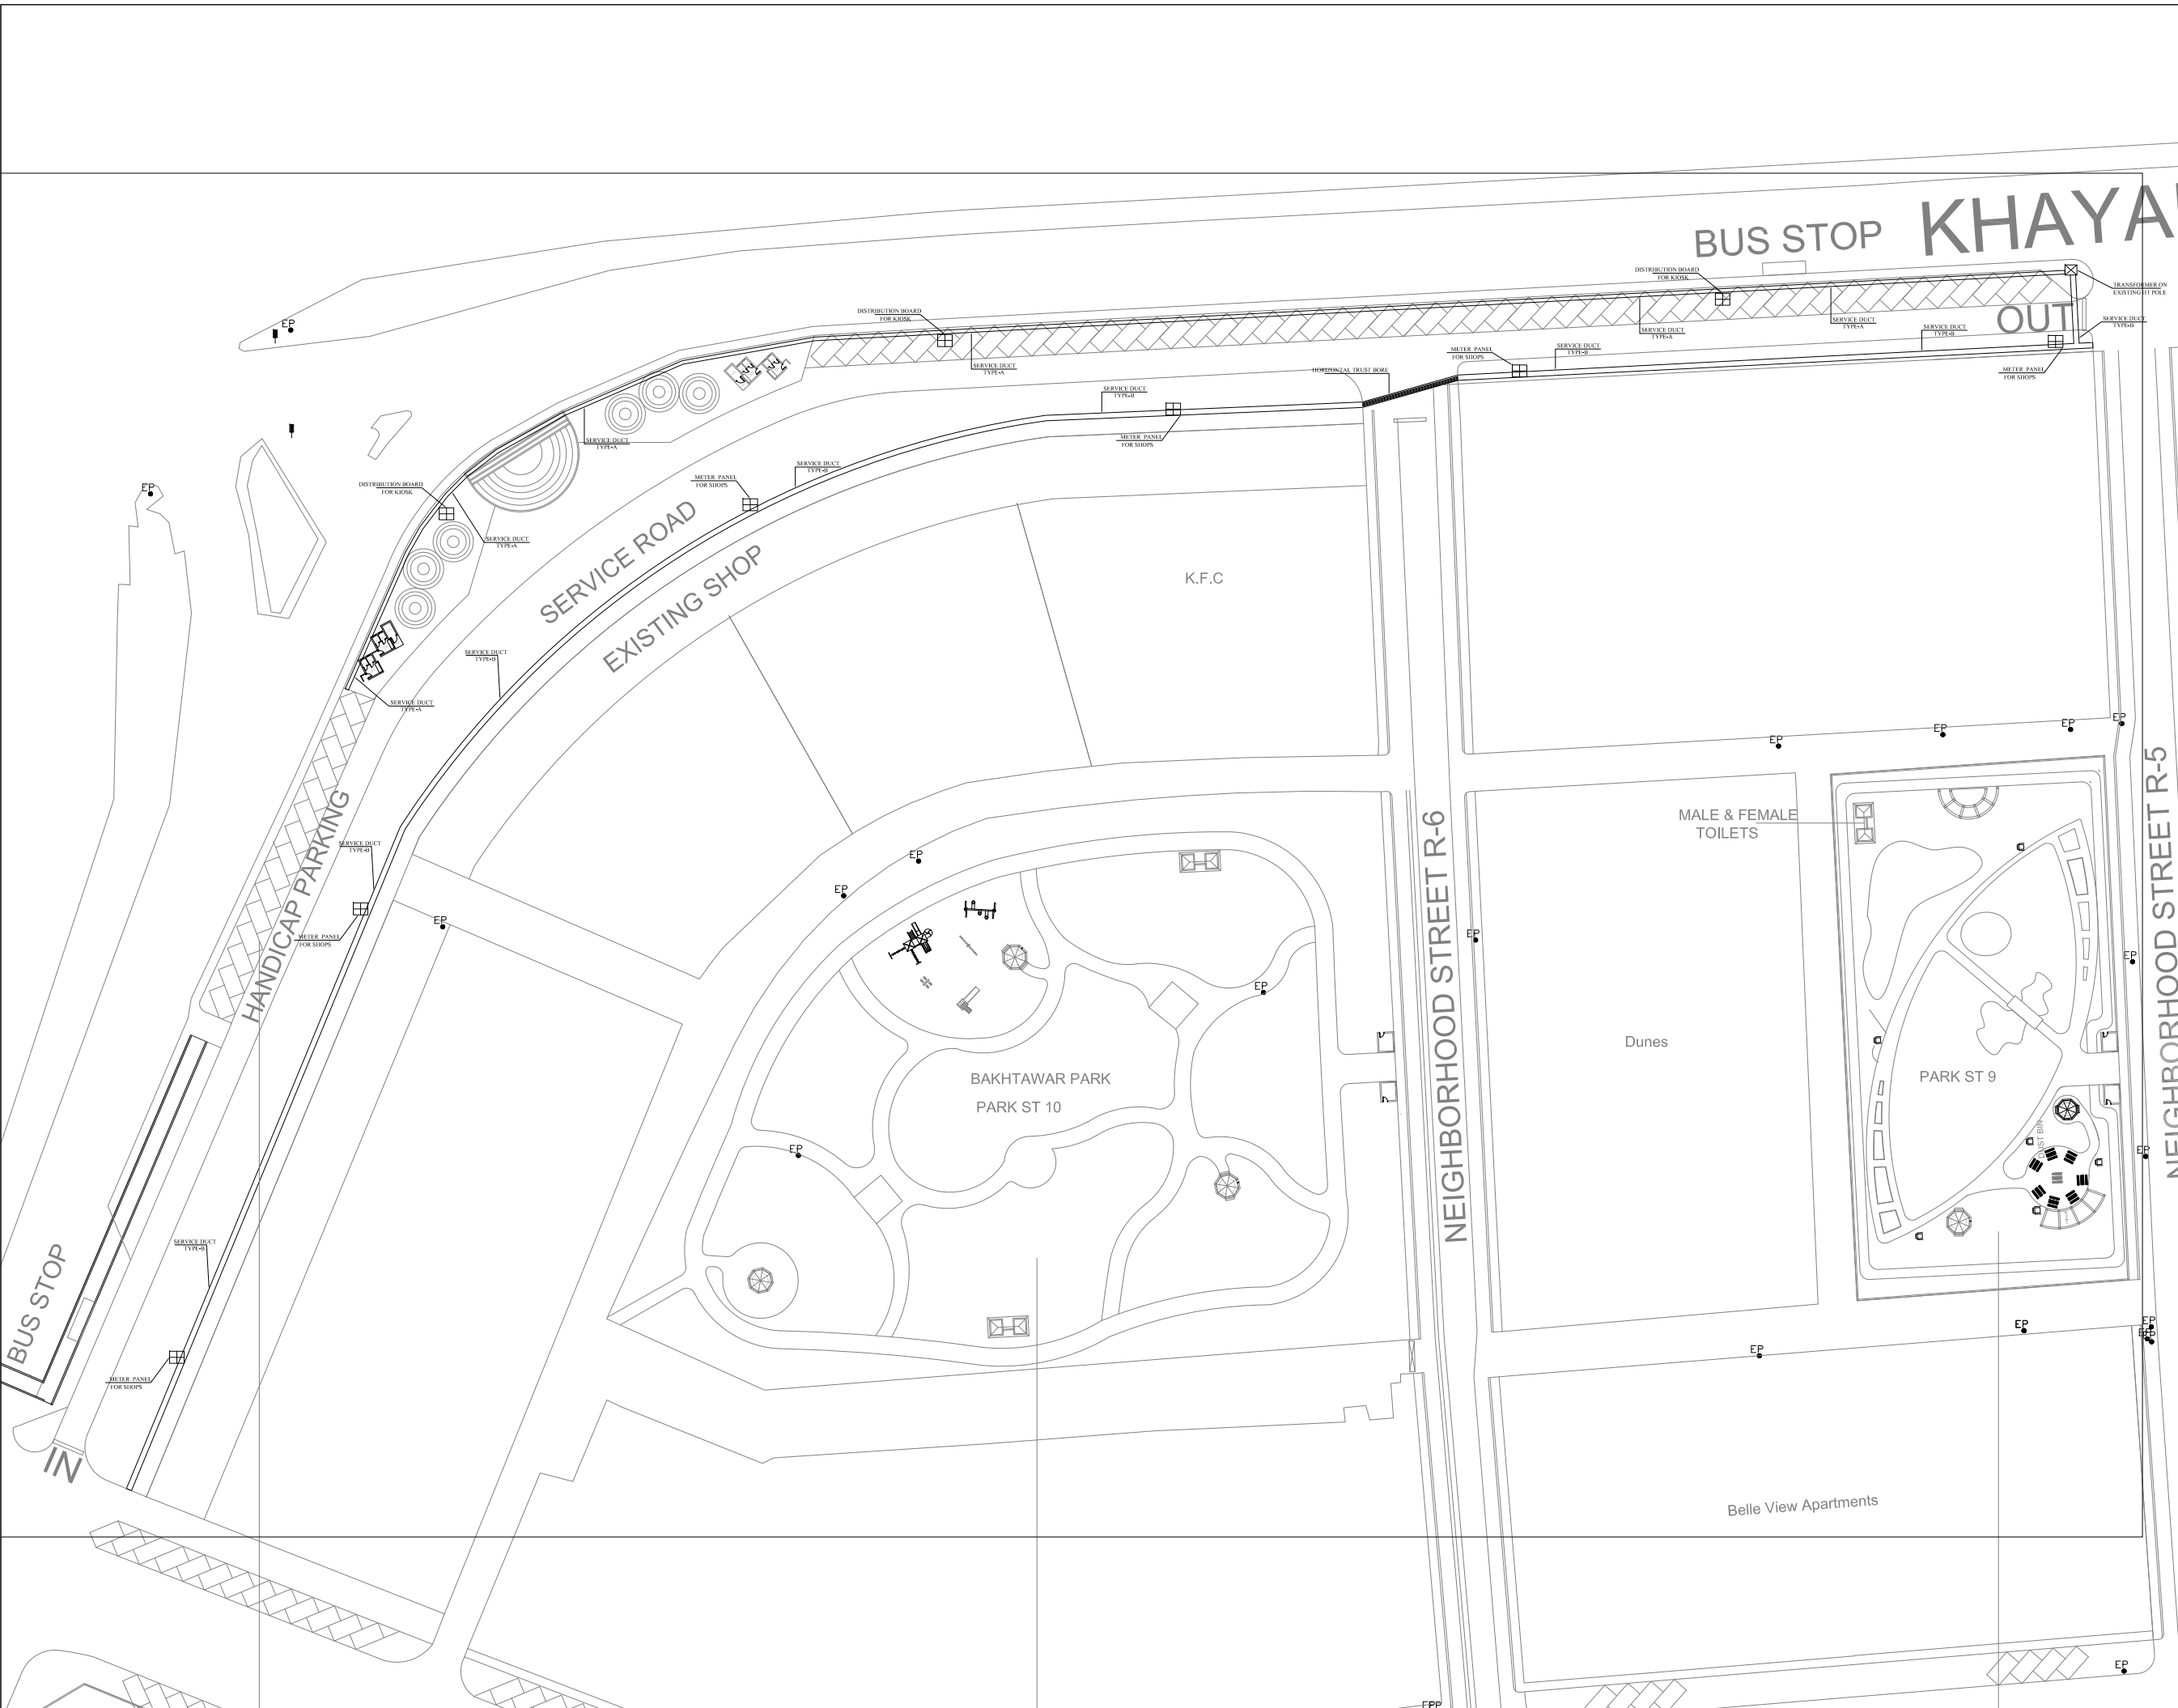

CLIENT:



PROJECT
IMPLEMENTATION
UNIT (PIU) KNIP



CONSULTANTS:

**G3 ENGINEERING
CONSULTANTS (PVT) LTD.**
House No.57-M Gulberg-II, Lahore, Pakistan



Tel : (92-42) 35441641, 35441642
Fax : (92-42) 35441645
E-mail : info@g3ec.com
URL : www.g3ec.com

PROJECT:

REHABILITATION & UP GRADATION OF
BOAT BASIN TO SCHON CHOWRANGI
WITH PEDESTRIAN TRAIL

NOTES:

1. ALL DIMENSIONS ARE IN FEET UNLESS OTHERWISE SPECIFIED.
2. THIS DRAWING IS AN INTELLECTUAL PROPERTY OF G3 ENGINEERING CONSULTANTS (PVT.) LTD. AND CANNOT BE REPRINTED OR REPRODUCED WITHOUT PRIOR APPROVAL OF G3.

REVISIONS:

No.	DESCRIPTION	DATE

TENDER DRAWINGS

DRAWING TITLE:

FOOD STREET
POWER DISTRIBUTION
LAYOUT

DRAWN BY:
Engr. M.RAFFEH

DATE:
Aug 2021

ELECTRICAL ENGINEER:
Engr. Ghulam Daraz Shaikh

APPROVED BY:
SAYED ALI ABBAS GILLANI

DRAWING NO:
0249/FS/02

REV:
4


SCALE (A3):
N.T.S

SHEET:
0/0

PEDESTRIAN TRAIL PLAN ELEVATION SECTION



TOILET BLOCK CONCEPT (AS PER FOOD STREET TOILET DESIGN)

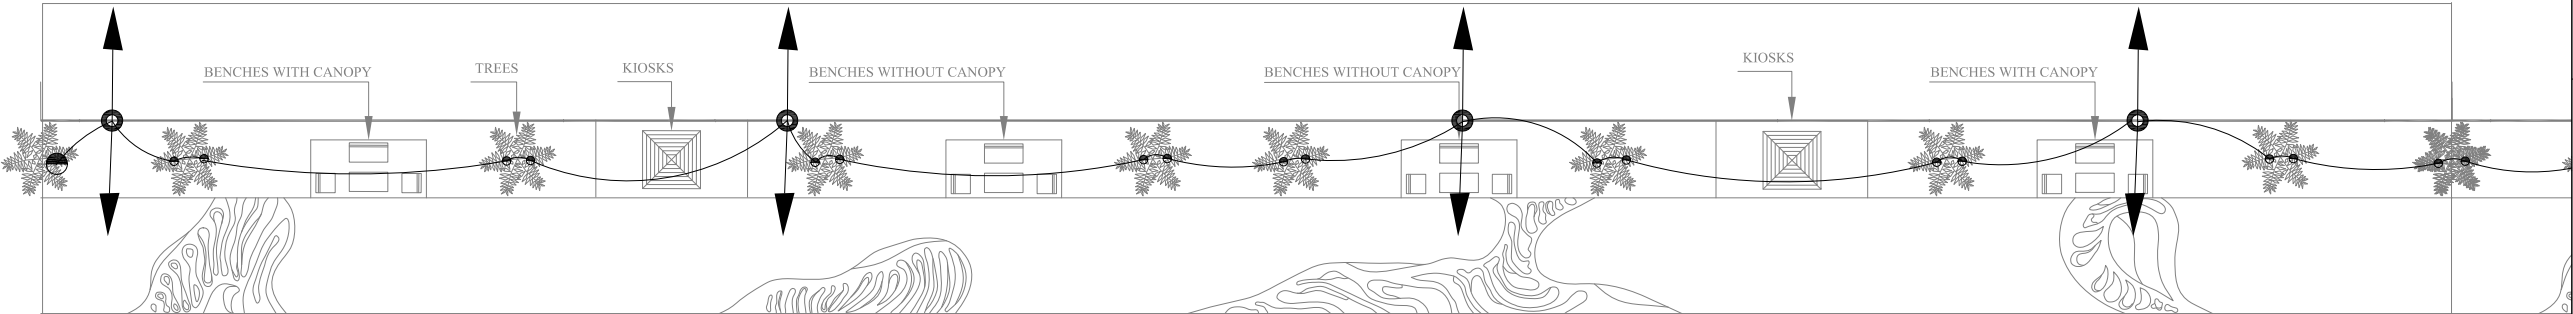

TOTAL LENGTH OF PEDESTRIAN TRAIL = 3300'
250' DESIGN PATCH PLAN (PEDESTRIAN TRAIL)
REST OF THE 3050' WILL BE THE EXTENSION OF SAME DESIGN.
FOOTPATH DEPTH CAN VARY AS PER THE EXISTING MEASUREMENTS
PEDESTRIAN TRAIL IS A NEW ADDITION
2 TOILET BLOCKS WILL BE DESIGNED AT EVERY 1000' INTERVAL

CLIENT:



PROJECT
IMPLEMENTATION
UNIT (PIU) KNIP



CONSULTANTS:

**G3 ENGINEERING
CONSULTANTS (PVT.) LTD.**
House No.57-M Gulberg-II, Lahore, Pakistan

Tel : (92-42) 35441641, 35441642
Fax : (92-42) 35441645
E-mail : info@g3ec.com
URL : www.g3ec.com

PROJECT:

REHABILITATION & UP GRADATION OF
BOAT BASIN TO SCHON CHOWRANGI
WITH PEDESTRIAN TRAIL

NOTES:

1. ALL DIMENSIONS ARE IN FEET UNLESS OTHERWISE SPECIFIED.
2. THIS DRAWING IS AN INTELLECTUAL PROPERTY OF G3 ENGINEERING CONSULTANTS (PVT.) LTD. AND CANNOT BE REPRINTED OR REPRODUCED WITHOUT PRIOR APPROVAL OF G3.

REVISIONS:


No.	DESCRIPTION	DATE

TENDER DRAWINGS

DRAWING TITLE:

PEDESTRIAN TRAIL
ELECTRICAL LAYOUT

DRAWN BY: Engr. M.RAFFEH	DATE: Aug 2021
ELECTRICAL ENGINEER: Engr. Ghulam Daraz Shaikh	
APPROVED BY: SAYED ALI ABBAS GILLANI	
DRAWING NO: 0249/PT/04	REV: 4
SCALE (A3): N.T.S	SHEET: 0/0

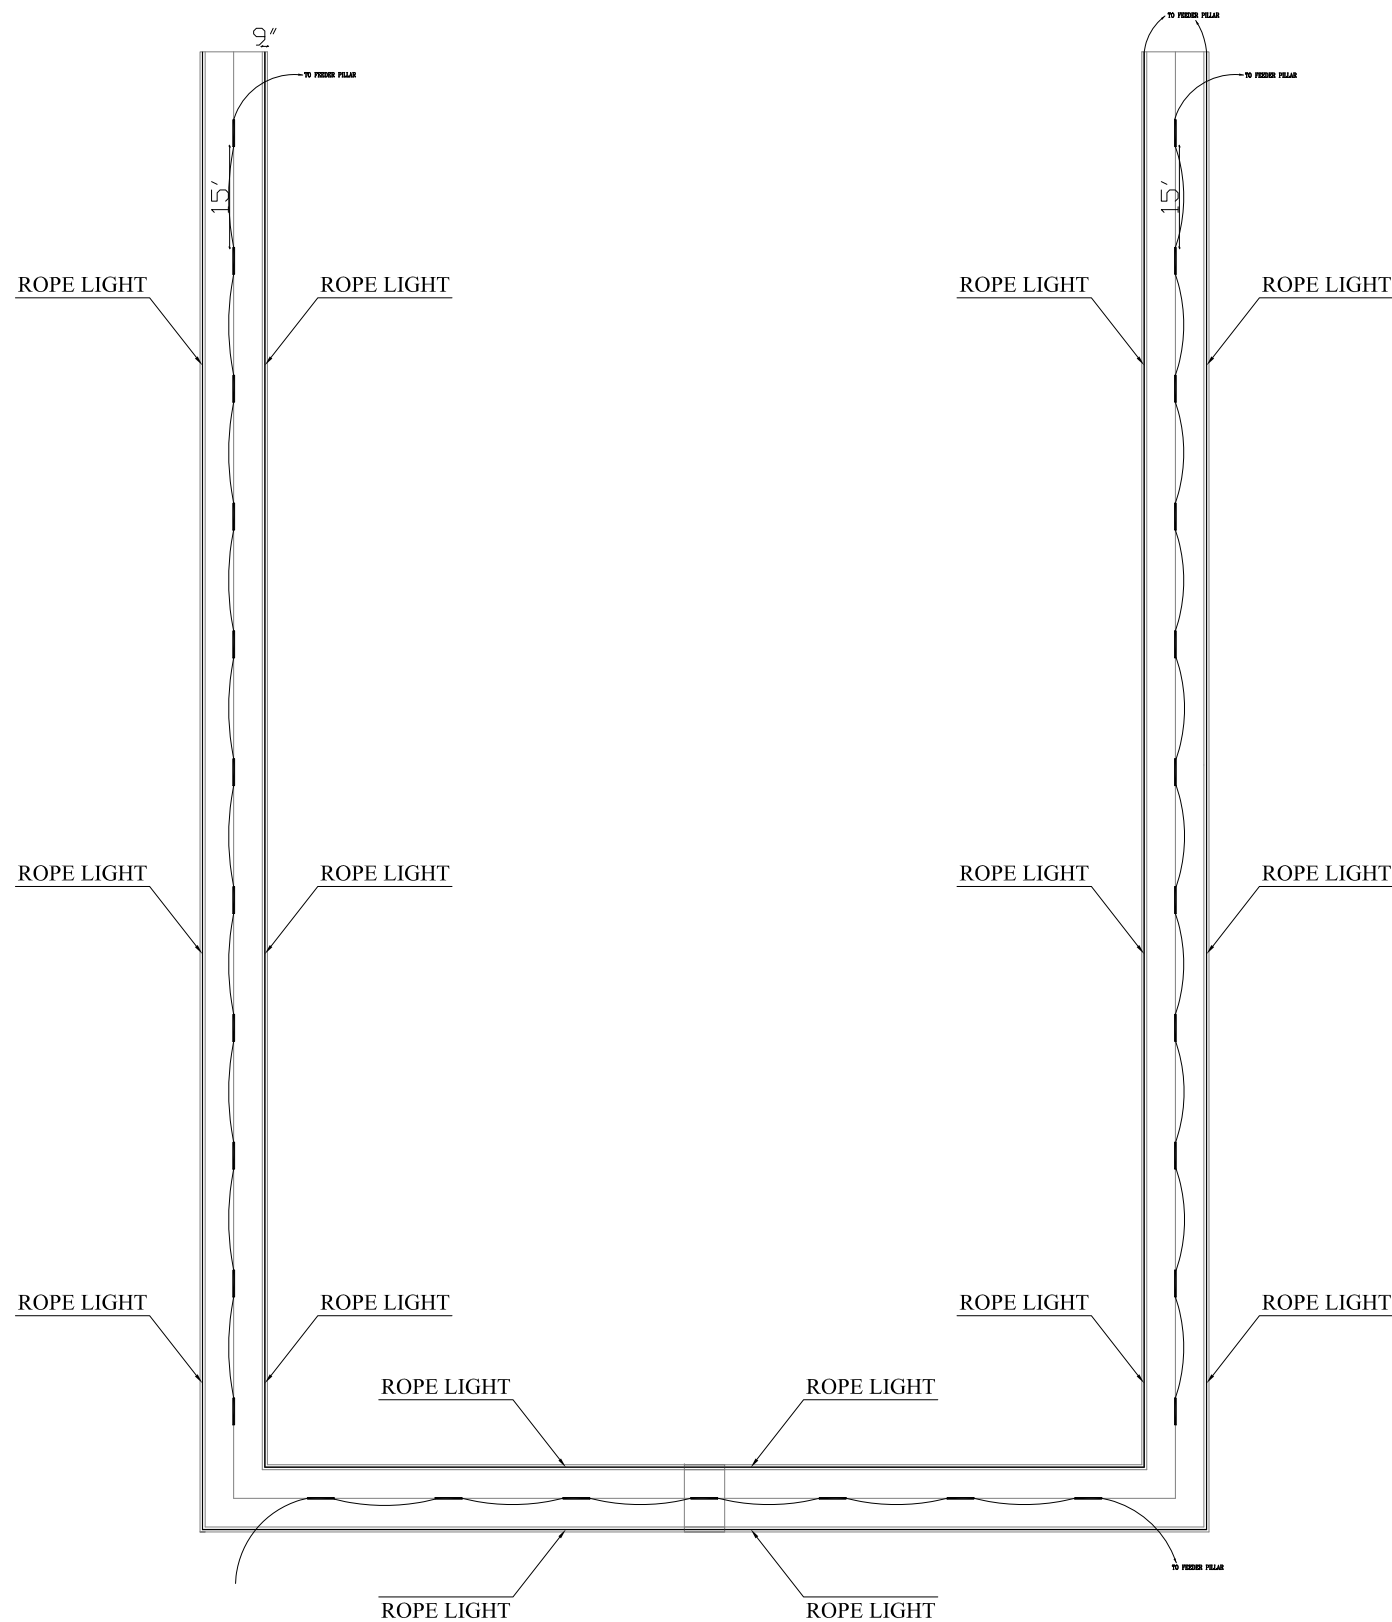

CLIENT:



PROJECT
IMPLEMENTATION
UNIT (PIU) KNIP



CONSULTANTS:
**G3 ENGINEERING
CONSULTANTS (PVT) LTD.**
House No.57-M Gulberg-II, Lahore, Pakistan
Tel : (92-42) 35441641, 35441642
Fax : (92-42) 35441645
E-mail : info@g3ec.com
URL : www.g3ec.com

PROJECT:

REHABILITATION & UP GRADATION OF
BOAT BASIN TO SCHON CHOWRANGI
WITH PEDESTRIAN TRAIL

NOTES:
1. ALL DIMENSIONS ARE IN FEET UNLESS
OTHERWISE SPECIFIED.
2. THIS DRAWING IS AN INTELLECTUAL PROPERTY
OF G3 ENGINEERING CONSULTANTS (PVT.) LTD.
AND CANNOT BE REPRINTED OR REPRODUCED
WITHOUT PRIOR APPROVAL OF G3.


REVISIONS:

No.	DESCRIPTION	DATE


TENDER DRAWINGS

DRAWING TITLE:
**PEDESTRIAN TRAIL
BRIDGE
LIGHTING PLAN**

DRAWN BY: Engr. M.RAFFEH	DATE: Aug 2021
ELECTRICAL ENGINEER: Engr. Ghulam Daraz Shaikh	
APPROVED BY: SAYED ALI ABBAS GILLANI	
DRAWING NO: 0249/PT/05	REV: 4
SCALE (A3): N.T.S	SHEET: 0/0

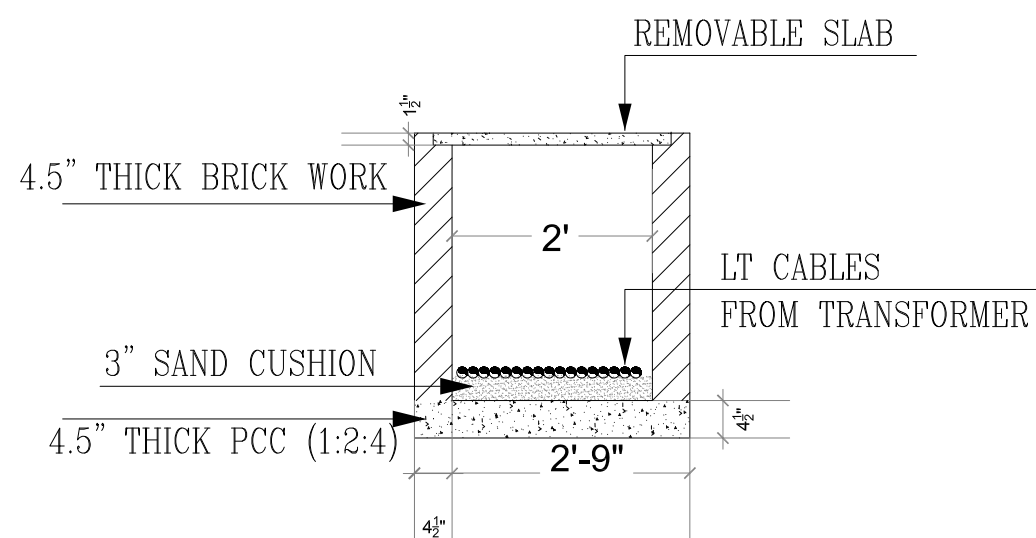

SERVICE DUCT TYPE-A

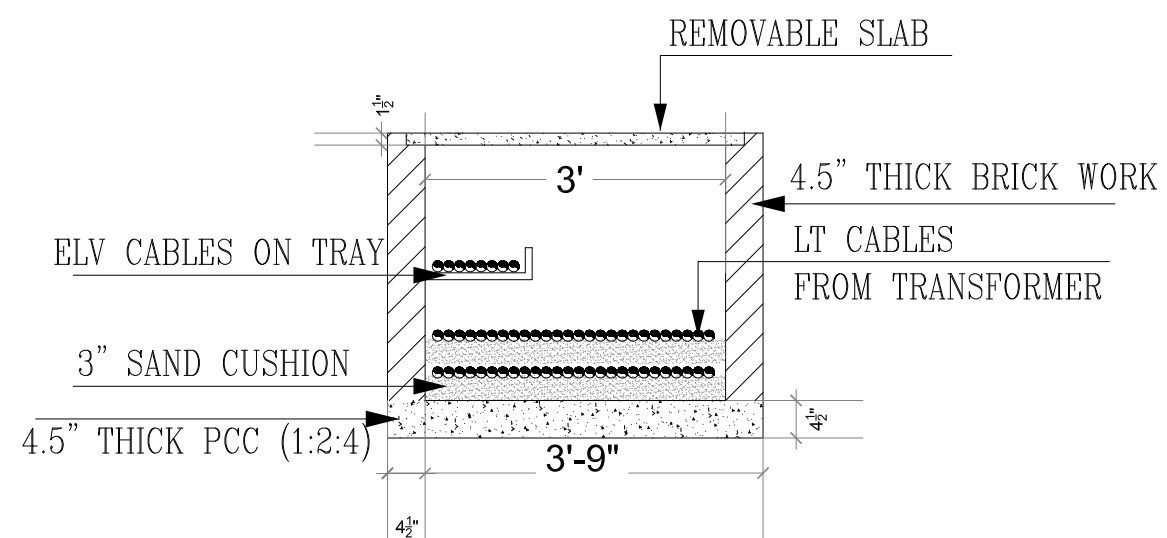

SERVICE DUCT TYPE-B

CLIENT:



PROJECT
IMPLEMENTATION
UNIT (PIU) KNIP



CONSULTANTS:
**G3 ENGINEERING
CONSULTANTS (PVT) LTD.**
House No.57-M Gulberg-II, Lahore, Pakistan
Tel : (92-42) 35441641, 35441642
Fax : (92-42) 35441645
E-mail : info@g3ec.com
URL : www.g3ec.com

PROJECT:

REHABILITATION & UP GRADATION OF
BOAT BASIN TO SCHON CHOWRANGI
WITH PEDESTRIAN TRAIL

NOTES:

1. ALL DIMENSIONS ARE IN FEET UNLESS OTHERWISE SPECIFIED.
2. THIS DRAWING IS AN INTELLECTUAL PROPERTY OF G3 ENGINEERING CONSULTANTS (PVT.) LTD. AND CANNOT BE REPRINTED OR REPRODUCED WITHOUT PRIOR APPROVAL OF G3.

REVISIONS:


No.	DESCRIPTION	DATE

TENDER DRAWINGS

DRAWING TITLE:

FOOD STREET
SERVICE DUCT
LAYOUT PLAN

DRAWN BY: Engr. M.RAFFEH	DATE: Aug 2021
ELECTRICAL ENGINEER: Engr. Ghulam Daraz Shaikh	
APPROVED BY: SAYED ALI ABBAS GILLANI	
DRAWING NO: 0249/FS/06	REV: 4
SCALE (A3): N.T.S	SHEET: 0/0

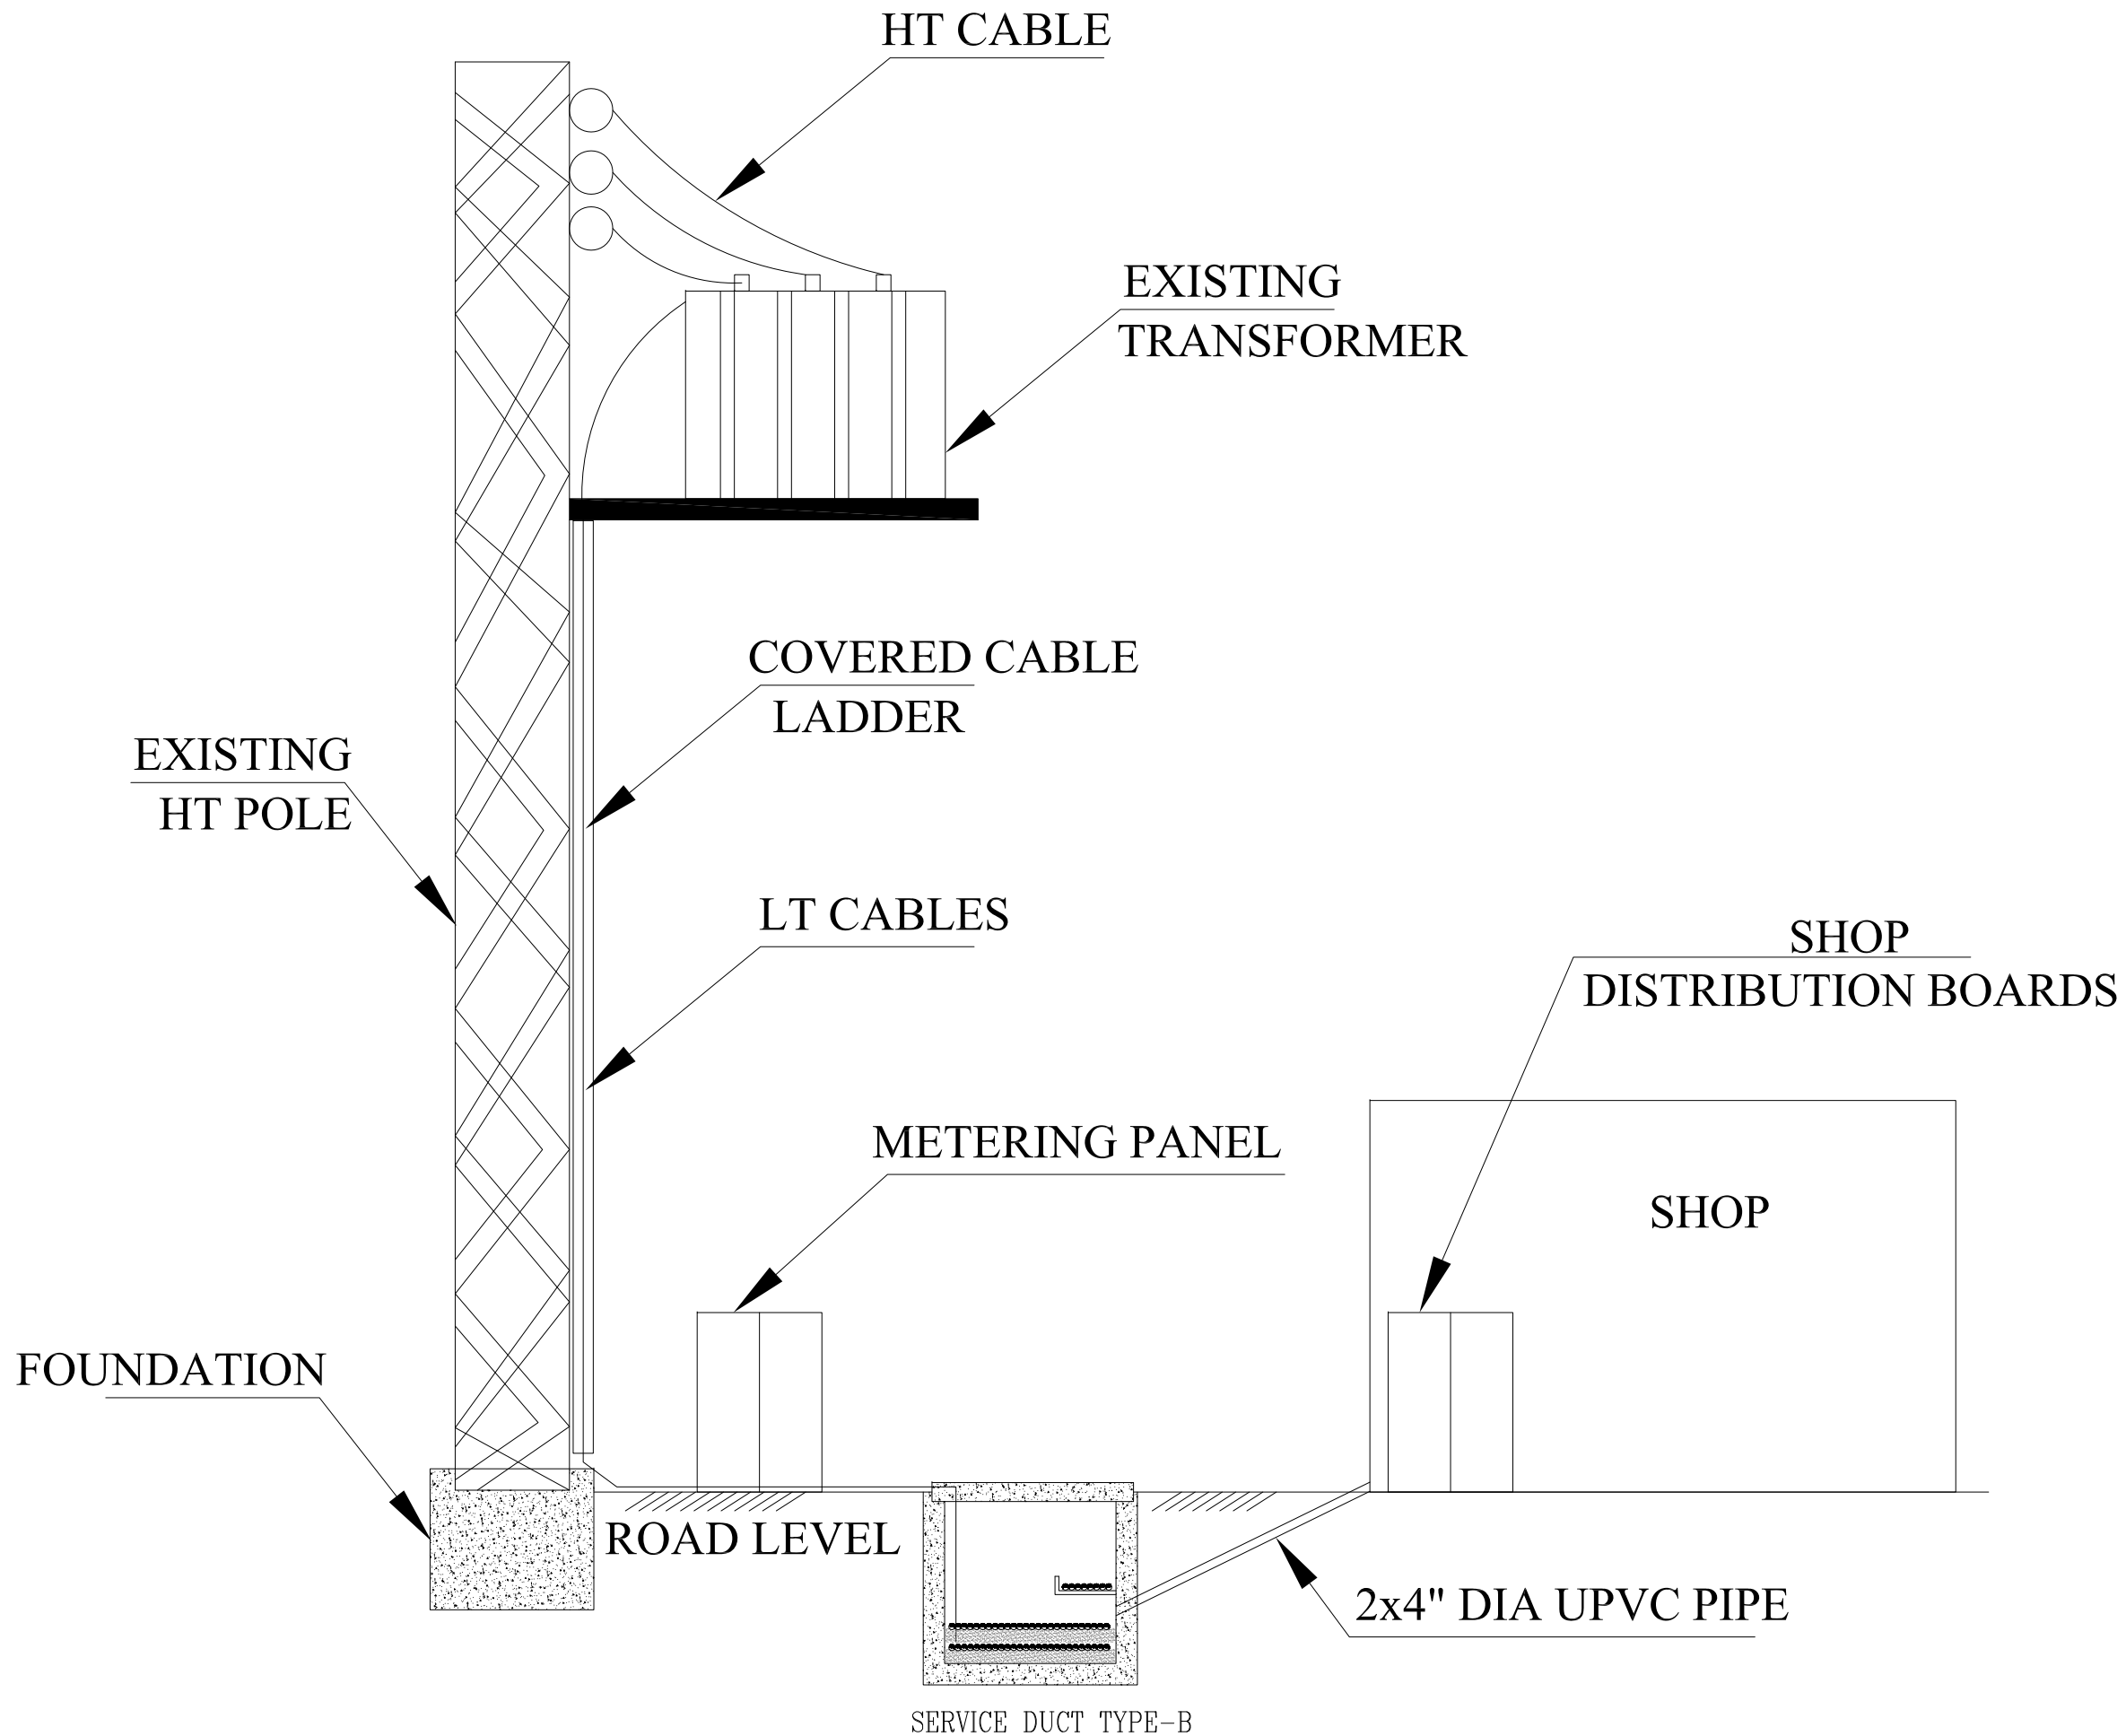

CLIENT:



PROJECT
IMPLEMENTATION
UNIT (PIU) KNIP



CONSULTANTS:
**G3 ENGINEERING
CONSULTANTS (PVT) LTD.**
House No.57-M Gulberg-II, Lahore, Pakistan
Tel : (92-42) 35441641, 35441642
Fax : (92-42) 35441645
E-mail : info@g3ec.com
URL : www.g3ec.com

PROJECT:

REHABILITATION & UP GRADATION OF
BOAT BASIN TO SCHON CHOWRANGI
WITH PEDESTRIAN TRAIL

NOTES:

1. ALL DIMENSIONS ARE IN FEET UNLESS OTHERWISE SPECIFIED.
2. THIS DRAWING IS AN INTELLECTUAL PROPERTY OF G3 ENGINEERING CONSULTANTS (PVT.) LTD. AND CANNOT BE REPRINTED OR REPRODUCED WITHOUT PRIOR APPROVAL OF G3.

REVISIONS:

No.	DESCRIPTION	DATE

TENDER DRAWINGS

DRAWING TITLE:

FOOD STREET
POWER DISTRIBUTION
SYSTEM DETAIL


DRAWN BY: Engr. M.RAFFEH DATE: Aug 2021

ELECTRICAL ENGINEER: Engr. Ghulam Daraz Shaikh

APPROVED BY: SAYED ALI ABBAS GILLANI

DRAWING NO: 0249/FS/07 REV: 4

SCALE (A3): N.T.S SHEET: 0/0

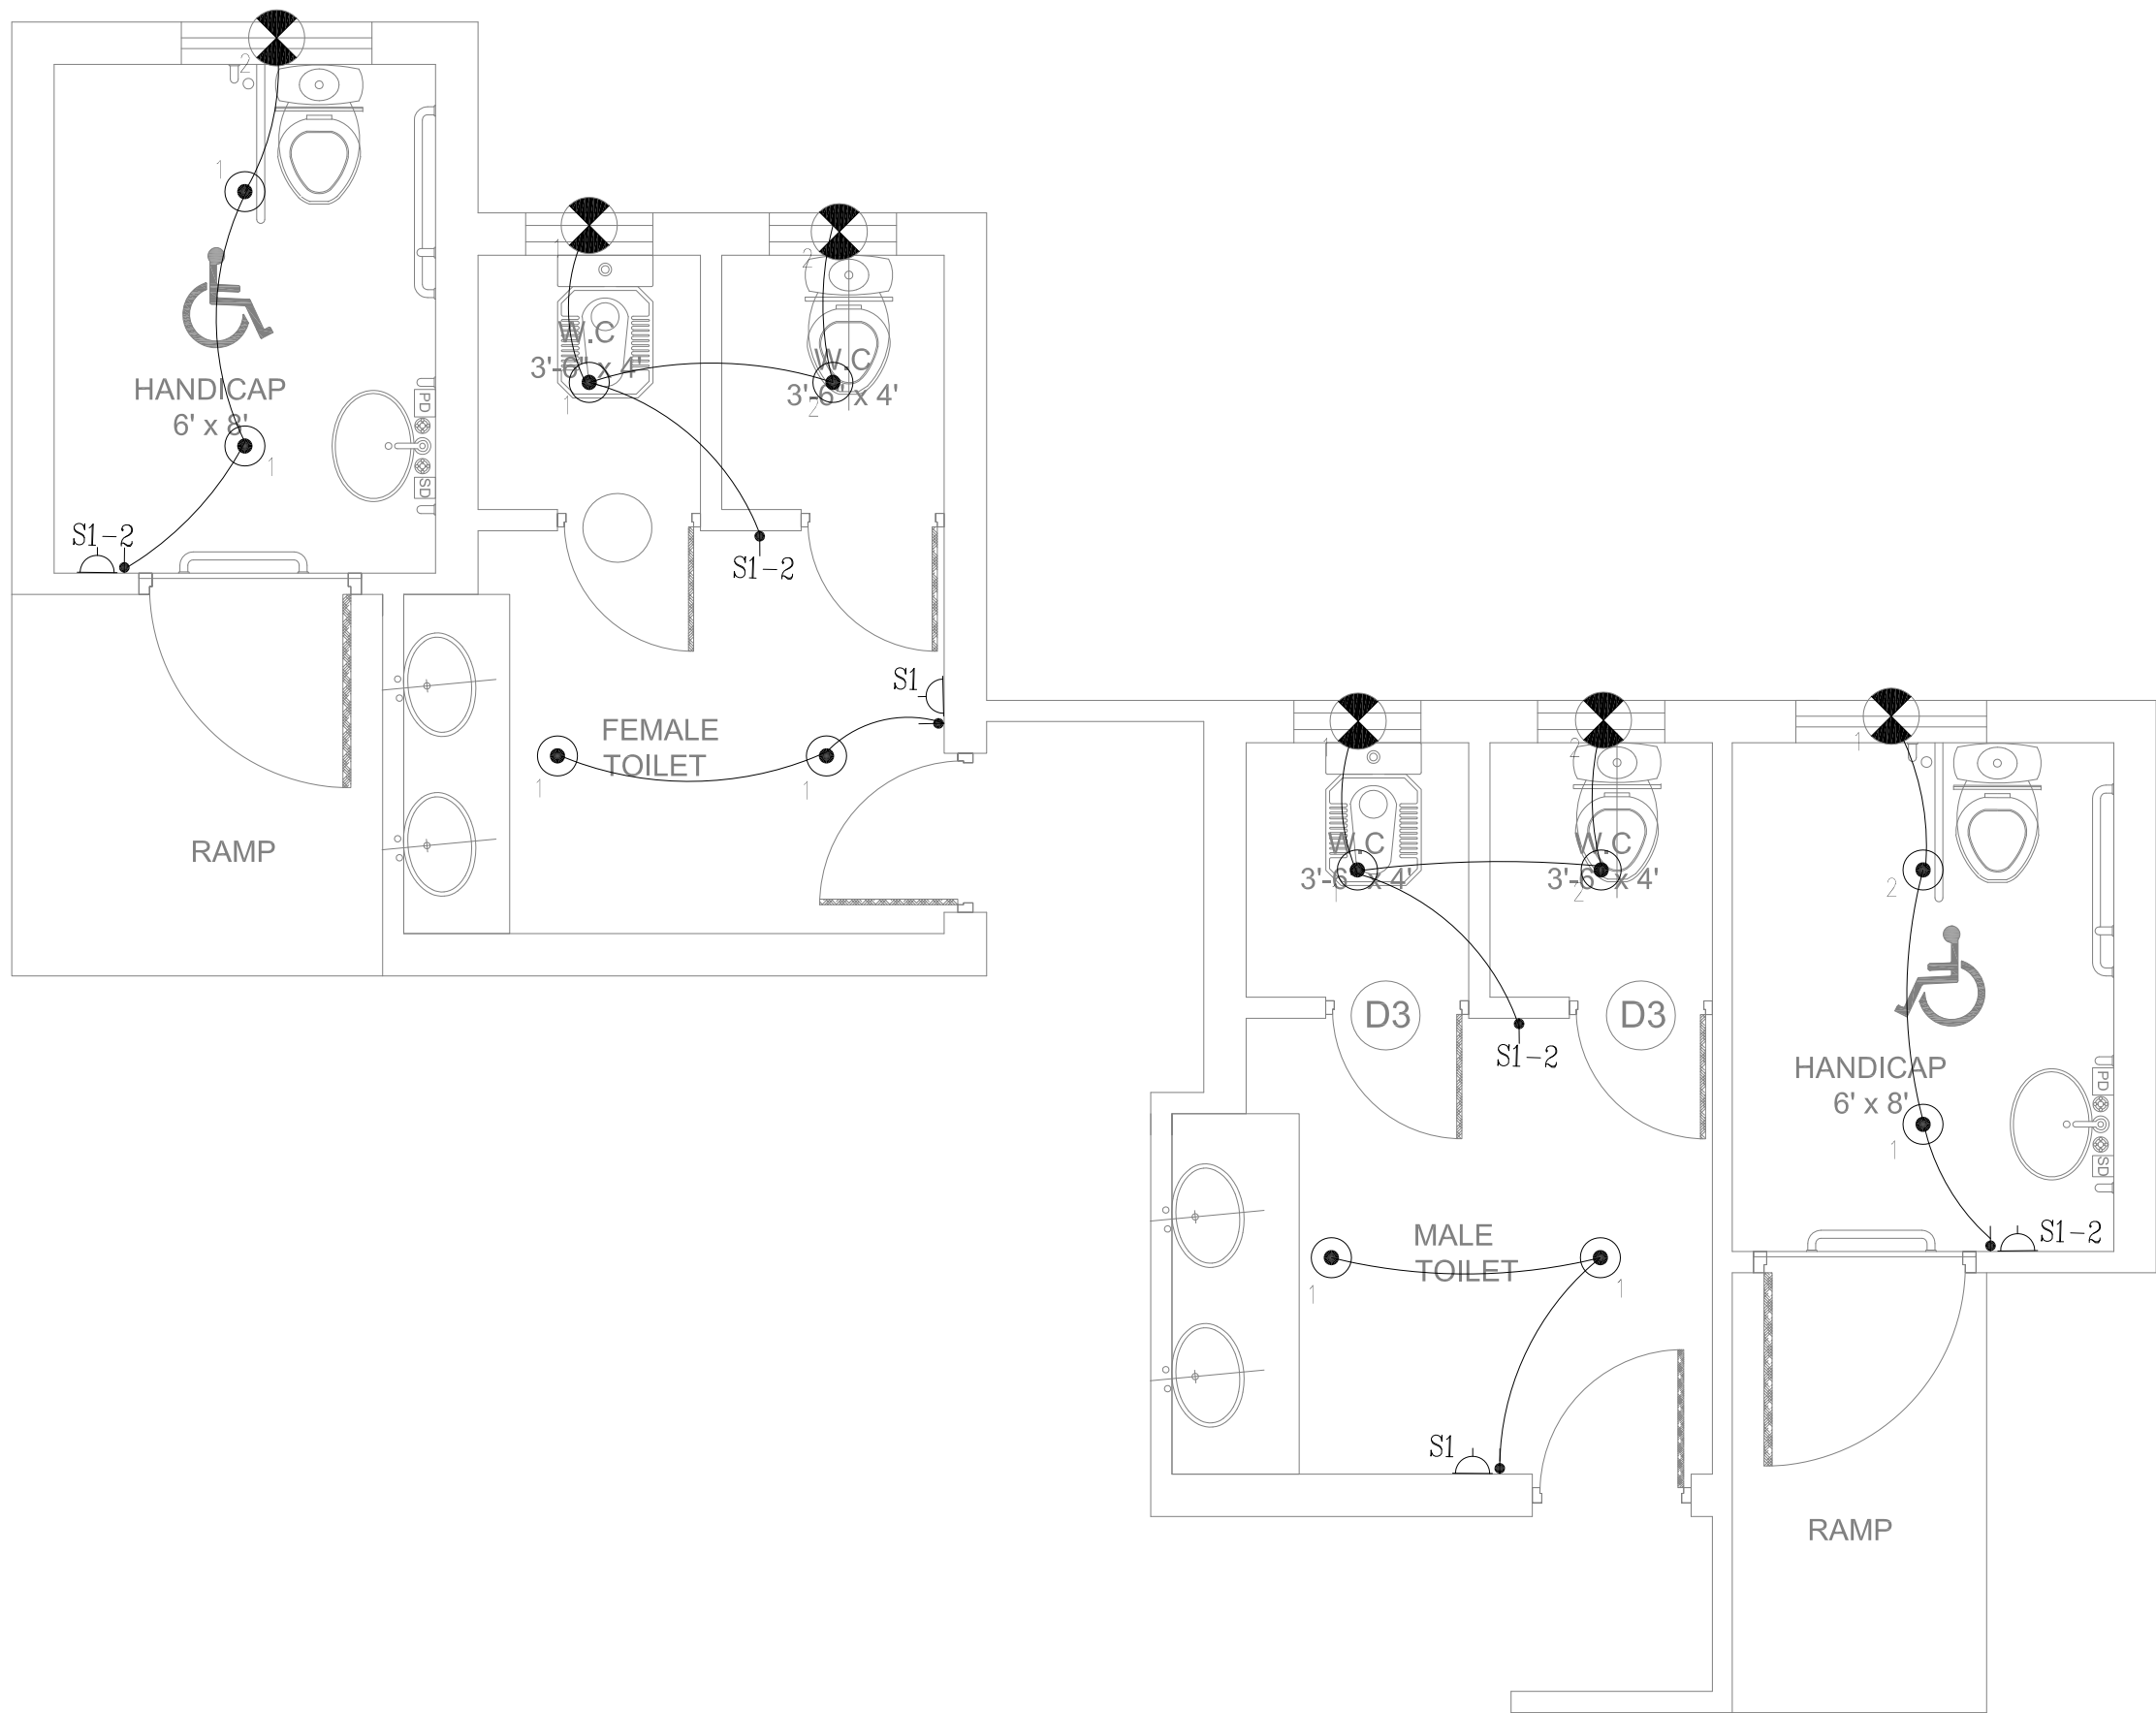

CLIENT:



PROJECT
IMPLEMENTATION
UNIT (PIU) KNIP



CONSULTANTS:
**G3 ENGINEERING
CONSULTANTS (PVT) LTD.**
House No.57-M Gulberg-II, Lahore, Pakistan
Tel : (92-42) 35441641, 35441642
Fax : (92-42) 35441645
E-mail : info@g3ec.com
URL : www.g3ec.com

PROJECT:

REHABILITATION & UP GRADATION OF
BOAT BASIN TO SCHON CHOWRANGI
WITH PEDESTRIAN TRAIL

NOTES:

1. ALL DIMENSIONS ARE IN FEET UNLESS OTHERWISE SPECIFIED.
2. THIS DRAWING IS AN INTELLECTUAL PROPERTY OF G3 ENGINEERING CONSULTANTS (PVT.) LTD. AND CANNOT BE REPRINTED OR REPRODUCED WITHOUT PRIOR APPROVAL OF G3.

REVISIONS:

No.	DESCRIPTION	DATE

TENDER DRAWINGS

DRAWING TITLE:
**TOILET BLOCK- FOOD
STREET
ILLUMINATION
LAYOUT PLAN**

DRAWN BY: Engr. M.RAFFEH	DATE: Aug 2021
ELECTRICAL ENGINEER: Engr. Ghulam Daraz Shaikh	
APPROVED BY: SAYED ALI ABBAS GILLANI	
DRAWING NO: 0249/FS/TB/07A	REV: 4
SCALE (A3): N.T.S	SHEET: 0/0

CLIENT:



PROJECT
IMPLEMENTATION
UNIT (PIU) KNIP



CONSULTANTS:

G3 ENGINEERING
CONSULTANTS (PVT) LTD.
House No.57-M Gulberg-II, Lahore, Pakistan

Tel : (92-42) 35441641, 35441642
Fax : (92-42) 35441645
E-mail : info@g3ec.com
URL : www.g3ec.com

PROJECT:

REHABILITATION & UP GRADATION OF
BOAT BASIN TO SCHON CHOWRANGI
WITH PEDESTRIAN TRAIL

NOTES:

1. ALL DIMENSIONS ARE IN FEET UNLESS OTHERWISE SPECIFIED.
2. THIS DRAWING IS AN INTELLECTUAL PROPERTY OF G3 ENGINEERING CONSULTANTS (PVT.) LTD. AND CANNOT BE REPRINTED OR REPRODUCED WITHOUT PRIOR APPROVAL OF G3.

REVISIONS:

No.	DESCRIPTION	DATE

TENDER DRAWINGS

DRAWING TITLE:

ST-5
ILLUMINATION
LAYOUT PLAN

DRAWN BY:
Engr. M.RAFFEH

DATE:
Aug 2021

ELECTRICAL ENGINEER:
Engr. Ghulam Daraz Shaikh


APPROVED BY:
SAYED ALI ABBAS GILLANI


DRAWING NO:
0249/PARKS/08

REV:
4

SCALE (A3):
N.T.S

SHEET:
0/0

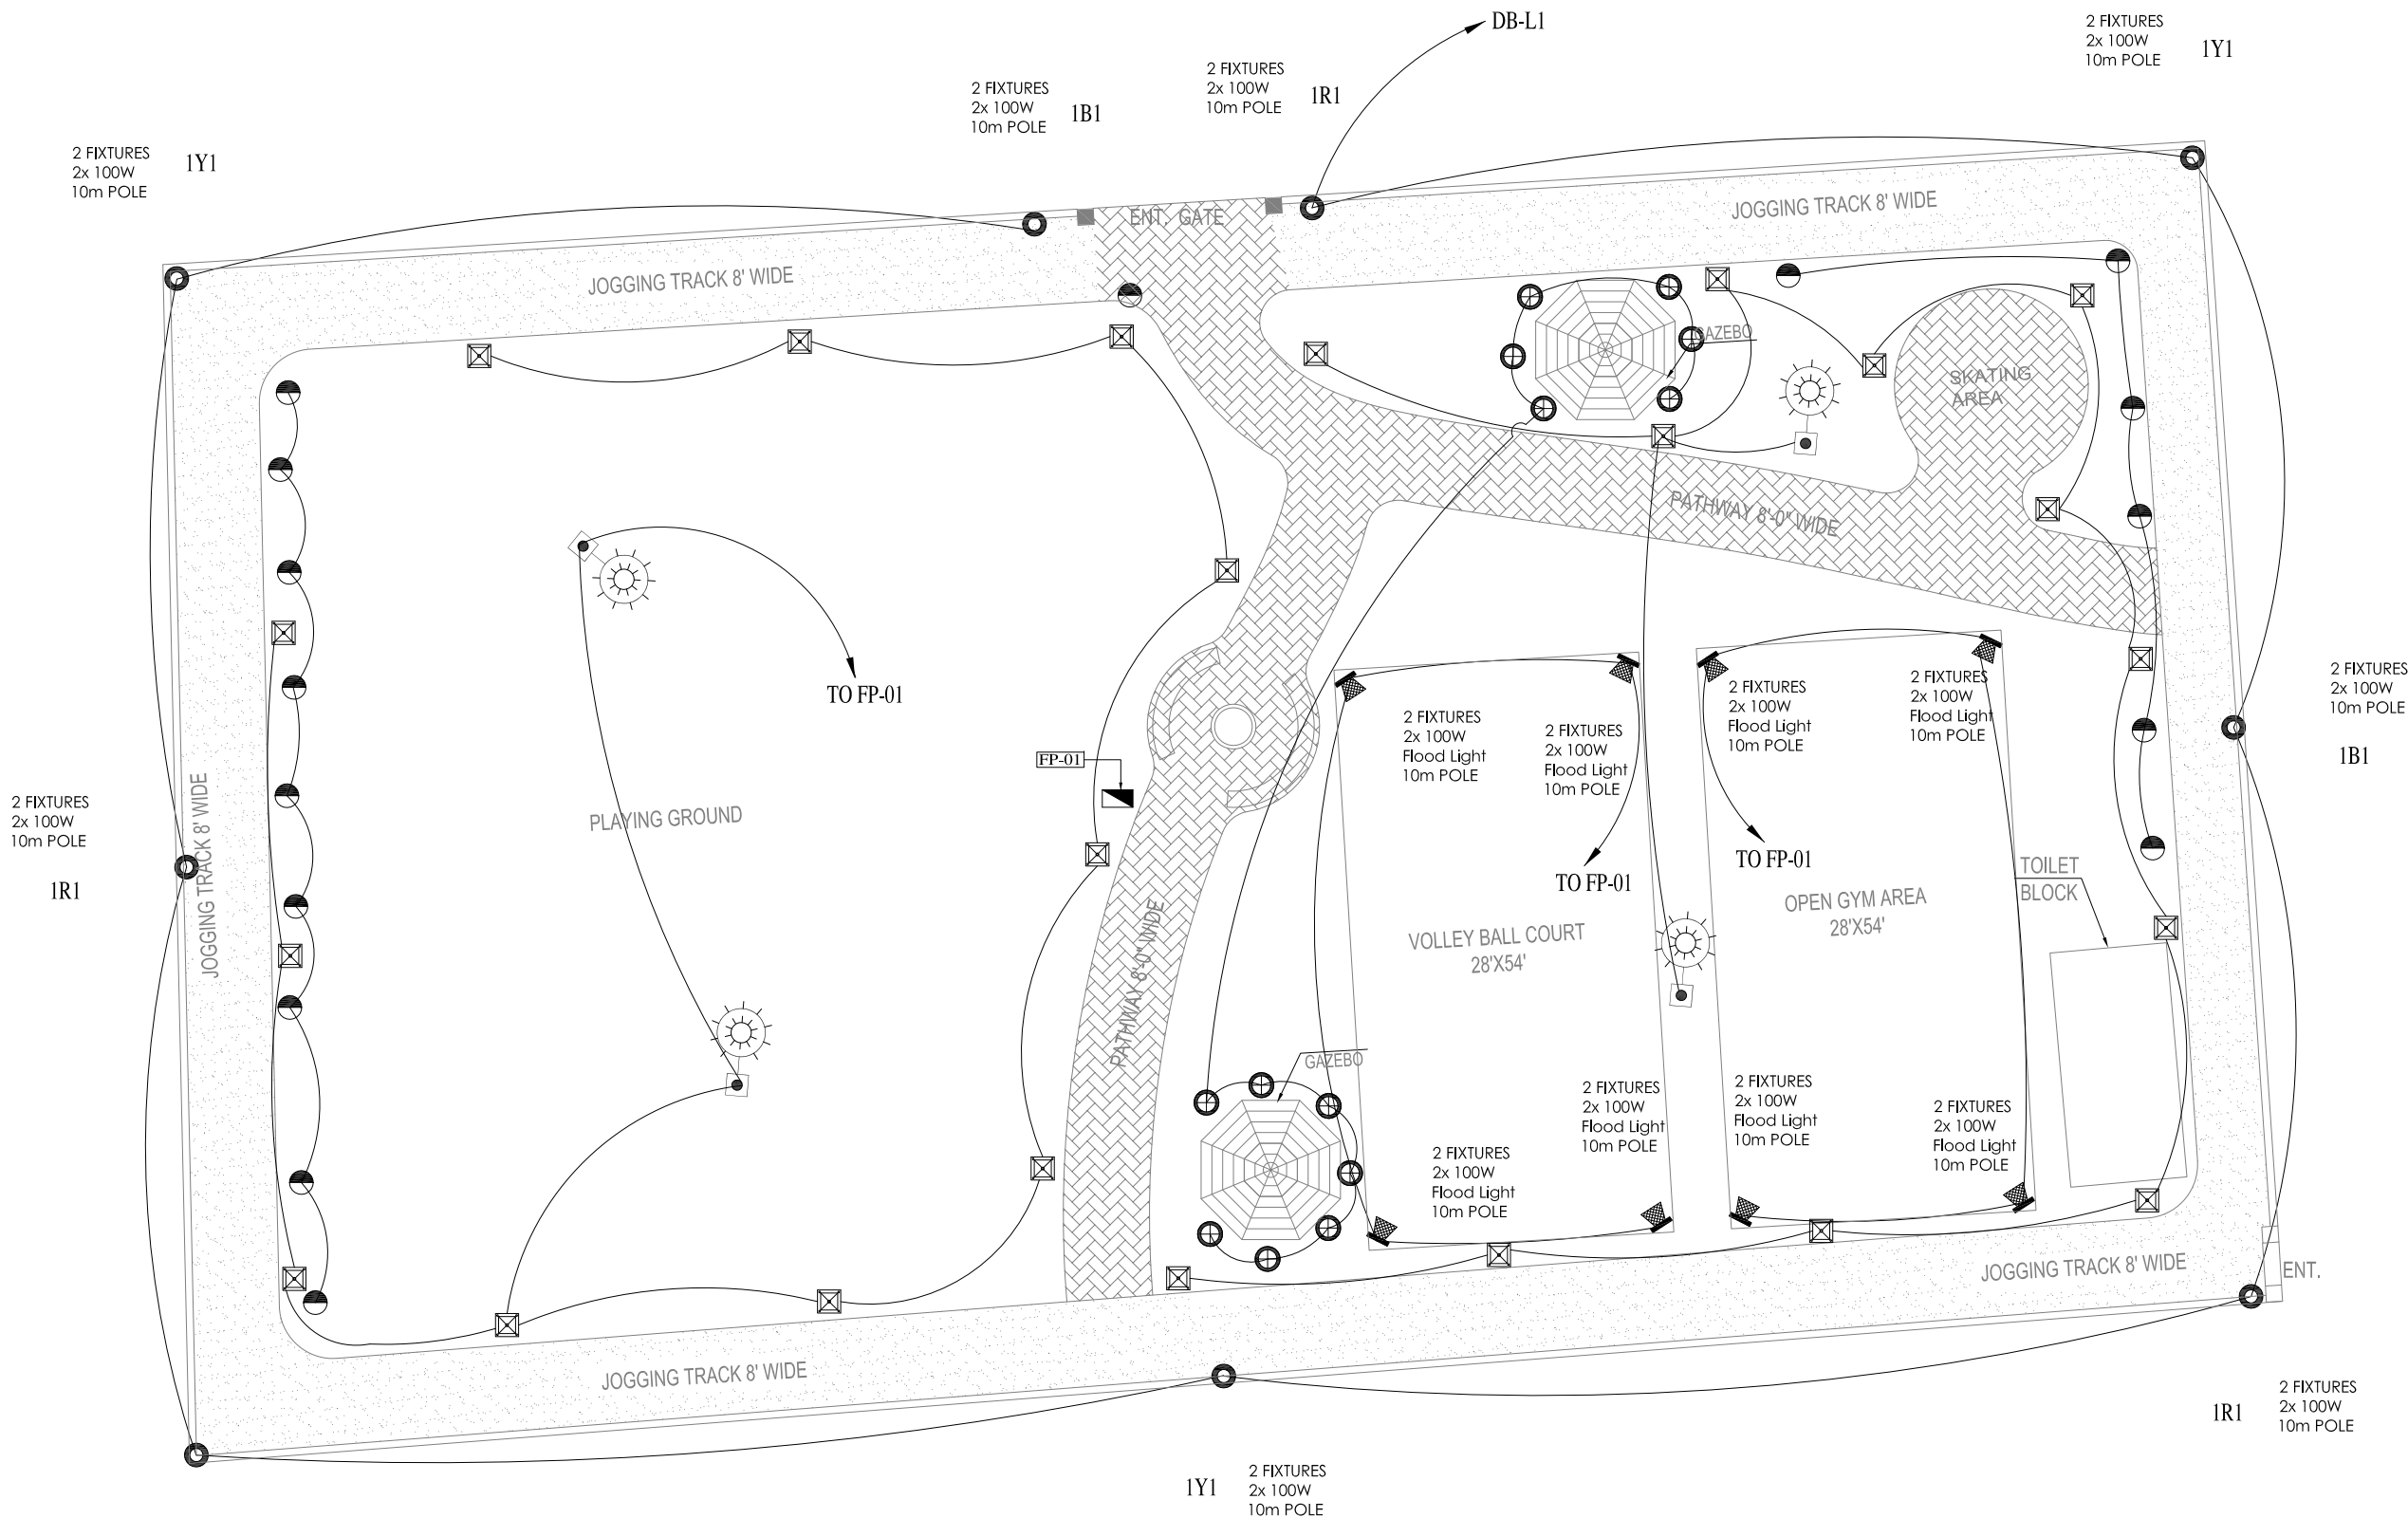


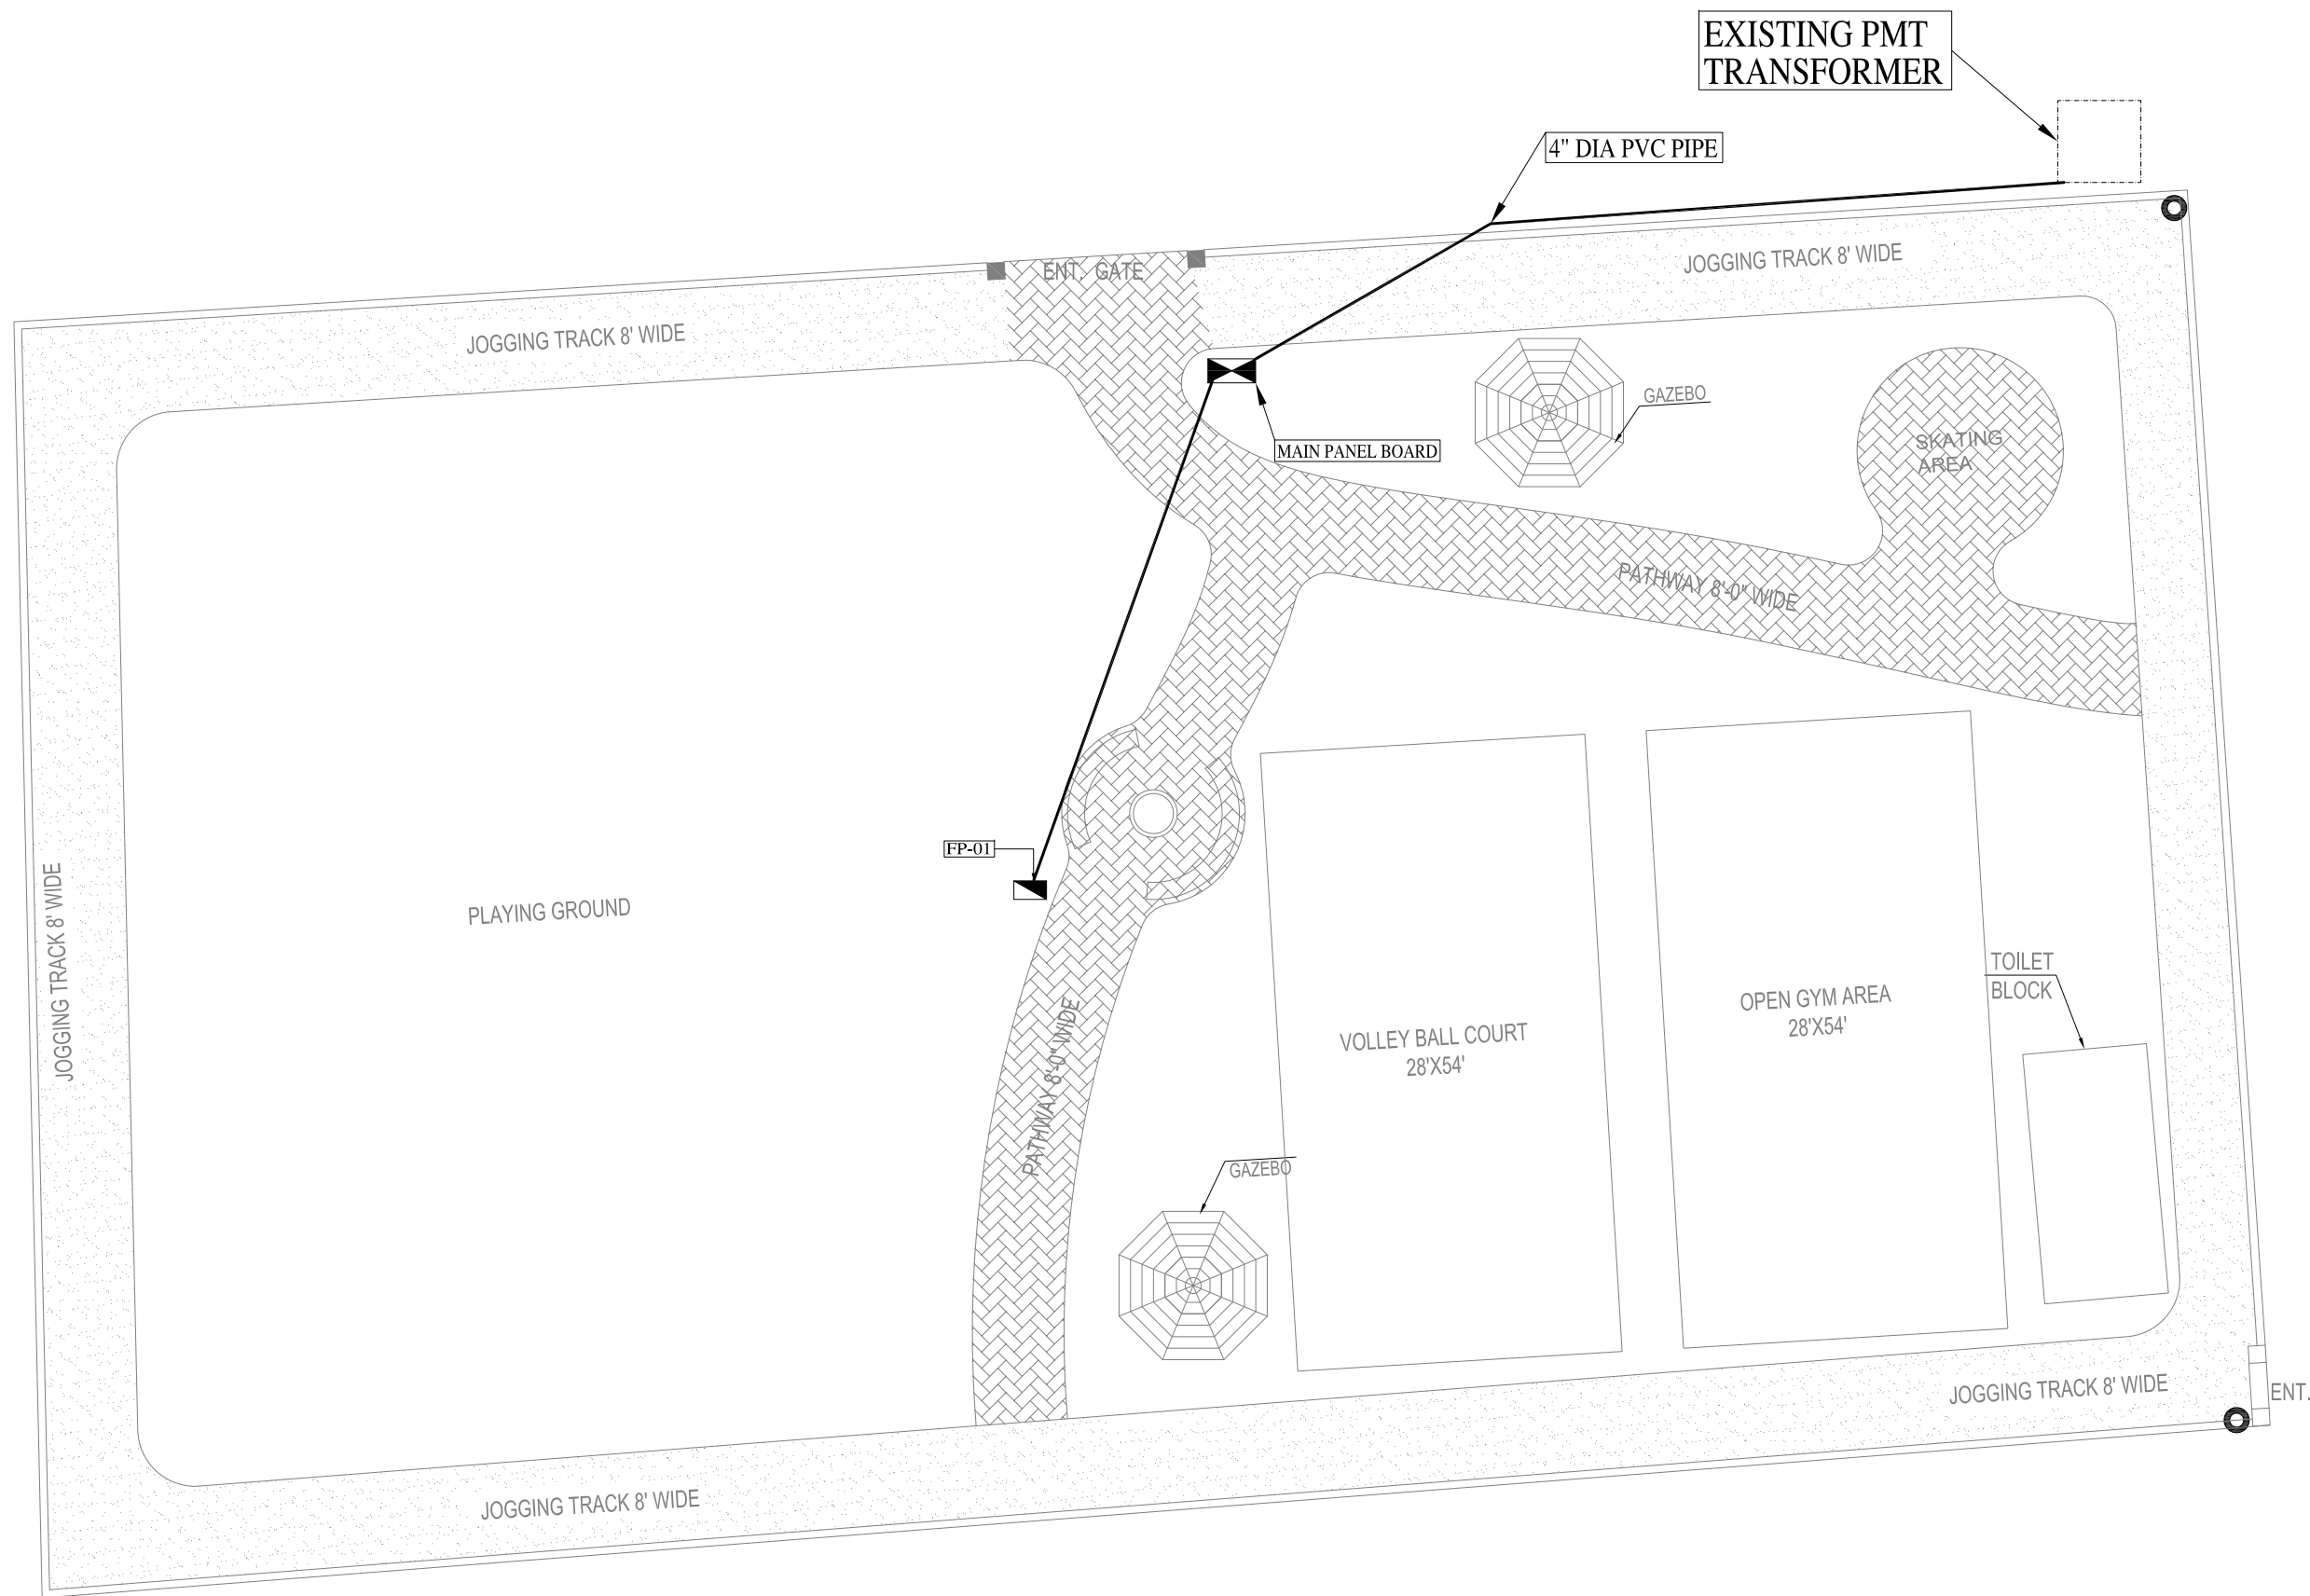

CLIENT:



 PROJECT
IMPLEMENTATION
UNIT (PIU) KNIP



CONSULTANTS:

**G3 ENGINEERING
CONSULTANTS (PVT)LTD.**
House No.57-M Gulberg-II, Lahore, Pakistan

Tel : (92-42) 35441641, 35441642
Fax : (92-42) 35441645
E-mail : info@g3ec.com
URL : www.g3ec.com

PROJECT:

REHABILITATION & UP GRADATION OF
BOAT BASIN TO SCHON CHOWRANGI
WITH PEDESTRIAN TRAIL

NOTES:

1. ALL DIMENSIONS ARE IN FEET UNLESS OTHERWISE SPECIFIED.
2. THIS DRAWING IS AN INTELLECTUAL PROPERTY OF G3 ENGINEERING CONSULTANTS (PVT.) LTD. AND CANNOT BE REPRINTED OR REPRODUCED WITHOUT PRIOR APPROVAL OF G3.

REVISIONS:

No.	DESCRIPTION	DATE

TENDER DRAWINGS

DRAWING TITLE:

**ST-5
POWER DISTRIBUTION
LAYOUT PLAN**

DRAWN BY:
Engr. M.RAFFEH

DATE:
Aug 2021

ELECTRICAL ENGINEER:
Engr. Ghulam Daraz Shaikh


APPROVED BY:
SAYED ALI ABBAS GILLANI

DRAWING NO:
0249/PARKS/09

REV:
4

SCALE (A3):
N.T.S


SHEET:
0/0

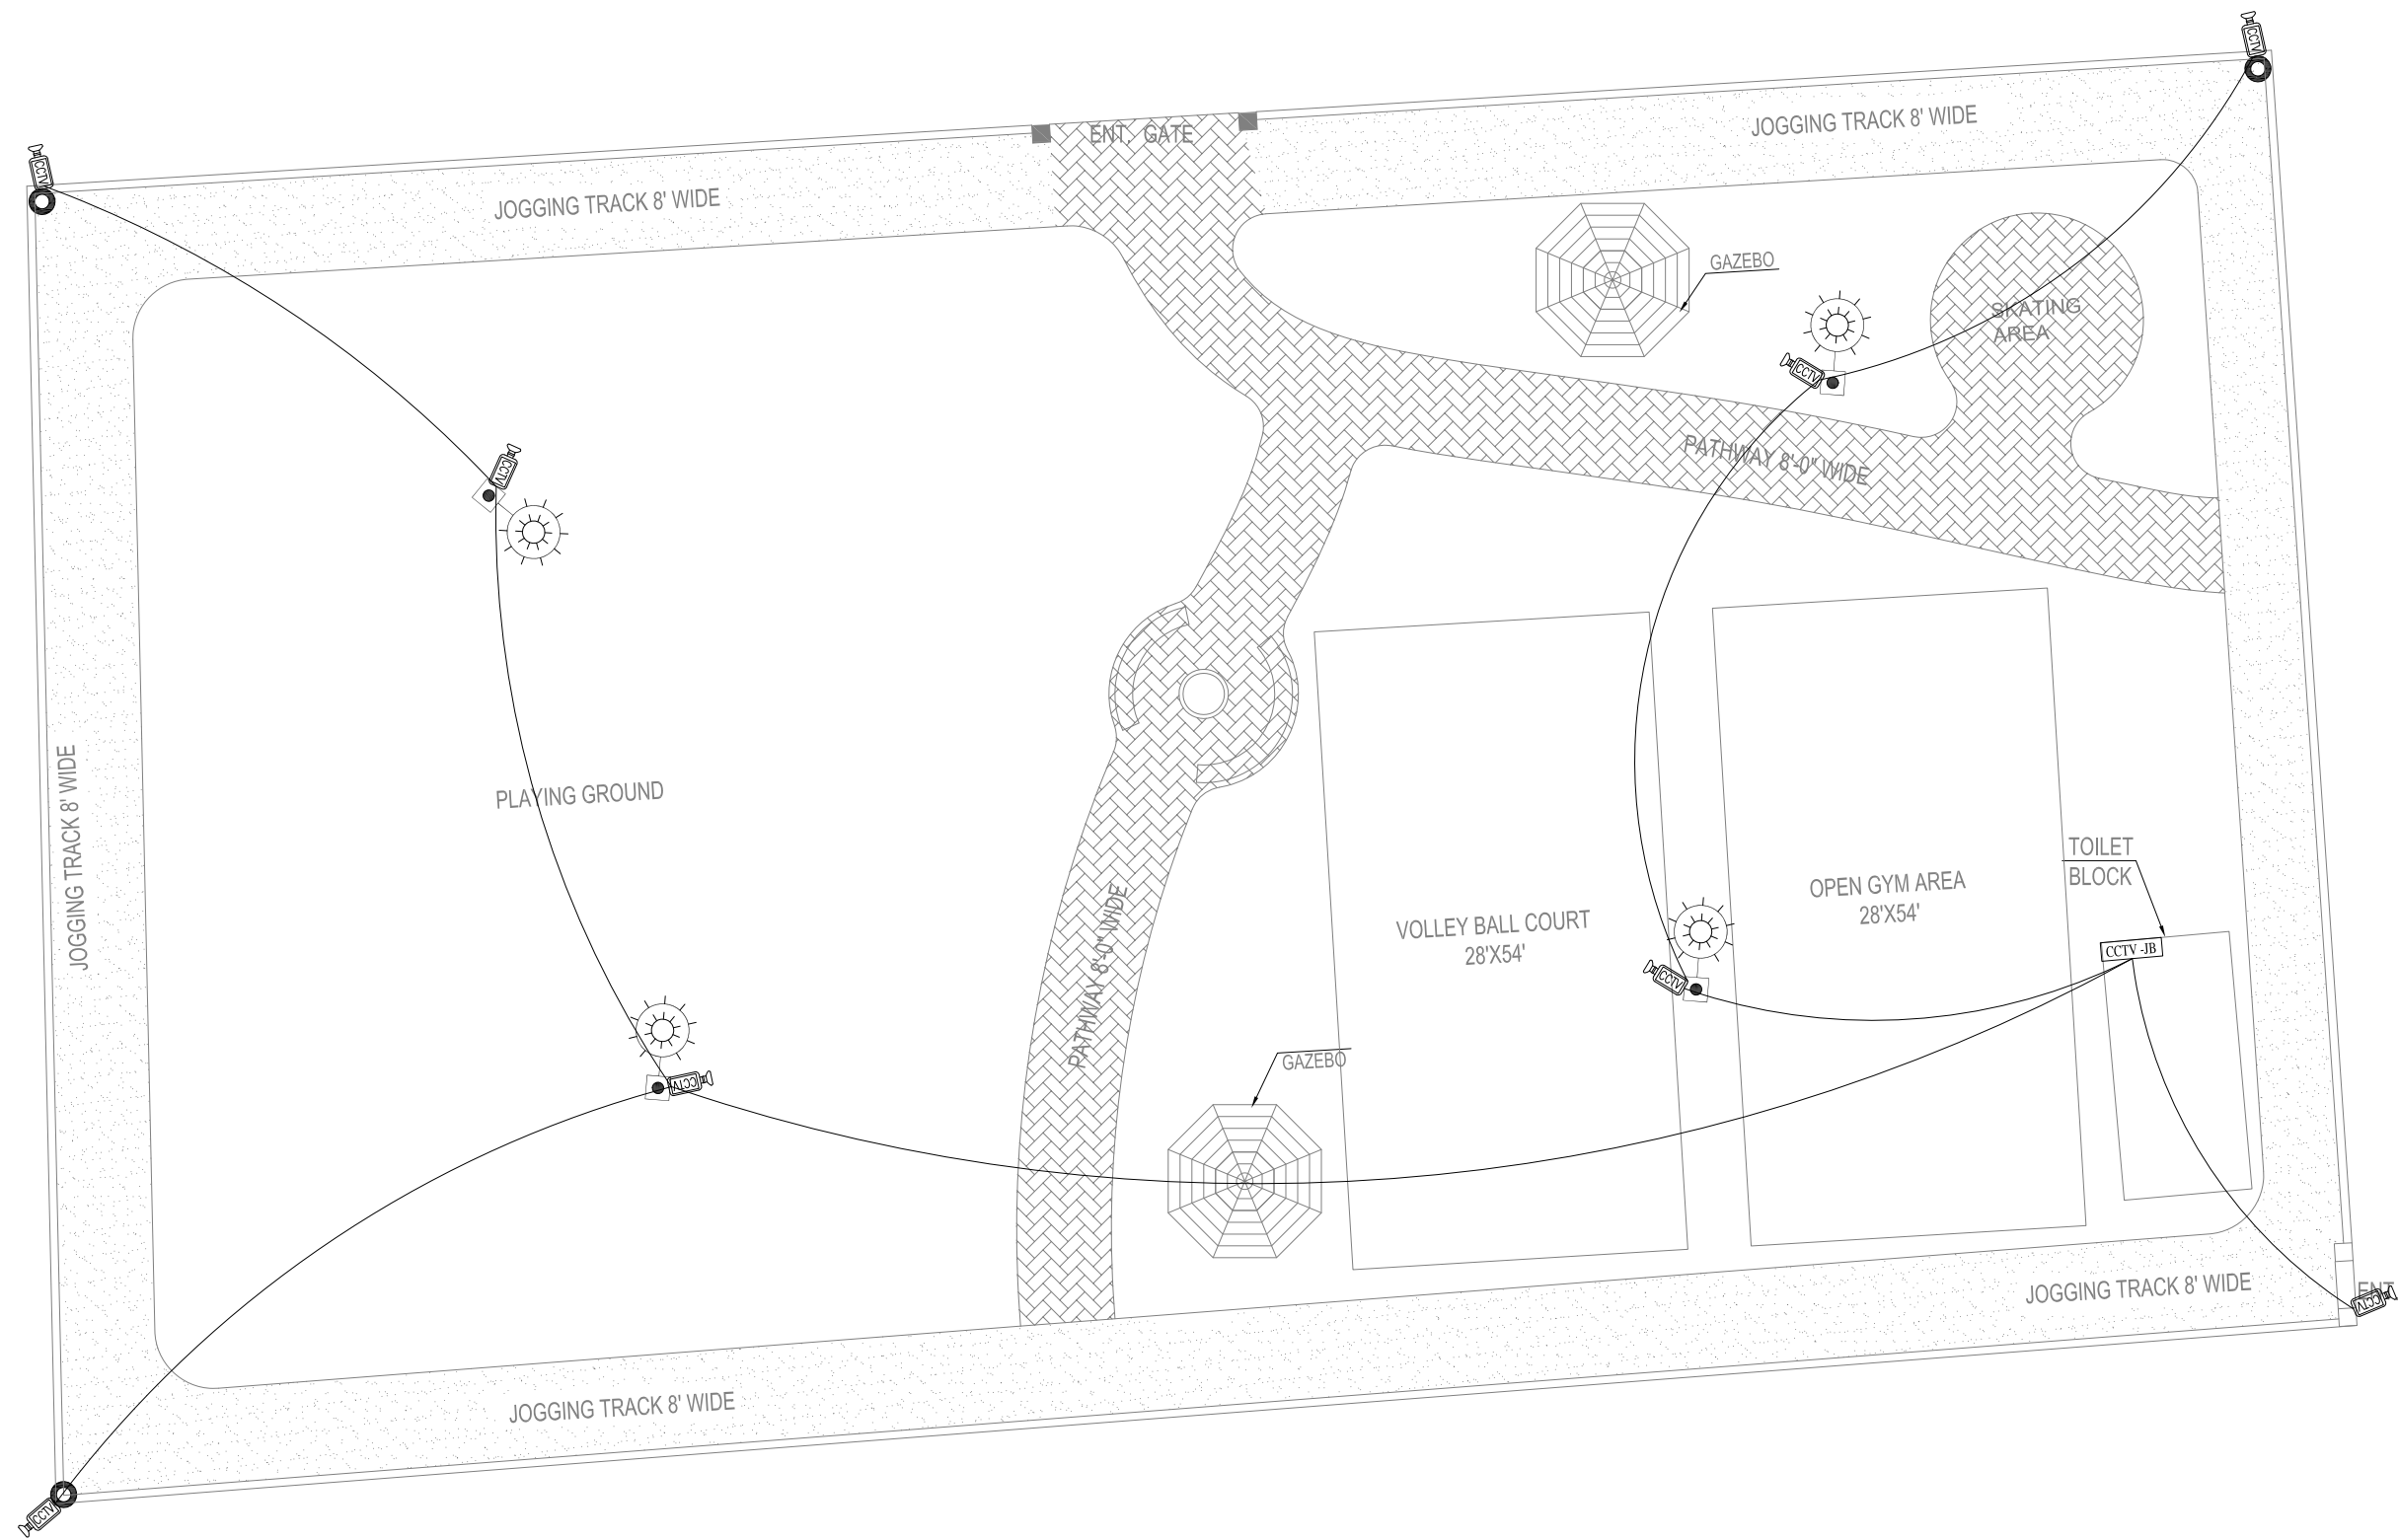

CLIENT:



 PROJECT
IMPLEMENTATION
UNIT (PIU) KNIP



CONSULTANTS:

**G3 ENGINEERING
CONSULTANTS (PVT) LTD.**
House No.57-M Gulberg-II, Lahore, Pakistan

Tel : (92-42) 35441641, 35441642
Fax : (92-42) 35441645
E-mail : info@g3ec.com
URL : www.g3ec.com

PROJECT:

REHABILITATION & UP GRADATION OF
BOAT BASIN TO SCHON CHOWRANGI
WITH PEDESTRIAN TRAIL

NOTES:

1. ALL DIMENSIONS ARE IN FEET UNLESS OTHERWISE SPECIFIED.
2. THIS DRAWING IS AN INTELLECTUAL PROPERTY OF G3 ENGINEERING CONSULTANTS (PVT.) LTD. AND CANNOT BE REPRINTED OR REPRODUCED WITHOUT PRIOR APPROVAL OF G3.

REVISIONS:

No.	DESCRIPTION	DATE

TENDER DRAWINGS

DRAWING TITLE:

ST-5
CCTV
LAYOUT PLAN

DRAWN BY:
Engr. M.RAFFEH

DATE:
Aug 2021

ELECTRICAL ENGINEER:
Engr. Ghulam Daraz Shaikh


APPROVED BY:
SAYED ALI ABBAS GILLANI

DRAWING NO:
0249/PARKS/10

REV:
4

SCALE (A3):
N.T.S

SHEET:
0/0

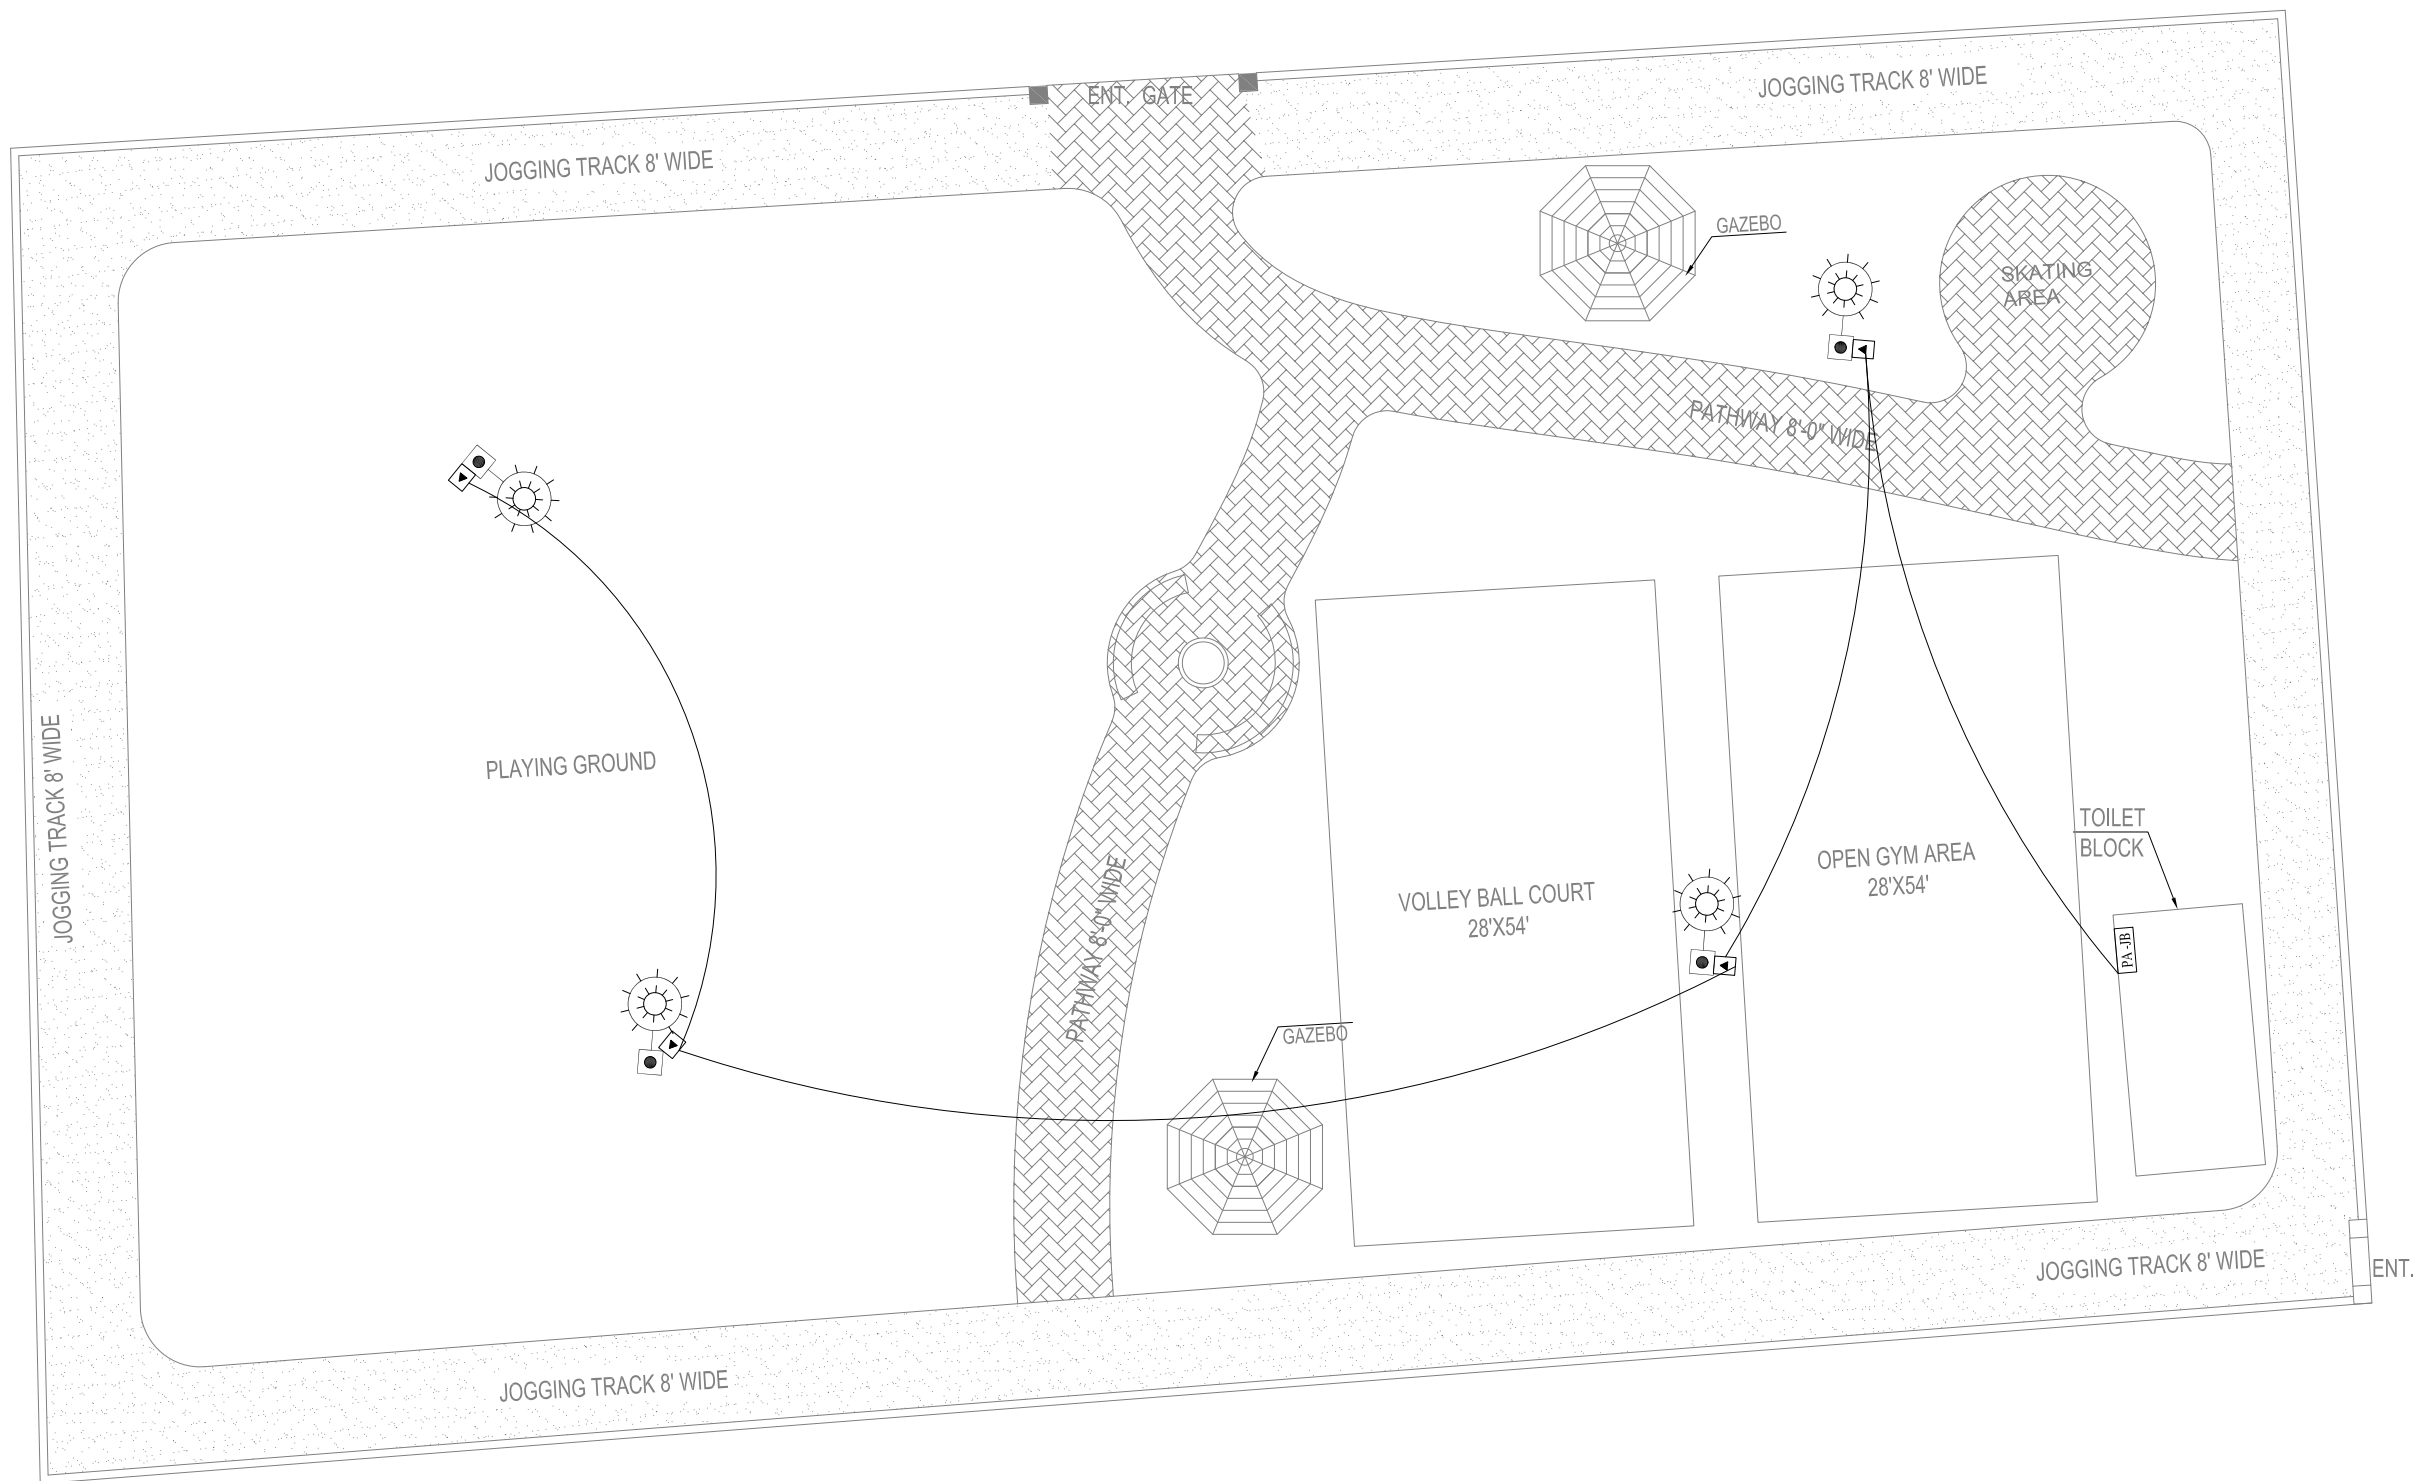

CLIENT:



PROJECT
IMPLEMENTATION
UNIT (PIU) KNIP



CONSULTANTS:

**G3 ENGINEERING
CONSULTANTS (PVT) LTD.**
House No.57-M Gulberg-II, Lahore, Pakistan



Tel : (92-42) 35441641, 35441642
Fax : (92-42) 35441645
E-mail : info@g3ec.com
URL : www.g3ec.com

PROJECT:

REHABILITATION & UP GRADATION OF
BOAT BASIN TO SCHON CHOWRANGI
WITH PEDESTRIAN TRAIL

NOTES:

1. ALL DIMENSIONS ARE IN FEET UNLESS OTHERWISE SPECIFIED.
2. THIS DRAWING IS AN INTELLECTUAL PROPERTY OF G3 ENGINEERING CONSULTANTS (PVT.) LTD. AND CANNOT BE REPRINTED OR REPRODUCED WITHOUT PRIOR APPROVAL OF G3.

REVISIONS:

No.	DESCRIPTION	DATE

TENDER DRAWINGS

DRAWING TITLE:

**ST-5
PUBLIC ADDRESS
SYSTEM
LAYOUT PLAN**

DRAWN BY: Engr. M.RAFFEH DATE: Aug 2021

ELECTRICAL ENGINEER:
Engr. Ghulam Daraz Shaikh

APPROVED BY:
SAYED ALI ABBAS GILLANI

DRAWING NO: 0249/PARKS/11 REV: 4

SCALE (A3): N.T.S SHEET: 0/0

CLIENT:



PROJECT
IMPLEMENTATION
UNIT (PIU) KNIP



CONSULTANTS:

G3 ENGINEERING
CONSULTANTS (PVT.) LTD.
House No.57-M Gulberg-II, Lahore, Pakistan

Tel : (92-42) 35441641, 35441642
Fax : (92-42) 35441645
E-mail : info@g3ec.com
URL : www.g3ec.com

PROJECT:

REHABILITATION & UP GRADATION OF
BOAT BASIN TO SCHON CHOWRANGI
WITH PEDESTRIAN TRAIL

NOTES:

1. ALL DIMENSIONS ARE IN FEET UNLESS OTHERWISE SPECIFIED.
2. THIS DRAWING IS AN INTELLECTUAL PROPERTY OF G3 ENGINEERING CONSULTANTS (PVT.) LTD. AND CANNOT BE REPRINTED OR REPRODUCED WITHOUT PRIOR APPROVAL OF G3.

REVISIONS:

No.	DESCRIPTION	DATE

TENDER DRAWINGS

DRAWING TITLE:

ST-06
ILLUMINATION
LAYOUT PLAN

DRAWN BY:
Engr. M.RAFFEH

DATE:
Aug 2021

ELECTRICAL ENGINEER:
Engr. Ghulam Daraz Shaikh


APPROVED BY:
SAYED ALI ABBAS GILLANI


DRAWING NO:
0249/PARKS/12

REV:
4

SCALE (A3):
N.T.S

SHEET:
0/0

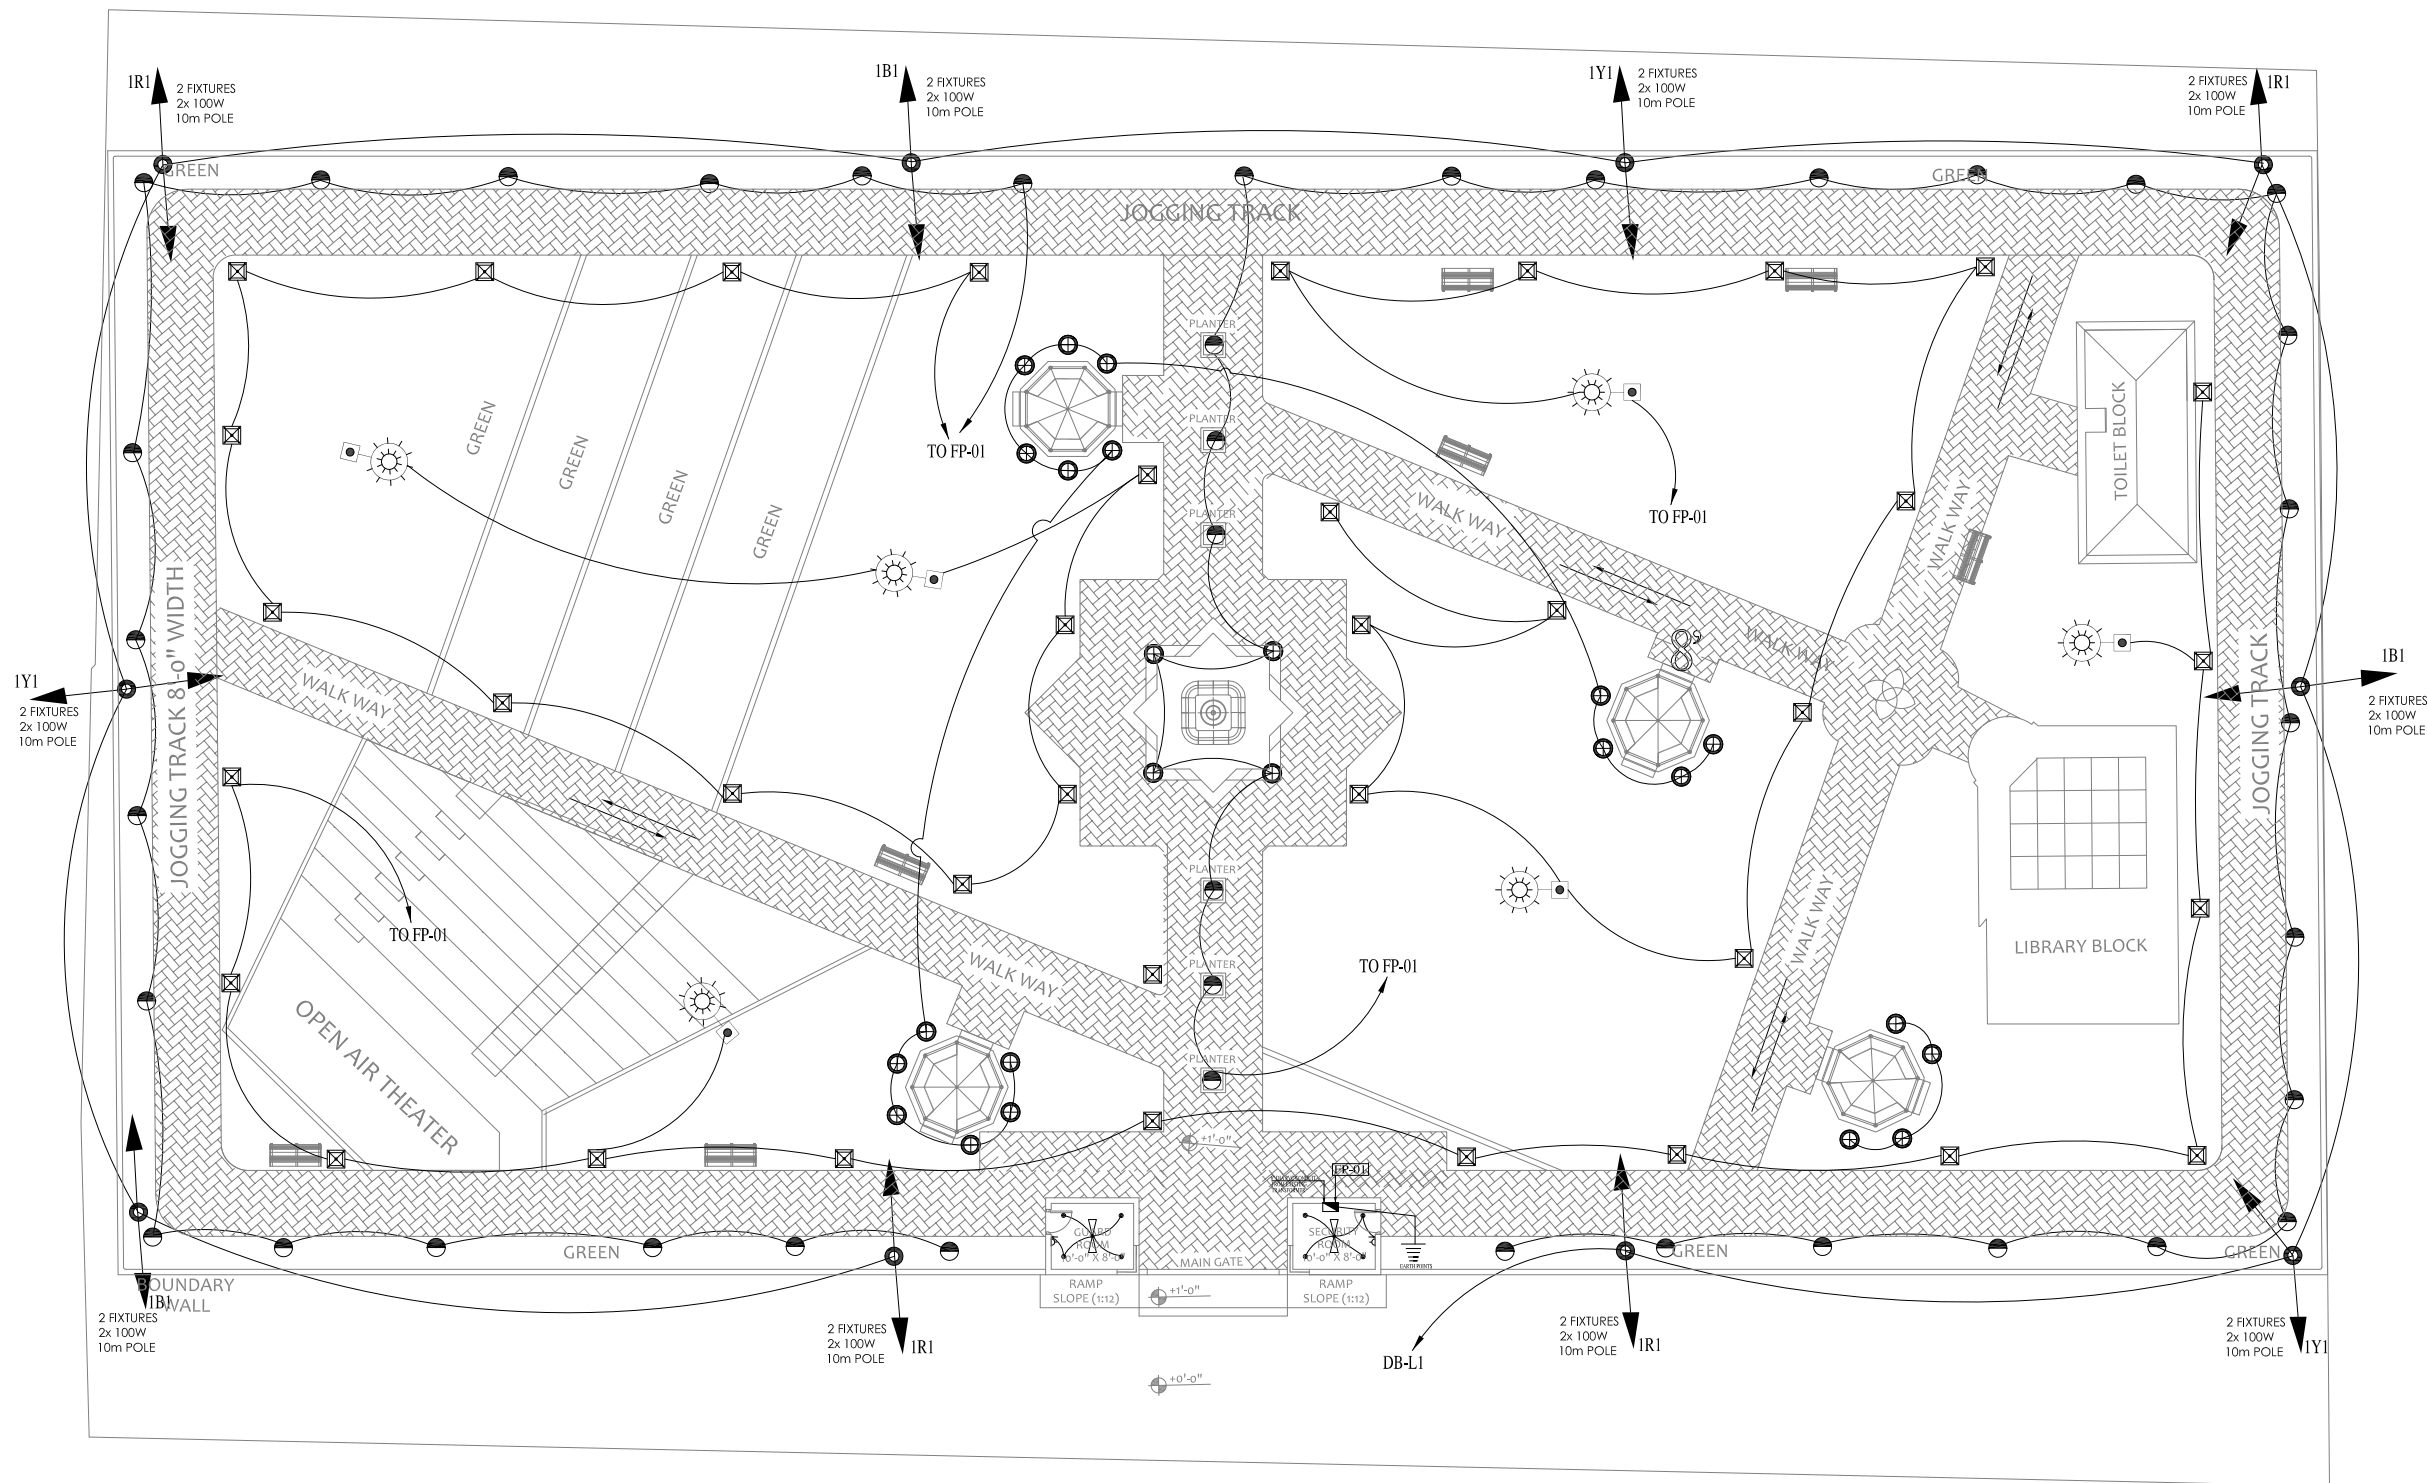

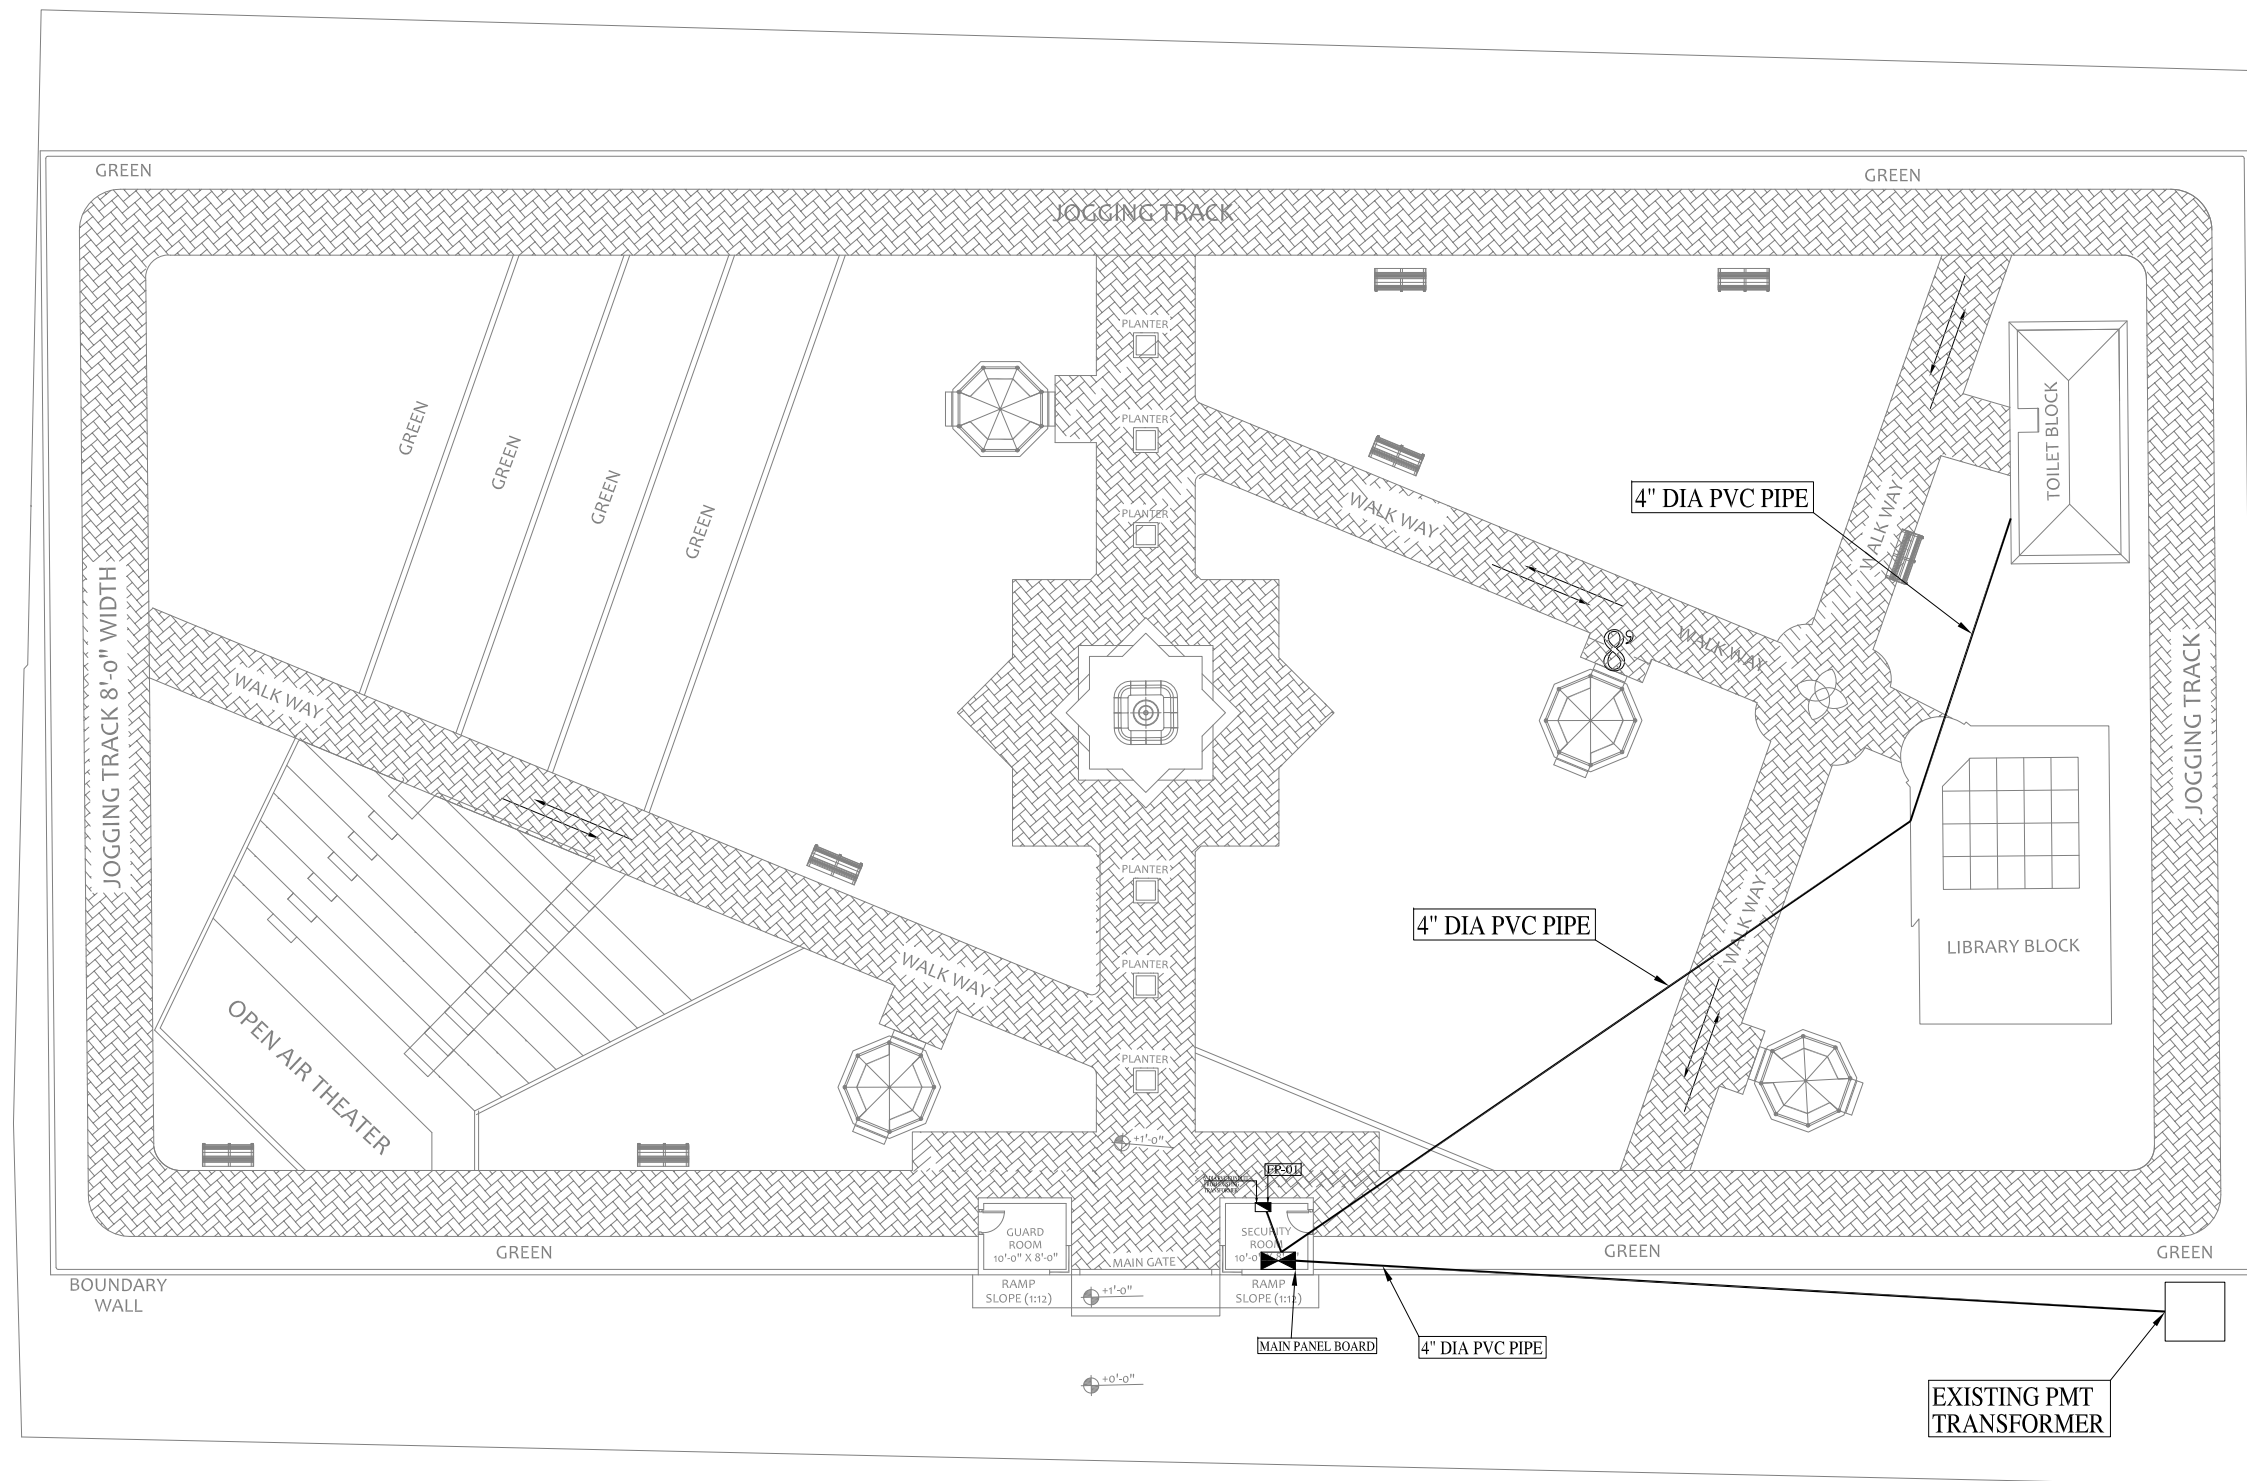

CLIENT:



PROJECT
IMPLEMENTATION
UNIT (PIU) KNIP



CONSULTANTS:

**G3 ENGINEERING
CONSULTANTS (PVT) LTD.**
House No.57-M Gulberg-II, Lahore, Pakistan

Tel : (92-42) 35441641, 35441642
Fax : (92-42) 35441645
E-mail : info@g3ec.com
URL : www.g3ec.com

PROJECT:

REHABILITATION & UP GRADATION OF
BOAT BASIN TO SCHON CHOWRANGI
WITH PEDESTRIAN TRAIL

NOTES:

1. ALL DIMENSIONS ARE IN FEET UNLESS OTHERWISE SPECIFIED.
2. THIS DRAWING IS AN INTELLECTUAL PROPERTY OF G3 ENGINEERING CONSULTANTS (PVT.) LTD. AND CANNOT BE REPRINTED OR REPRODUCED WITHOUT PRIOR APPROVAL OF G3.

REVISIONS:

No.	DESCRIPTION	DATE

TENDER DRAWINGS

DRAWING TITLE:

**ST-06
POWER DISTRIBUTION
LAYOUT PLAN**

DRAWN BY:
Engr. M.RAFFEH

DATE:
Aug 2021

ELECTRICAL ENGINEER:
Engr. Ghulam Daraz Shaikh


APPROVED BY:
SAYED ALI ABBAS GILLANI

DRAWING NO:
0249/PARKS/13

REV:
4

SCALE (A3):
N.T.S

SHEET:
0/0

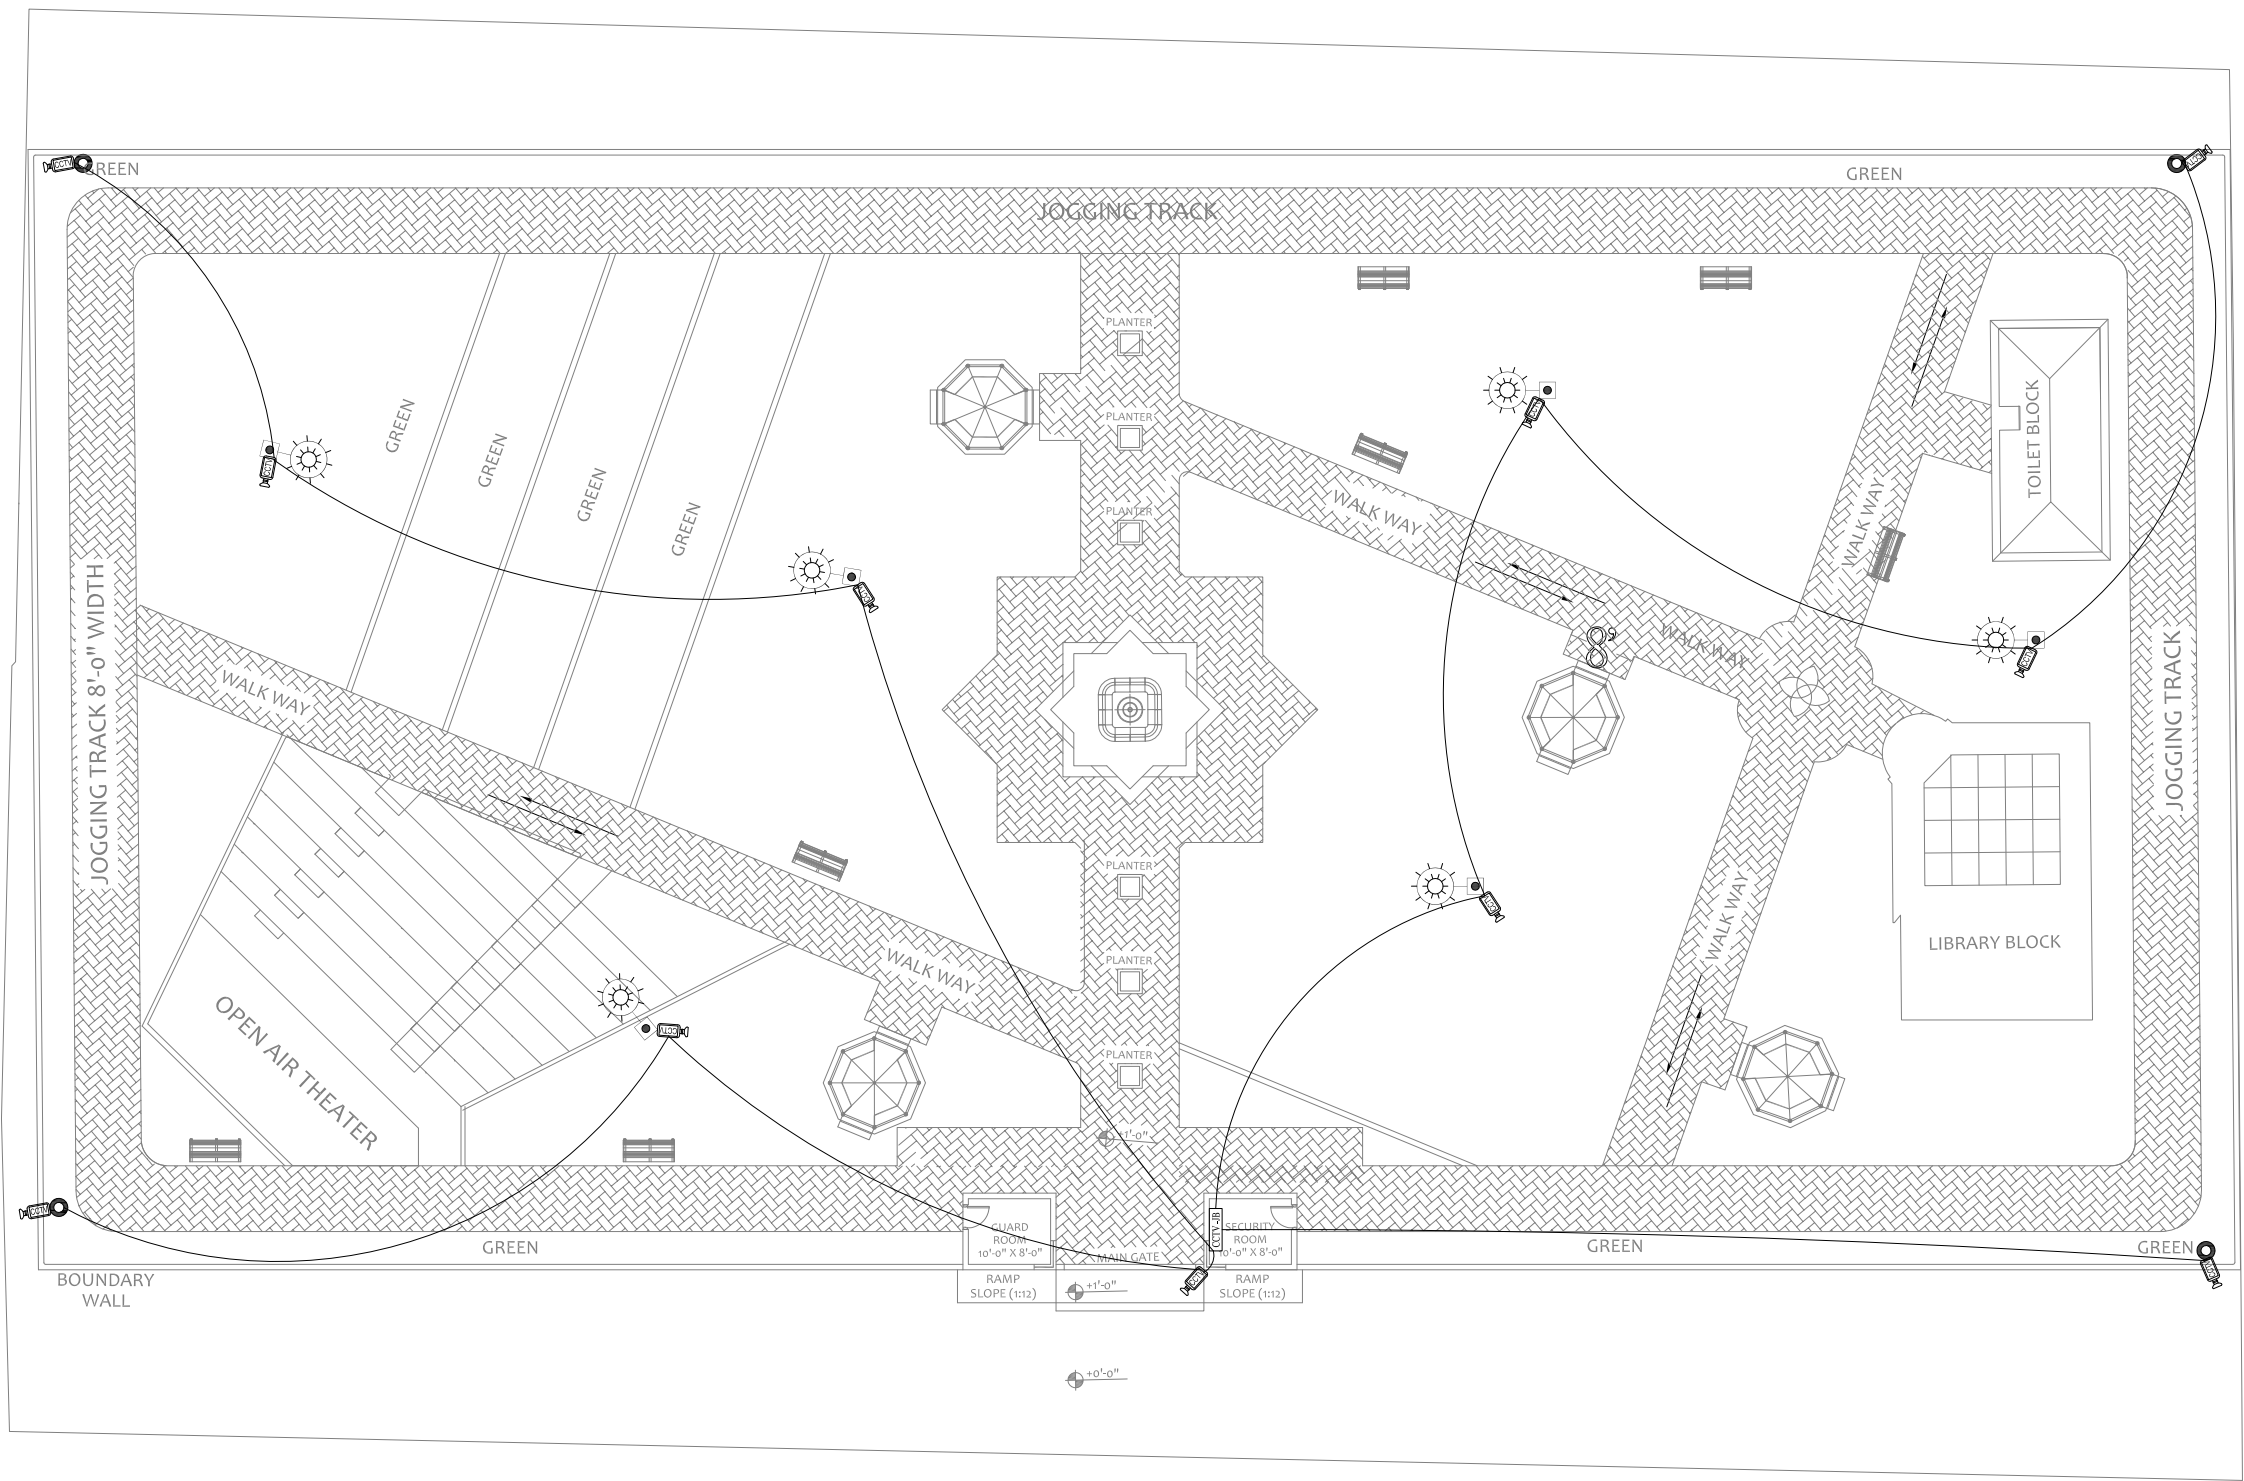

CLIENT:



PROJECT
IMPLEMENTATION
UNIT (PIU) KNIP



CONSULTANTS:
**G3 ENGINEERING
CONSULTANTS (PVT) LTD.**
House No.57-M Gulberg-II, Lahore, Pakistan
Tel : (92-42) 35441641, 35441642
Fax : (92-42) 35441645
E-mail : info@g3ec.com
URL : www.g3ec.com

PROJECT:

REHABILITATION & UP GRADATION OF
BOAT BASIN TO SCHON CHOWRANGI
WITH PEDESTRIAN TRAIL

NOTES:

1. ALL DIMENSIONS ARE IN FEET UNLESS OTHERWISE SPECIFIED.
2. THIS DRAWING IS AN INTELLECTUAL PROPERTY OF G3 ENGINEERING CONSULTANTS (PVT.) LTD. AND CANNOT BE REPRINTED OR REPRODUCED WITHOUT PRIOR APPROVAL OF G3.

REVISIONS:

No.	DESCRIPTION	DATE

TENDER DRAWINGS

DRAWING TITLE:

ST-06
CCTV
LAYOUT PLAN

DRAWN BY:
Engr. M.RAFFEH

DATE:
Aug 2021

ELECTRICAL ENGINEER:
Engr. Ghulam Daraz Shaikh


APPROVED BY:
SAYED ALI ABBAS GILLANI

DRAWING NO:
0249/PARKS/14

REV:
4

SCALE (A3):
N.T.S

SHEET:
0/0

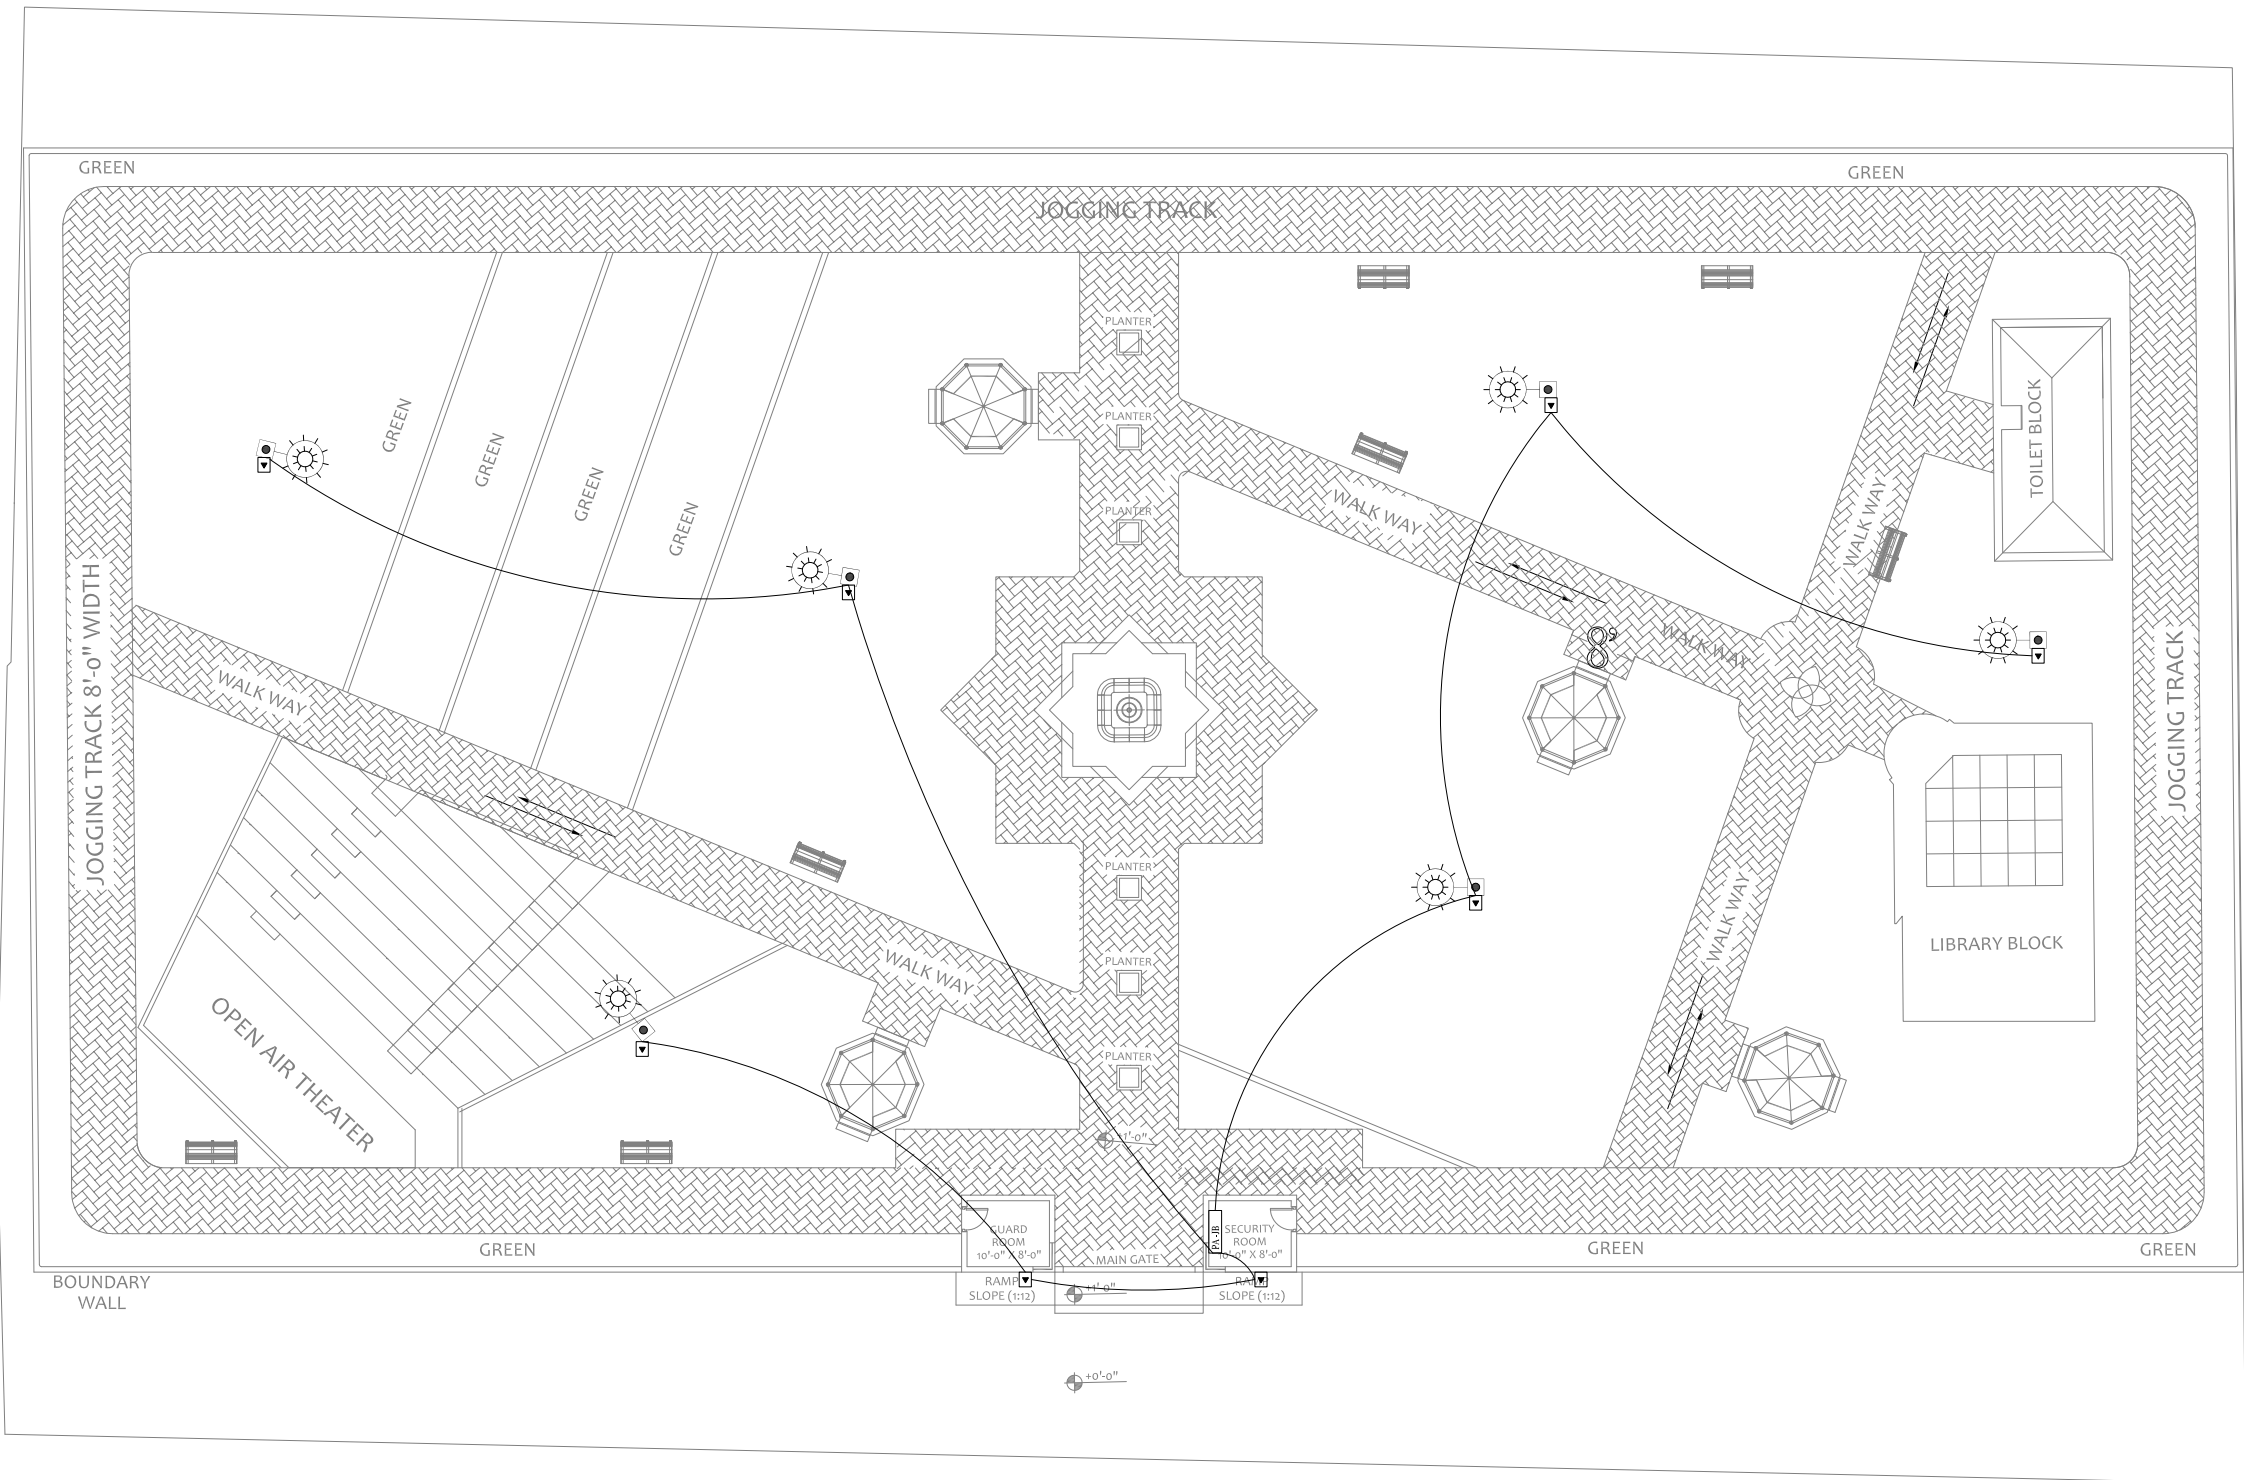

CLIENT:



PROJECT
IMPLEMENTATION
UNIT (PIU) KNIP



CONSULTANTS:
**G3 ENGINEERING
CONSULTANTS (PVT) LTD.**
House No.57-M Gulberg-II, Lahore, Pakistan
Tel : (92-42) 35441641, 35441642
Fax : (92-42) 35441645
E-mail : info@g3ec.com
URL : www.g3ec.com

PROJECT:

REHABILITATION & UP GRADATION OF
BOAT BASIN TO SCHON CHOWRANGI
WITH PEDESTRIAN TRAIL

NOTES:

1. ALL DIMENSIONS ARE IN FEET UNLESS OTHERWISE SPECIFIED.
2. THIS DRAWING IS AN INTELLECTUAL PROPERTY OF G3 ENGINEERING CONSULTANTS (PVT.) LTD. AND CANNOT BE REPRINTED OR REPRODUCED WITHOUT PRIOR APPROVAL OF G3.


REVISIONS:

No.	DESCRIPTION	DATE

TENDER DRAWINGS

DRAWING TITLE:
**ST-06
PUBLIC ADDRESS
SYSTEM
LAYOUT PLAN**

DRAWN BY: Engr. M.RAFFEH	DATE: Aug 2021
ELECTRICAL ENGINEER: Engr. Ghulam Daraz Shaikh	
APPROVED BY: SAYED ALI ABBAS GILLANI	
DRAWING NO: 0249/PARKS/15	REV: 4
SCALE (A3): N.T.S	SHEET: 0/0

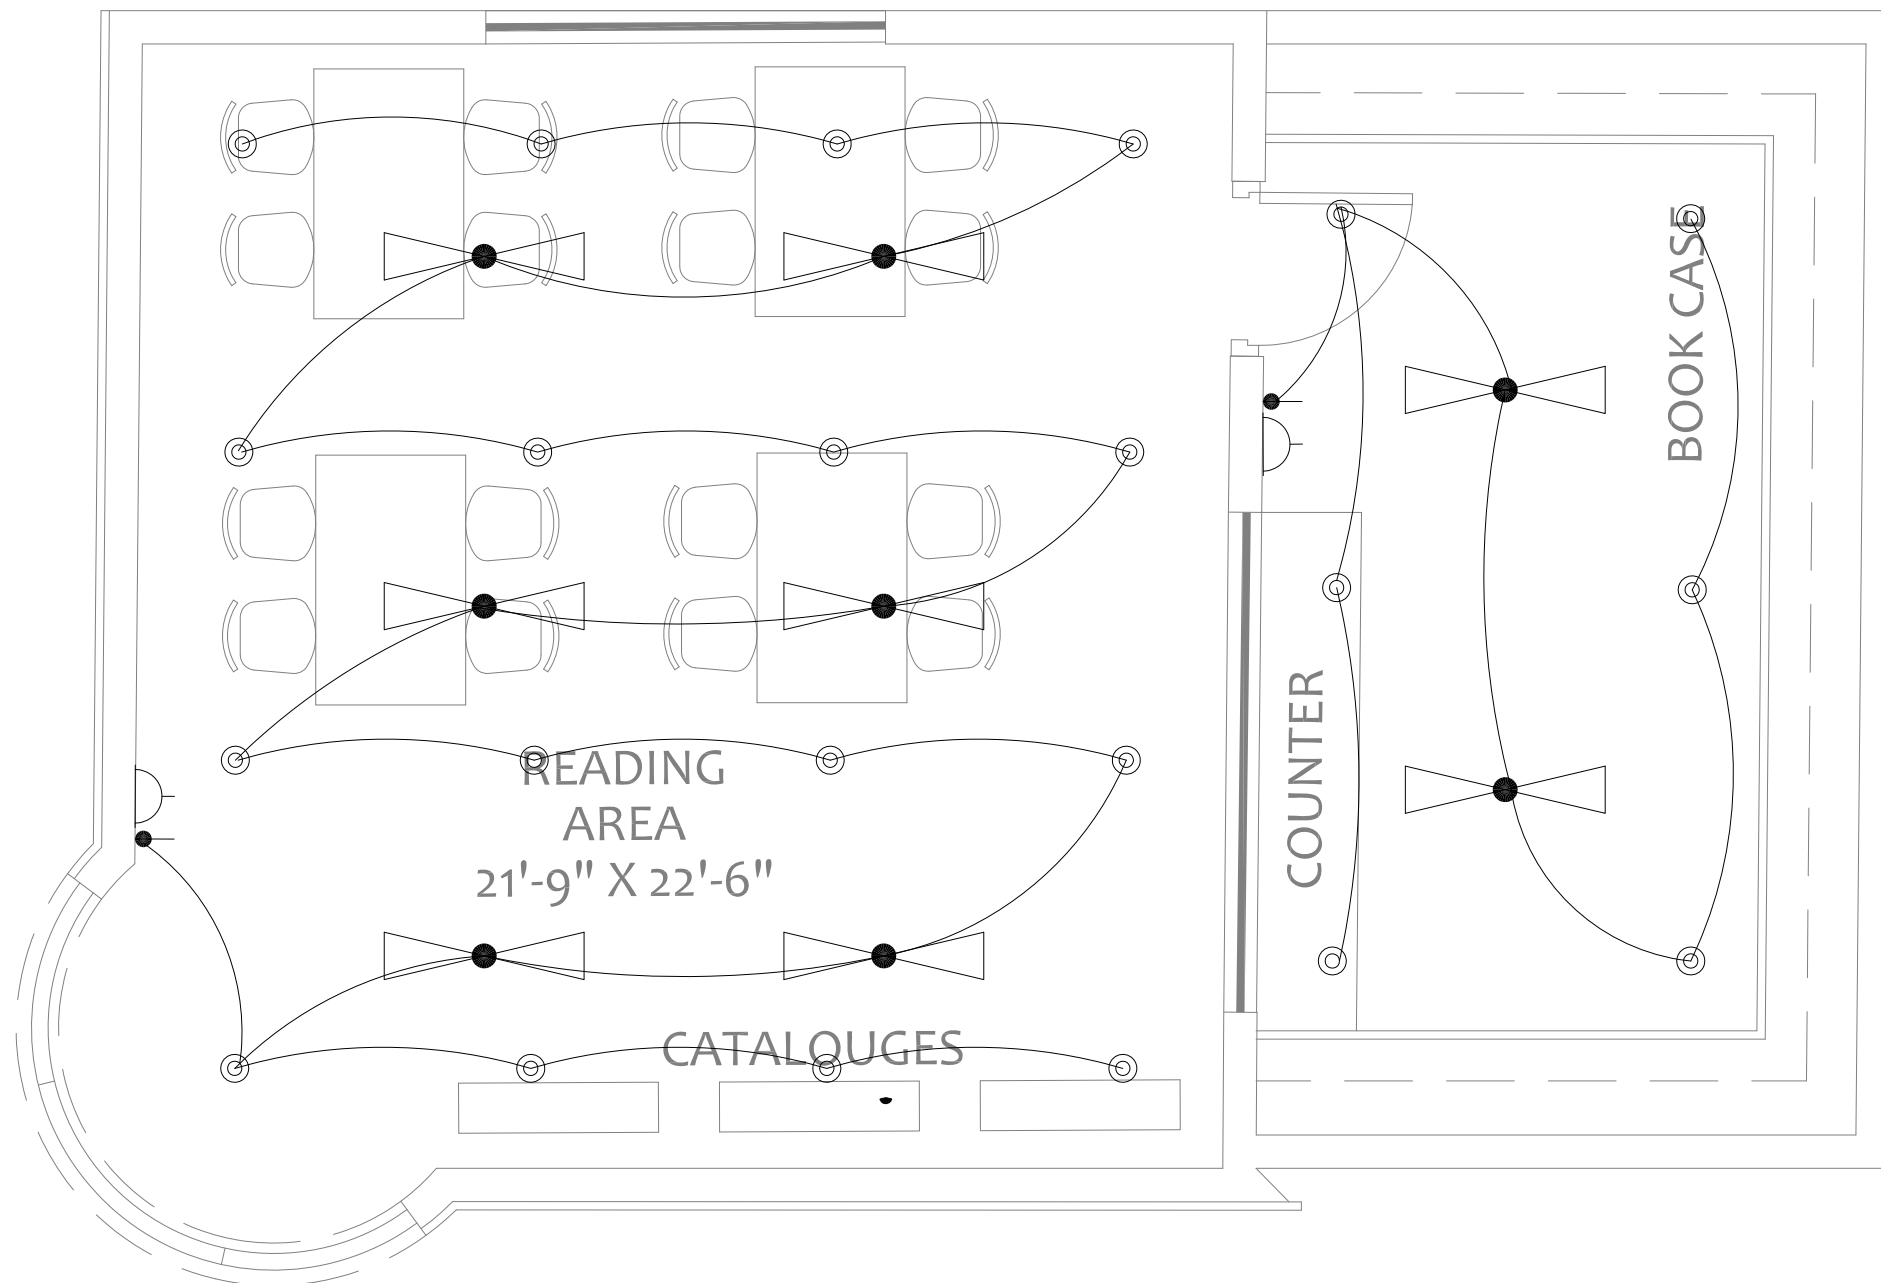

LIBRARY BLOCK
PLAN

CLIENT:



PROJECT
IMPLEMENTATION
UNIT (PIU) KNIP



CONSULTANTS:

G3 ENGINEERING
CONSULTANTS (PVT.) LTD.
House No.57-M Gulberg-III, Lahore, Pakistan



Tel : (92-42) 35441641, 35441642
Fax : (92-42) 35441645
E-mail : info@g3ec.com
URL : www.g3ec.com

PROJECT:

REHABILITATION & UP GRADATION OF
BOAT BASIN TO SCHON CHOWRANGI
WITH PEDESTRIAN TRAIL

NOTES:

1. ALL DIMENSIONS ARE IN FEET UNLESS OTHERWISE SPECIFIED.
2. THIS DRAWING IS AN INTELLECTUAL PROPERTY OF G3 ENGINEERING CONSULTANTS (PVT.) LTD. AND CANNOT BE REPRINTED OR REPRODUCED WITHOUT PRIOR APPROVAL OF G3.

REVISIONS:

No.	DESCRIPTION	DATE

TENDER DRAWINGS

DRAWING TITLE:
ST-06
(LIBRARY BLOCK)
ILLUMINATION
LAYOUT PLAN

DRAWN BY: Engr. M.RAFFEH	DATE: Aug 2021
ELECTRICAL ENGINEER: Engr. Ghulam Daraz Shaikh	
APPROVED BY: SAYED ALI ABBAS GILLANI	
DRAWING NO: 0249/PARKS/16	REV: 4
SCALE (A3): N.T.S	SHEET: 0/0

CLIENT:



PROJECT
IMPLEMENTATION
UNIT (PIU) KNIP



CONSULTANTS:
**G3 ENGINEERING
CONSULTANTS (PVT) LTD.**
House No.57-M Gulberg-II, Lahore, Pakistan
Tel : (92-42) 35441641, 35441642
Fax : (92-42) 35441645
E-mail : info@g3ec.com
URL : www.g3ec.com

PROJECT:

REHABILITATION & UP GRADATION OF
BOAT BASIN TO SCHON CHOWRANGI
WITH PEDESTRIAN TRAIL

NOTES:

1. ALL DIMENSIONS ARE IN FEET UNLESS OTHERWISE SPECIFIED.
2. THIS DRAWING IS AN INTELLECTUAL PROPERTY OF G3 ENGINEERING CONSULTANTS (PVT.) LTD. AND CANNOT BE REPRINTED OR REPRODUCED WITHOUT PRIOR APPROVAL OF G3.

REVISIONS:

No.	DESCRIPTION	DATE

TENDER DRAWINGS

DRAWING TITLE:

ST-08
ILLUMINATION
LAYOUT PLAN

DRAWN BY:
Engr. M.RAFFEH

DATE:
Aug 2021

ELECTRICAL ENGINEER:
Engr. Ghulam Daraz Shaikh


APPROVED BY:
SAYED ALI ABBAS GILLANI


DRAWING NO:
0249/PARKS/17

REV:
4

SCALE (A3):
N.T.S

SHEET:
0/0

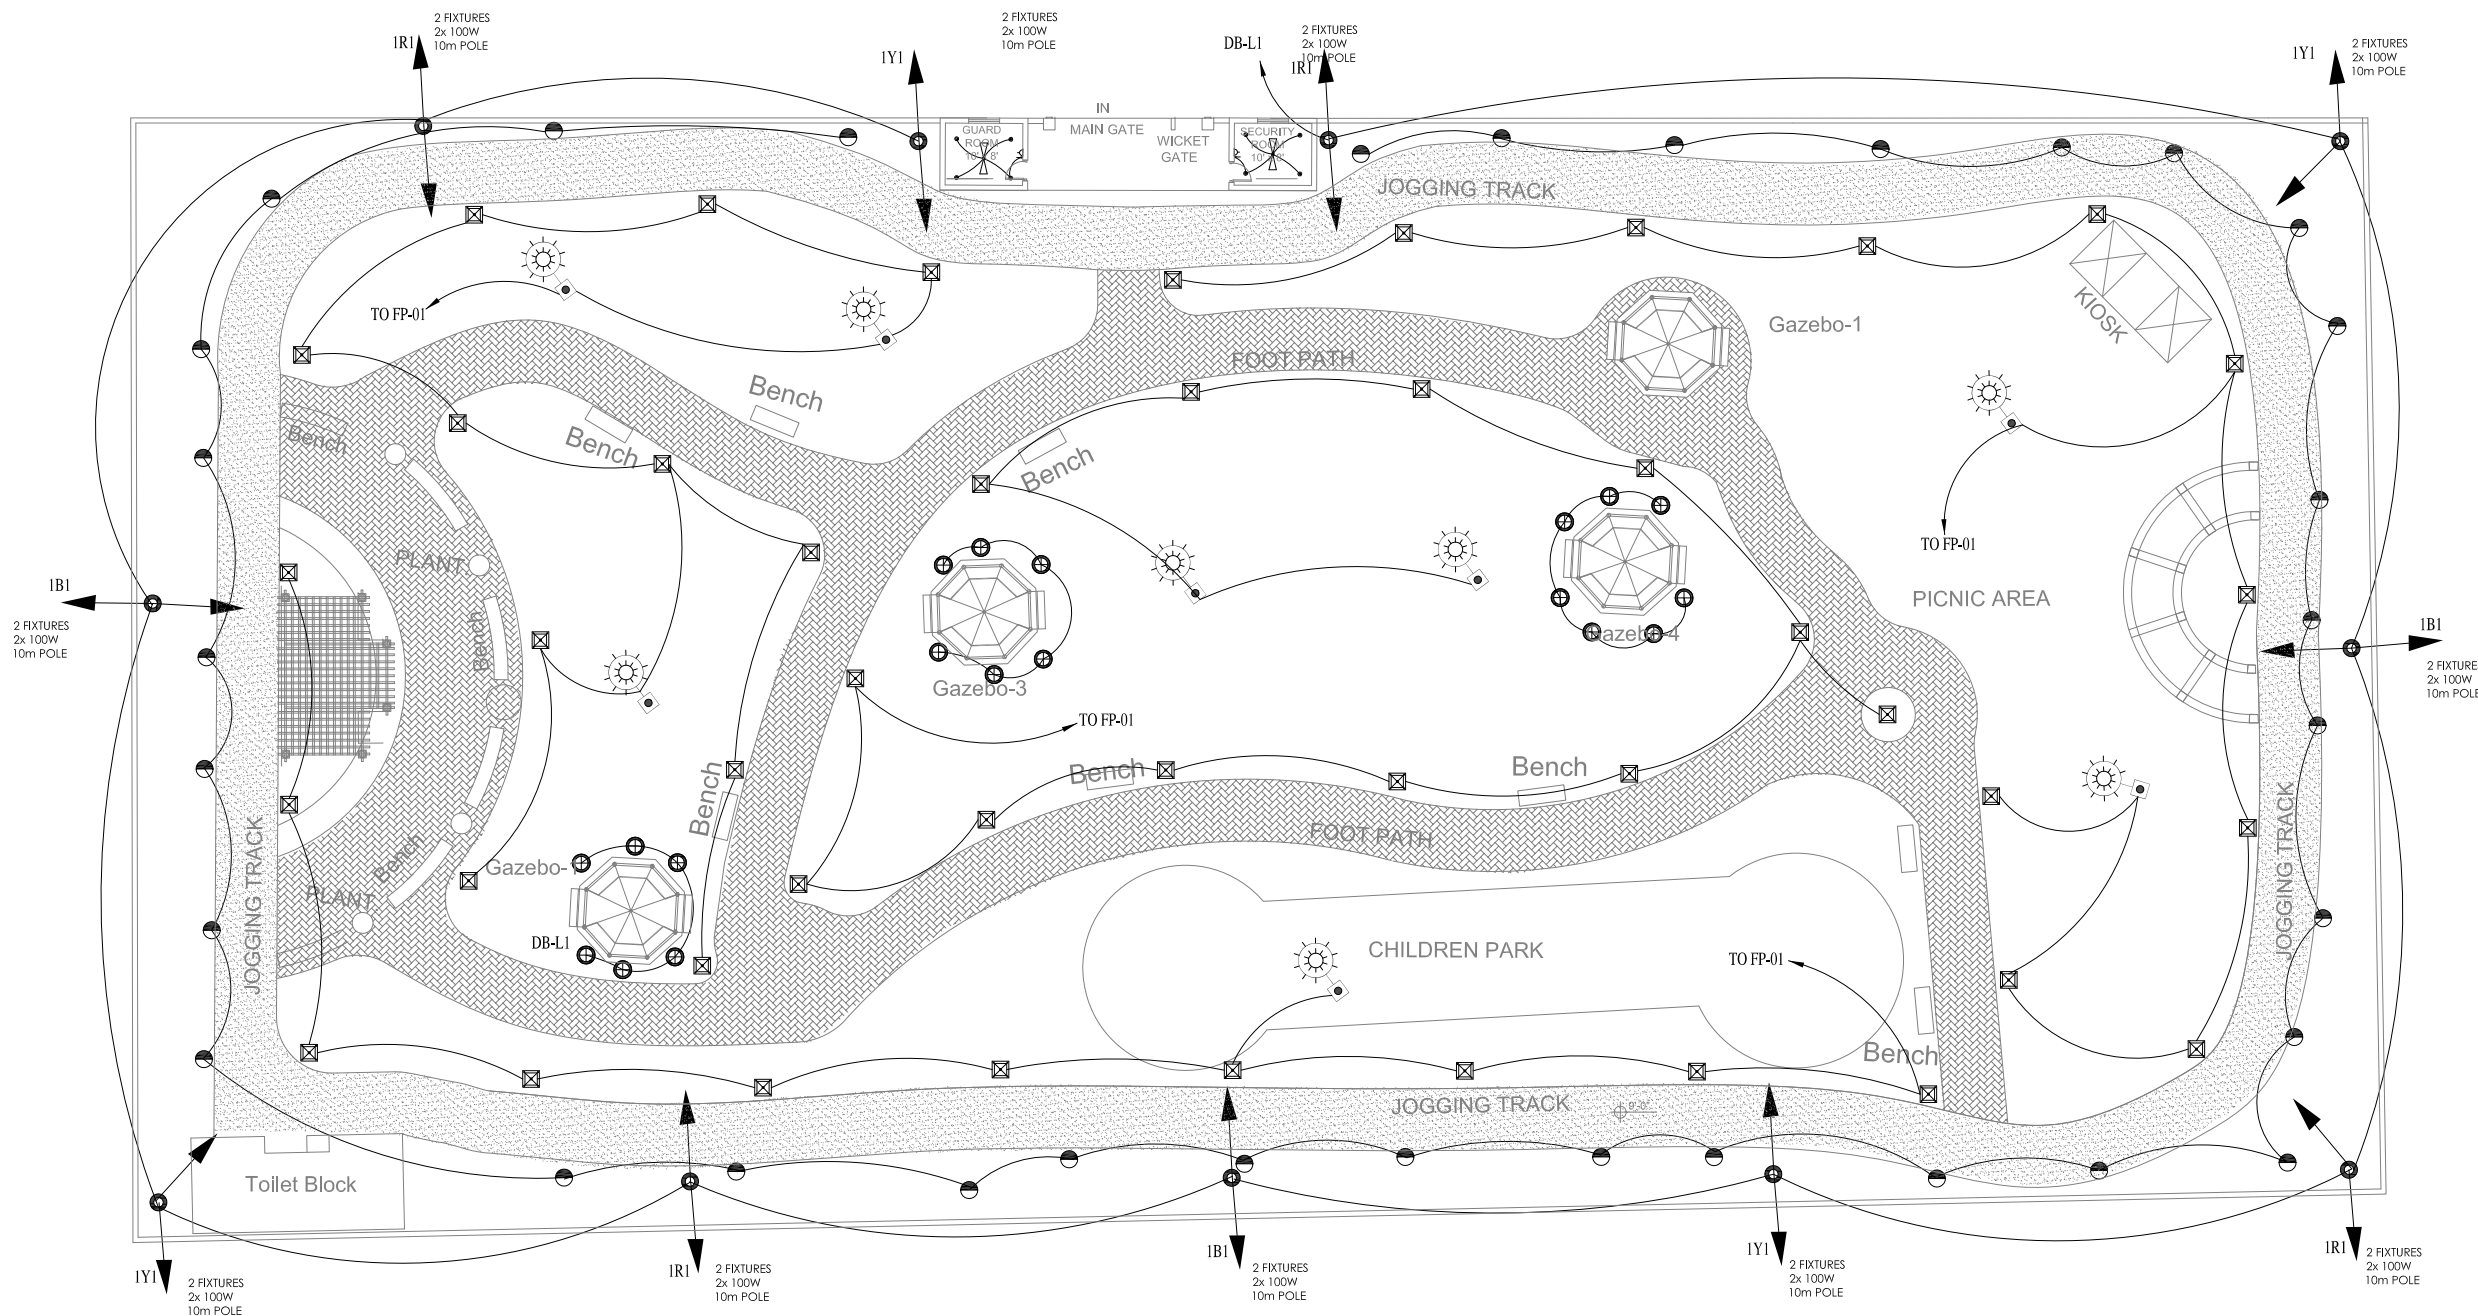

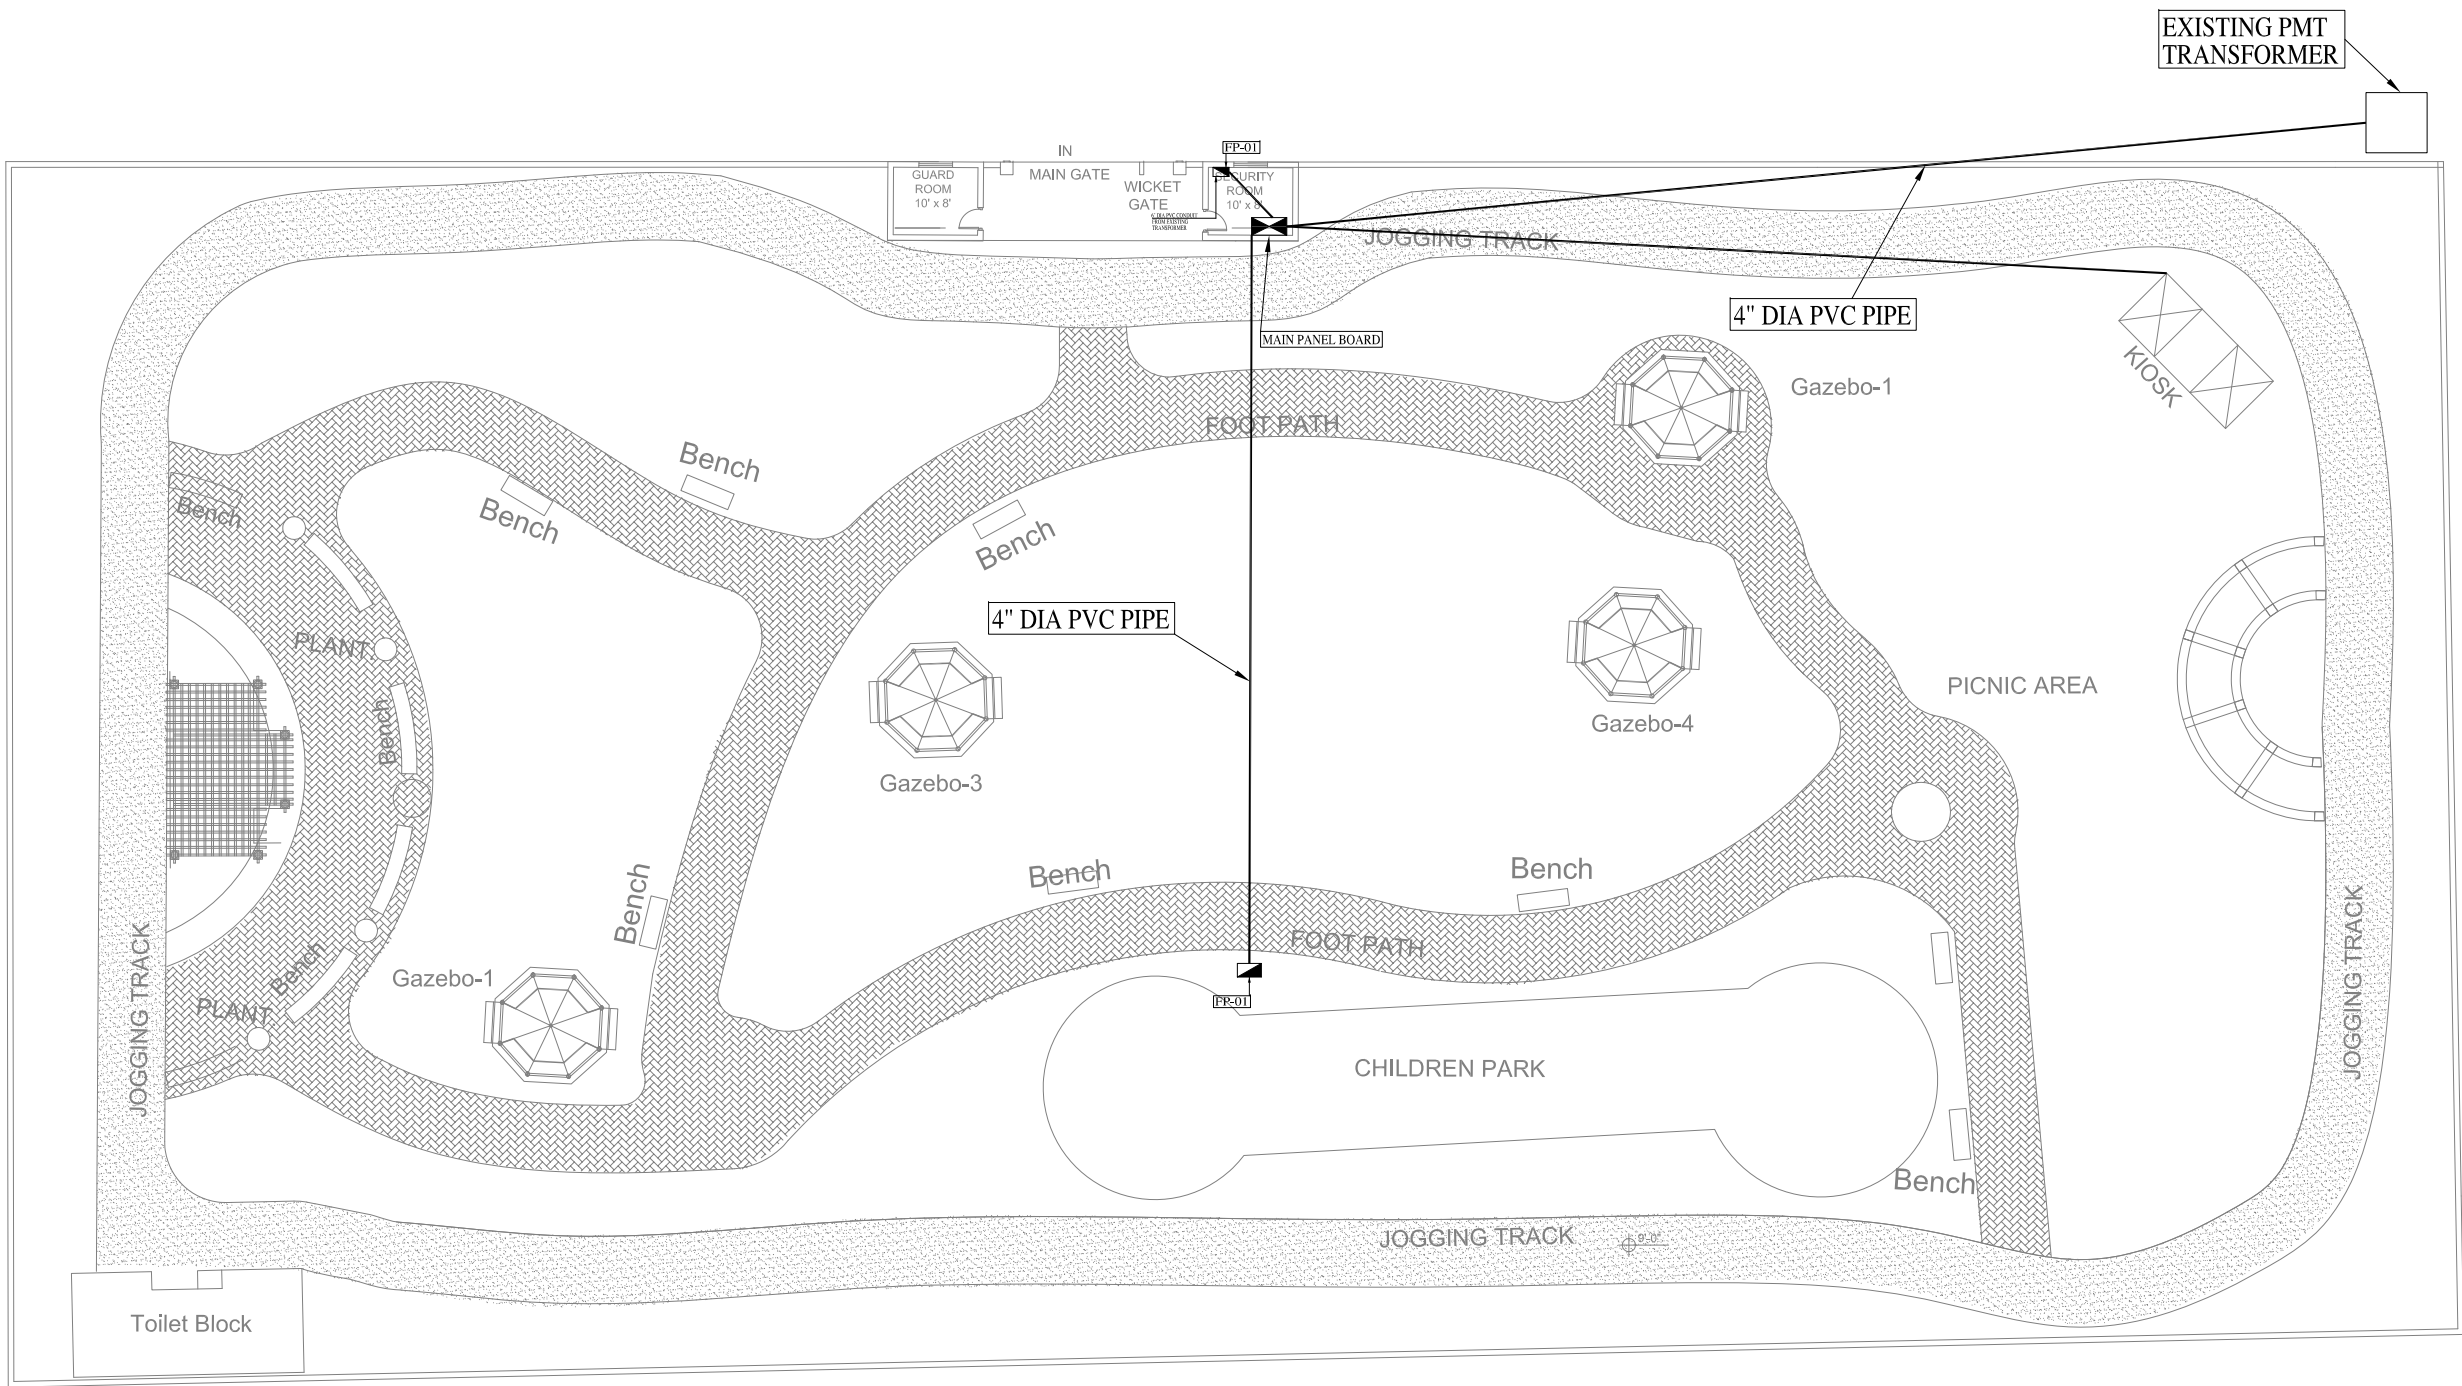

CLIENT:



PROJECT
IMPLEMENTATION
UNIT (PIU) KNIP



CONSULTANTS:

**G3 ENGINEERING
CONSULTANTS (PVT)LTD.**
House No.57-M Gulberg-II, Lahore, Pakistan

Tel : (92-42) 35441641, 35441642
Fax : (92-42) 35441645
E-mail : info@g3ec.com
URL : www.g3ec.com

PROJECT:

REHABILITATION & UP GRADATION OF
BOAT BASIN TO SCHON CHOWRANGI
WITH PEDESTRIAN TRAIL

NOTES:

1. ALL DIMENSIONS ARE IN FEET UNLESS OTHERWISE SPECIFIED.
2. THIS DRAWING IS AN INTELLECTUAL PROPERTY OF G3 ENGINEERING CONSULTANTS (PVT.) LTD. AND CANNOT BE REPRINTED OR REPRODUCED WITHOUT PRIOR APPROVAL OF G3.

REVISIONS:

No.	DESCRIPTION	DATE

TENDER DRAWINGS

DRAWING TITLE:

**ST-08
POWER DISTRIBUTION
LAYOUT PLAN**

DRAWN BY:
Engr. M.RAFFEH

DATE:
Aug 2021

ELECTRICAL ENGINEER:
Engr. Ghulam Daraz Shaikh


APPROVED BY:
SAYED ALI ABBAS GILLANI

DRAWING NO:
0249/PARKS/18

REV:
4

SCALE (A3):
N.T.S

SHEET:
0/0

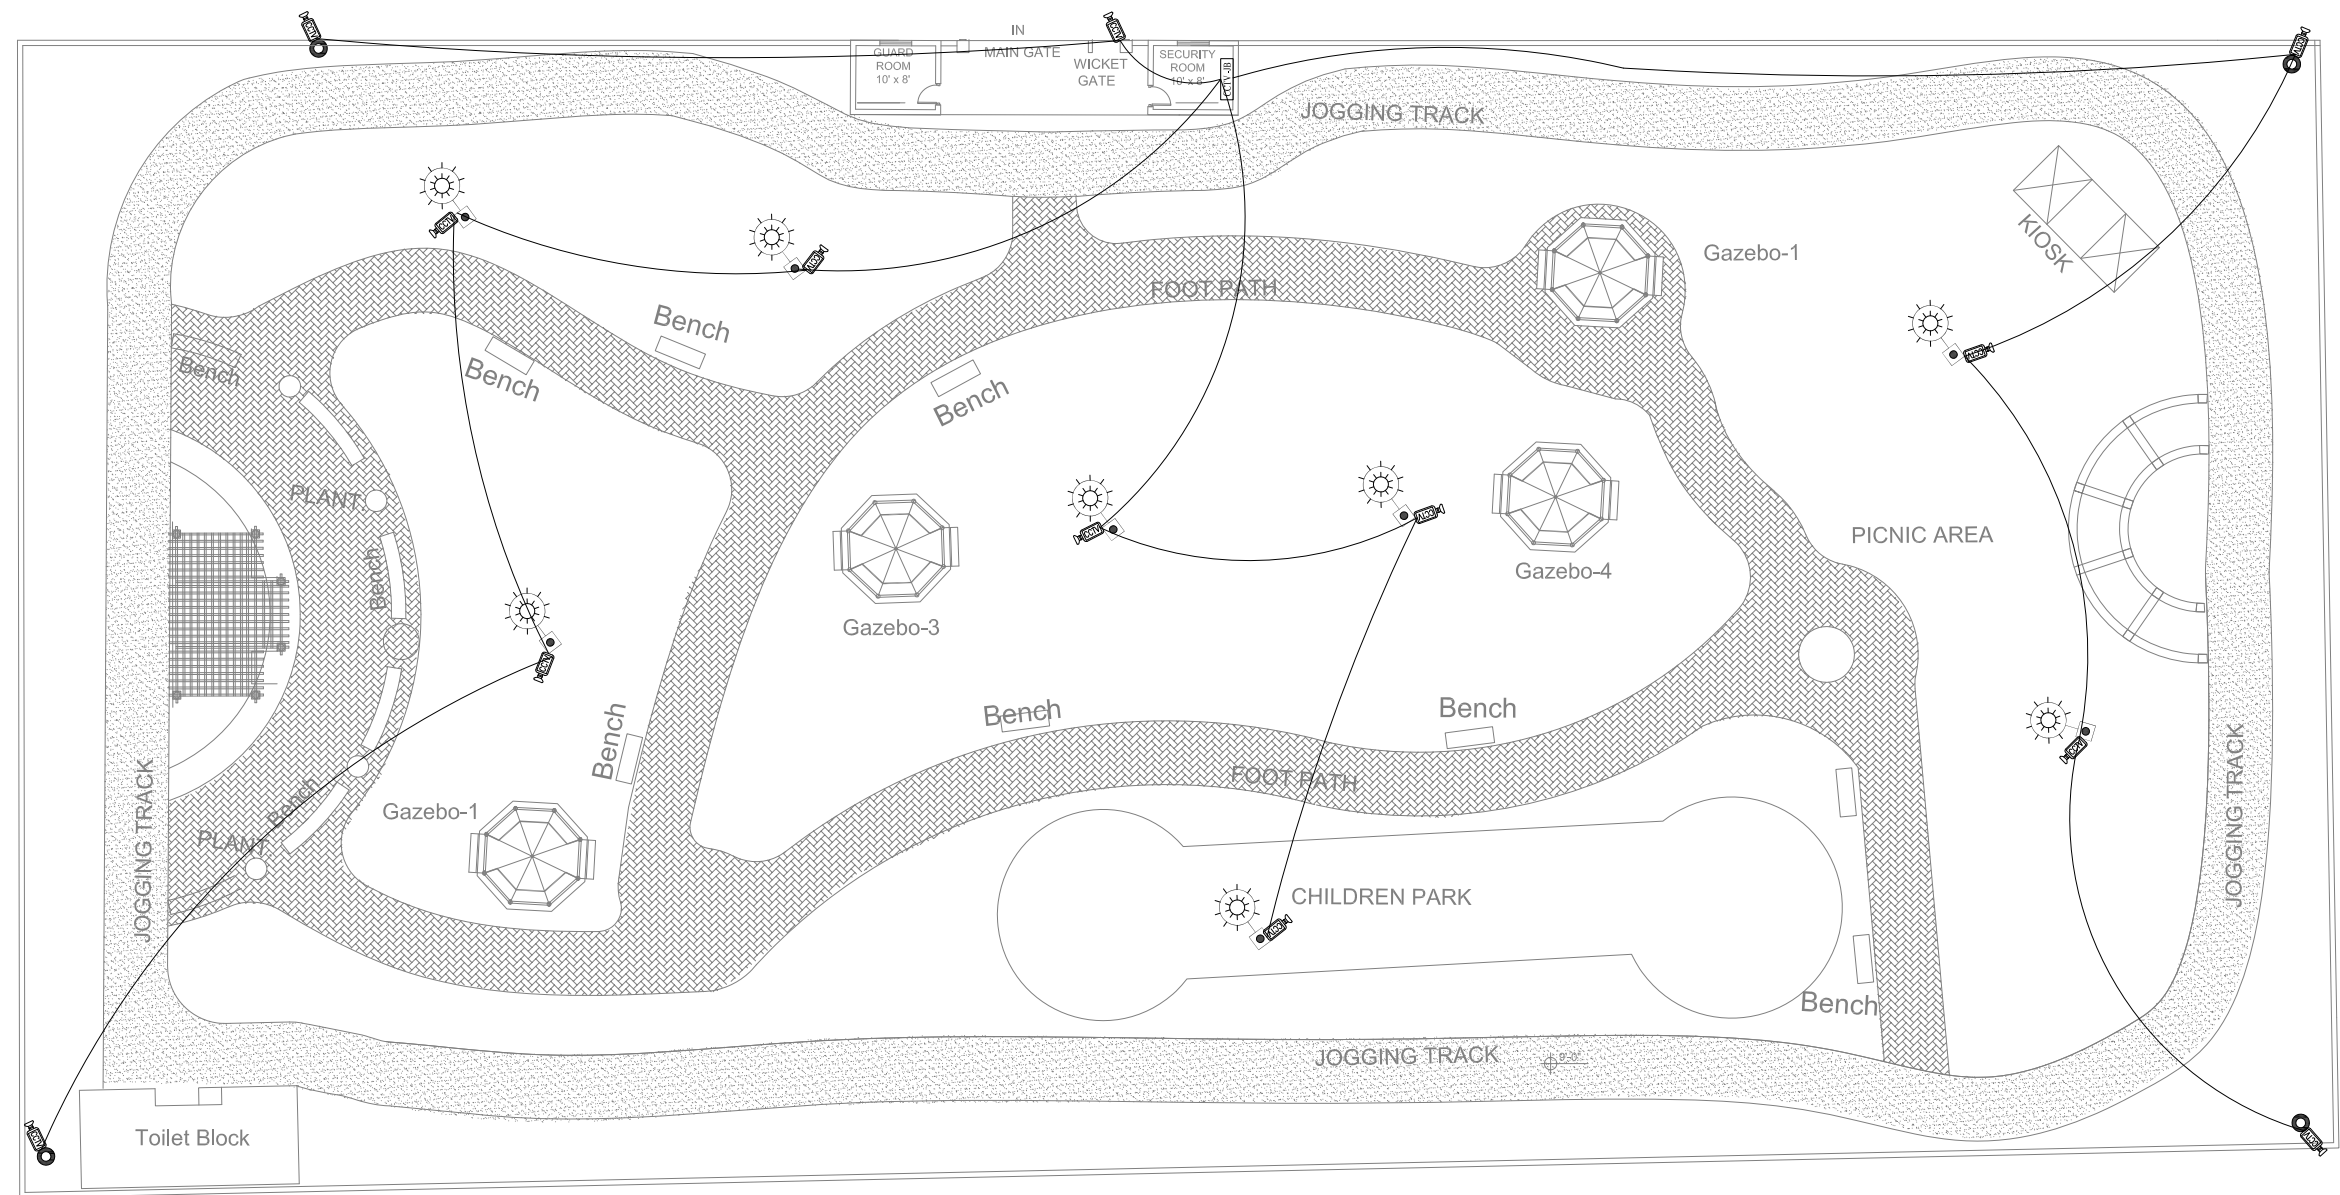

CLIENT:



PROJECT
IMPLEMENTATION
UNIT (PIU) KNIP



CONSULTANTS:
**G3 ENGINEERING
CONSULTANTS (PVT.) LTD.**
House No.57-M Gulberg-II, Lahore, Pakistan
Tel : (92-42) 35441641, 35441642
Fax : (92-42) 35441645
E-mail : info@g3ec.com
URL : www.g3ec.com

PROJECT:

REHABILITATION & UP GRADATION OF
BOAT BASIN TO SCHON CHOWRANGI
WITH PEDESTRIAN TRAIL

NOTES:

1. ALL DIMENSIONS ARE IN FEET UNLESS OTHERWISE SPECIFIED.
2. THIS DRAWING IS AN INTELLECTUAL PROPERTY OF G3 ENGINEERING CONSULTANTS (PVT.) LTD. AND CANNOT BE REPRINTED OR REPRODUCED WITHOUT PRIOR APPROVAL OF G3.

REVISIONS:

No.	DESCRIPTION	DATE

TENDER DRAWINGS

DRAWING TITLE:

ST-08
CCTV
LAYOUT PLAN

DRAWN BY:
Engr. M.RAFFEH

DATE:
Aug 2021

ELECTRICAL ENGINEER:
Engr. Ghulam Daraz Shaikh


APPROVED BY:
SAYED ALI ABBAS GILLANI

DRAWING NO:
0249/PARKS/19

REV:
4

SCALE (A3):
N.T.S


SHEET:
0/0

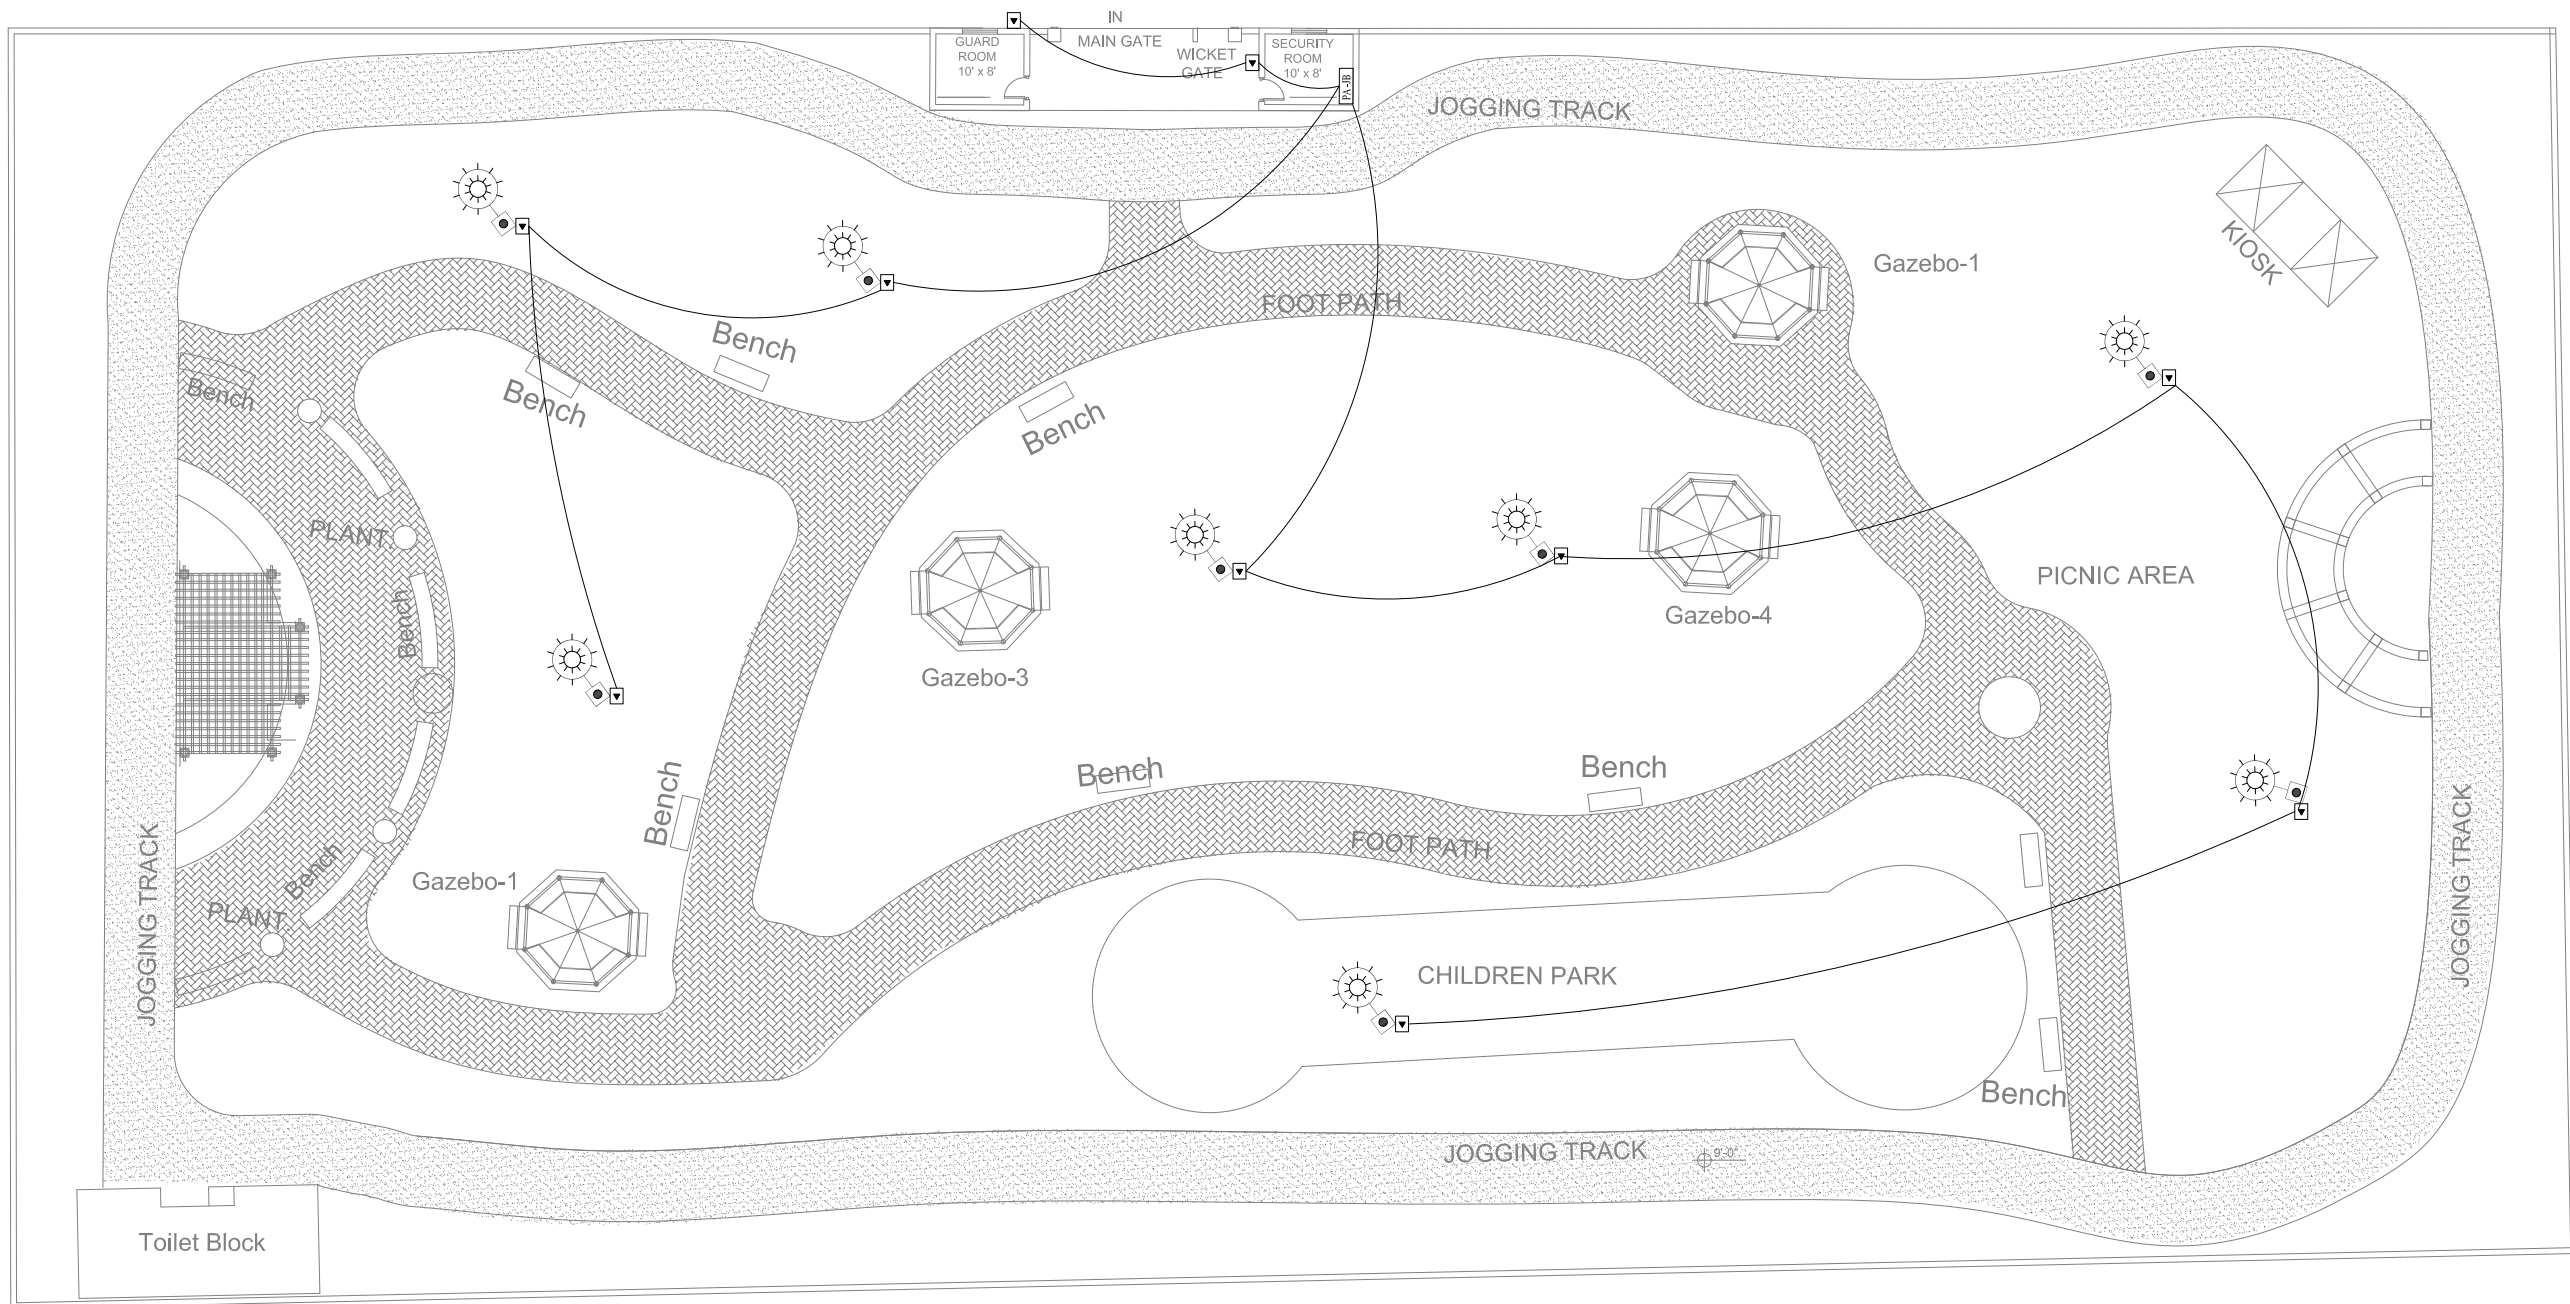

CLIENT:



 PROJECT
IMPLEMENTATION
UNIT (PIU) KNIP



CONSULTANTS:

**G3 ENGINEERING
CONSULTANTS (PVT) LTD.**
House No.57-M Gulberg-III, Lahore, Pakistan

Tel : (92-42) 35441641, 35441642
Fax : (92-42) 35441645
E-mail : info@g3ec.com
URL : www.g3ec.com

PROJECT:

REHABILITATION & UP GRADATION OF
BOAT BASIN TO SCHON CHOWRANGI
WITH PEDESTRIAN TRAIL

NOTES:

1. ALL DIMENSIONS ARE IN FEET UNLESS OTHERWISE SPECIFIED.
2. THIS DRAWING IS AN INTELLECTUAL PROPERTY OF G3 ENGINEERING CONSULTANTS (PVT.) LTD. AND CANNOT BE REPRINTED OR REPRODUCED WITHOUT PRIOR APPROVAL OF G3.

REVISIONS:

No.	DESCRIPTION	DATE

TENDER DRAWINGS

DRAWING TITLE:
**ST-08
PUBLIC ADDRESS
SYSTEM
LAYOUT PLAN**

DRAWN BY:
Engr. M.RAFFEH

DATE:
Aug 2021

ELECTRICAL ENGINEER:
Engr. Ghulam Daraz Shaikh


APPROVED BY:
SAYED ALI ABBAS GILLANI

DRAWING NO:
0249/PARKS/20

REV:
4

SCALE (A3):
N.T.S

SHEET:
0/0

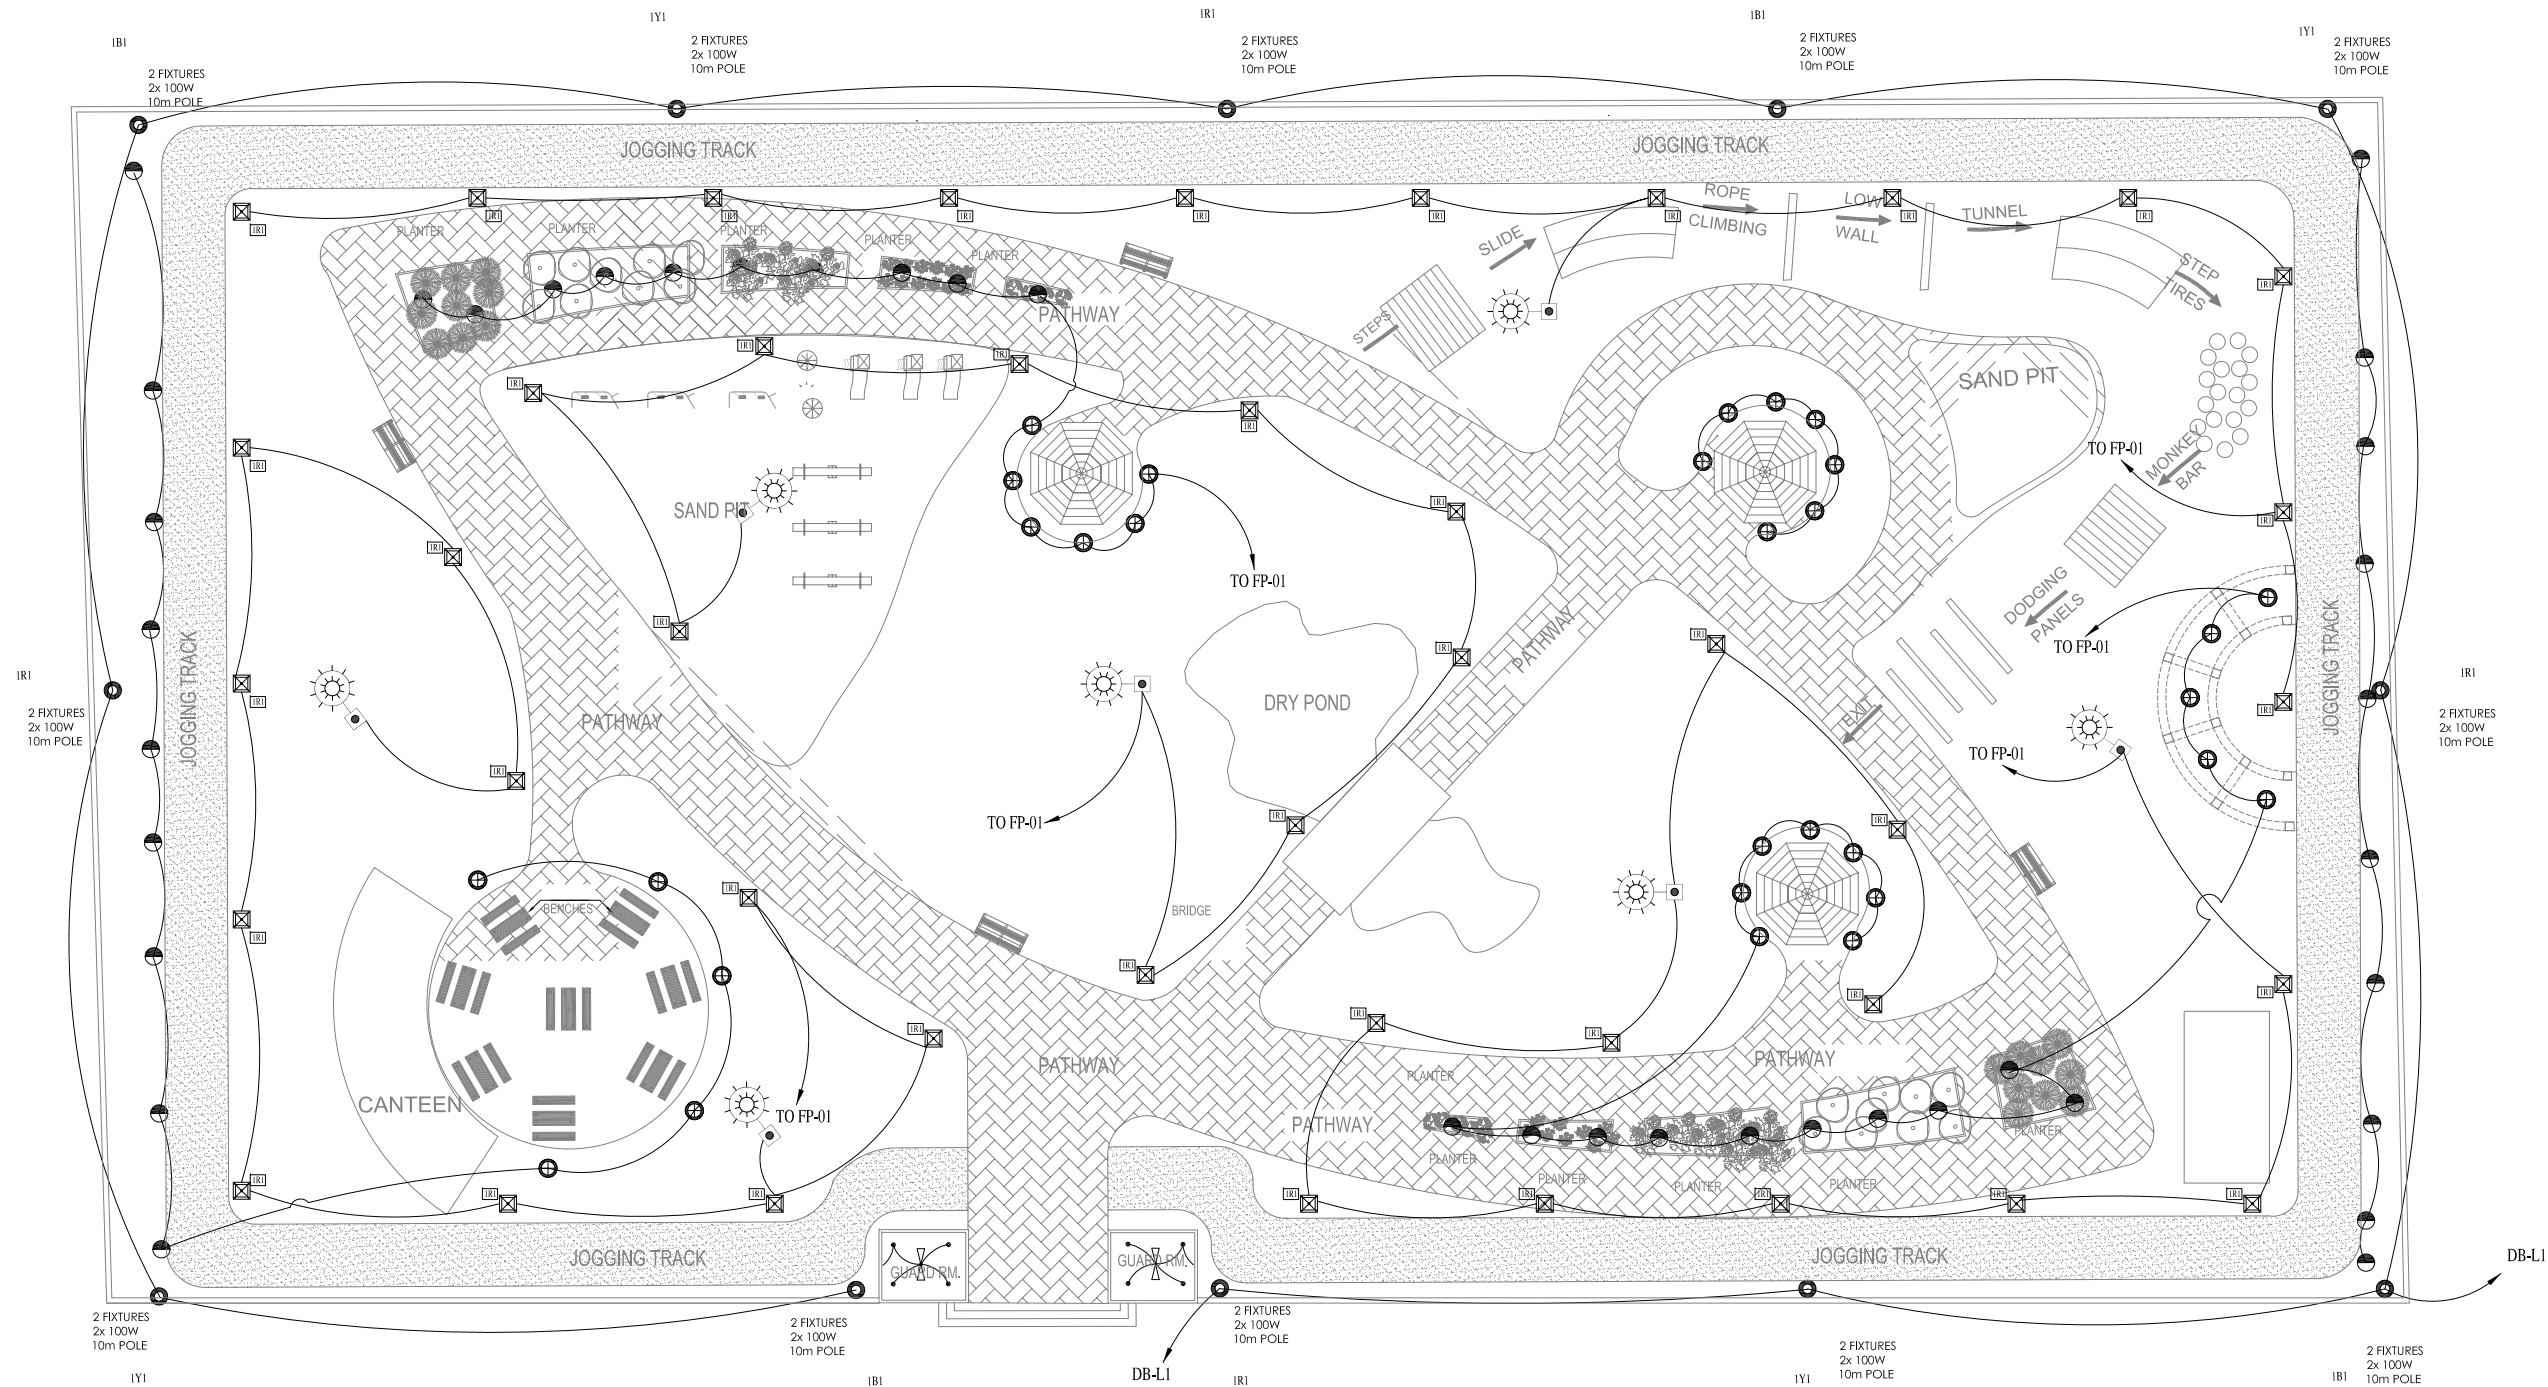

CLIENT:



PROJECT
IMPLEMENTATION
UNIT (PIU) KNIP



CONSULTANTS:
**G3 ENGINEERING
CONSULTANTS (PVT) LTD.**
House No.57-M Gulberg-II, Lahore, Pakistan
Tel : (92-42) 35441641, 35441642
Fax : (92-42) 35441645
E-mail : info@g3ec.com
URL : www.g3ec.com

PROJECT:

REHABILITATION & UP GRADATION OF
BOAT BASIN TO SCHON CHOWRANGI
WITH PEDESTRIAN TRAIL

NOTES:
1. ALL DIMENSIONS ARE IN FEET UNLESS
OTHERWISE SPECIFIED.
2. THIS DRAWING IS AN INTELLECTUAL PROPERTY
OF G3 ENGINEERING CONSULTANTS (PVT.) LTD.
AND CANNOT BE REPRINTED OR REPRODUCED
WITHOUT PRIOR APPROVAL OF G3.


REVISIONS:

No.	DESCRIPTION	DATE

TENDER DRAWINGS

DRAWING TITLE:
**ST-09
ILLUMINATION
LAYOUT PLAN**


DRAWN BY: Engr. M.RAFFEH	DATE: Aug 2021
ELECTRICAL ENGINEER: Engr. Ghulam Daraz Shaikh	
APPROVED BY: SAYED ALI ABBAS GILLANI	
DRAWING NO: 0249/PARKS/21	REV: 4
SCALE (A3): N.T.S	SHEET: 0/0

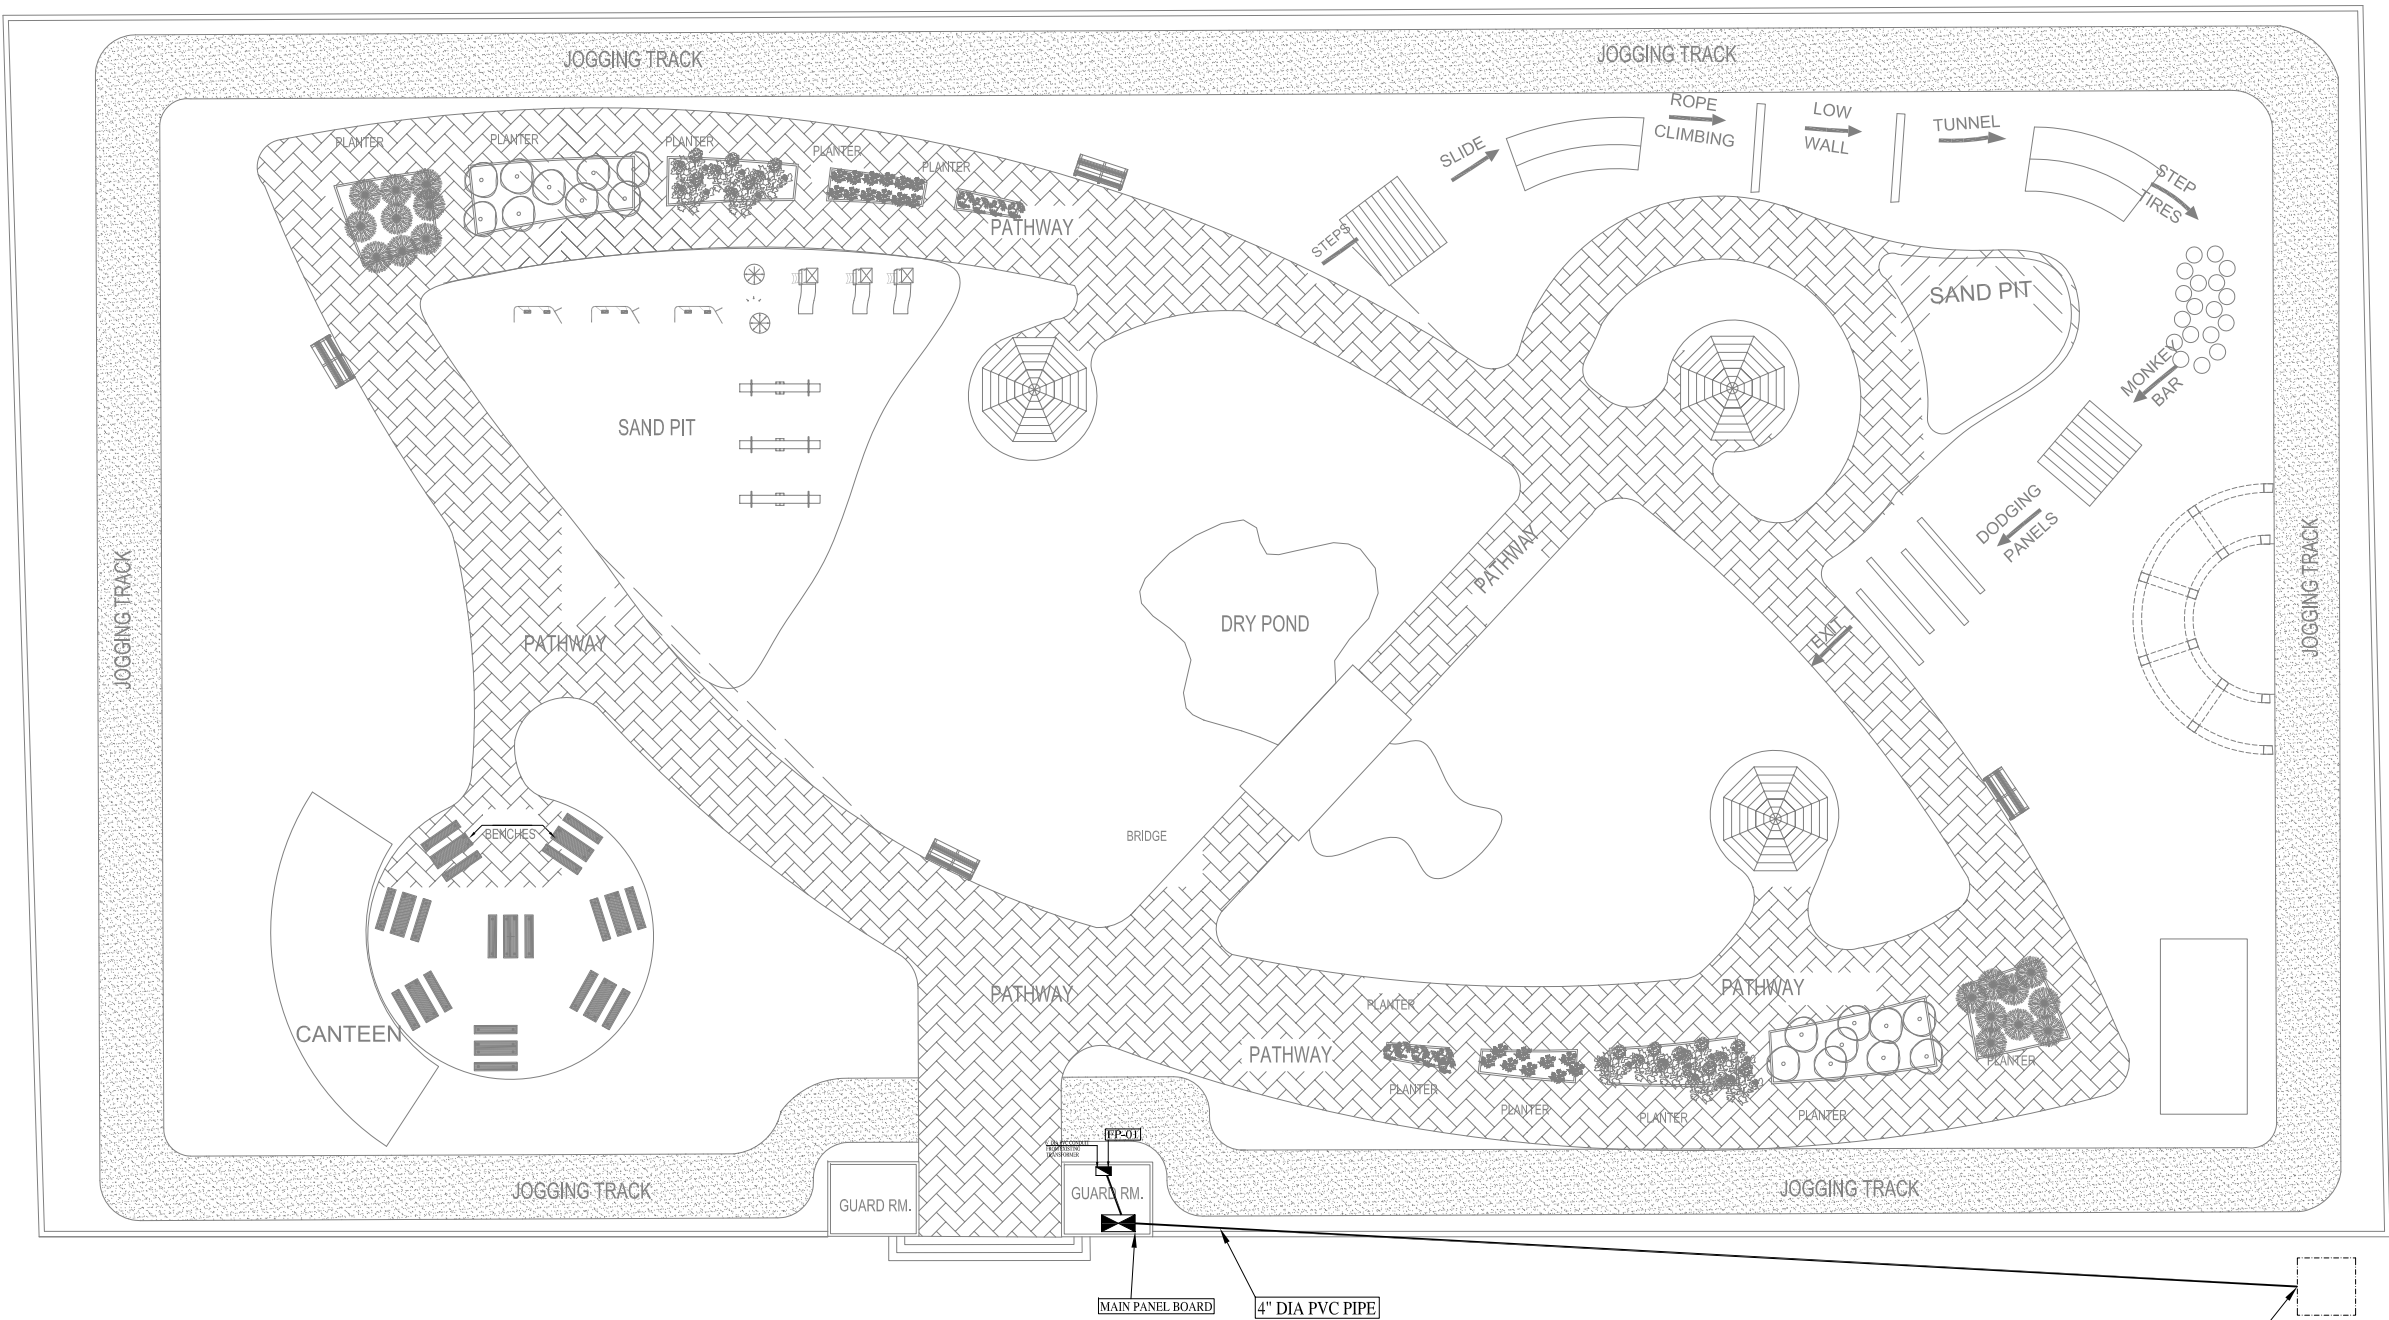

CLIENT:



 PROJECT
IMPLEMENTATION
UNIT (PIU) KNIP



CONSULTANTS:

G3 ENGINEERING
CONSULTANTS (PVT)LTD.
House No.57-M Gulberg-II, Lahore, Pakistan

Tel : (92-42) 35441641, 35441642
Fax : (92-42) 35441645
E-mail : info@g3ec.com
URL : www.g3ec.com

PROJECT:

REHABILITATION & UP GRADATION OF
BOAT BASIN TO SCHON CHOWRANGI
WITH PEDESTRIAN TRAIL

NOTES:

1. ALL DIMENSIONS ARE IN FEET UNLESS OTHERWISE SPECIFIED.
2. THIS DRAWING IS AN INTELLECTUAL PROPERTY OF G3 ENGINEERING CONSULTANTS (PVT.) LTD. AND CANNOT BE REPRINTED OR REPRODUCED WITHOUT PRIOR APPROVAL OF G3.

REVISIONS:

No.	DESCRIPTION	DATE

TENDER DRAWINGS

DRAWING TITLE:

ST-09
POWER DISTRIBUTION
LAYOUT PLAN

DRAWN BY:
Engr. M.RAFFEH

DATE:
Aug 2021

ELECTRICAL ENGINEER:
Engr. Ghulam Daraz Shaikh

APPROVED BY:
SAYED ALI ABBAS GILLANI


DRAWING NO:
0249/PARKS/22

REV:
4

SCALE (A3):
N.T.S

SHEET:
0/0

EXISTING PMT

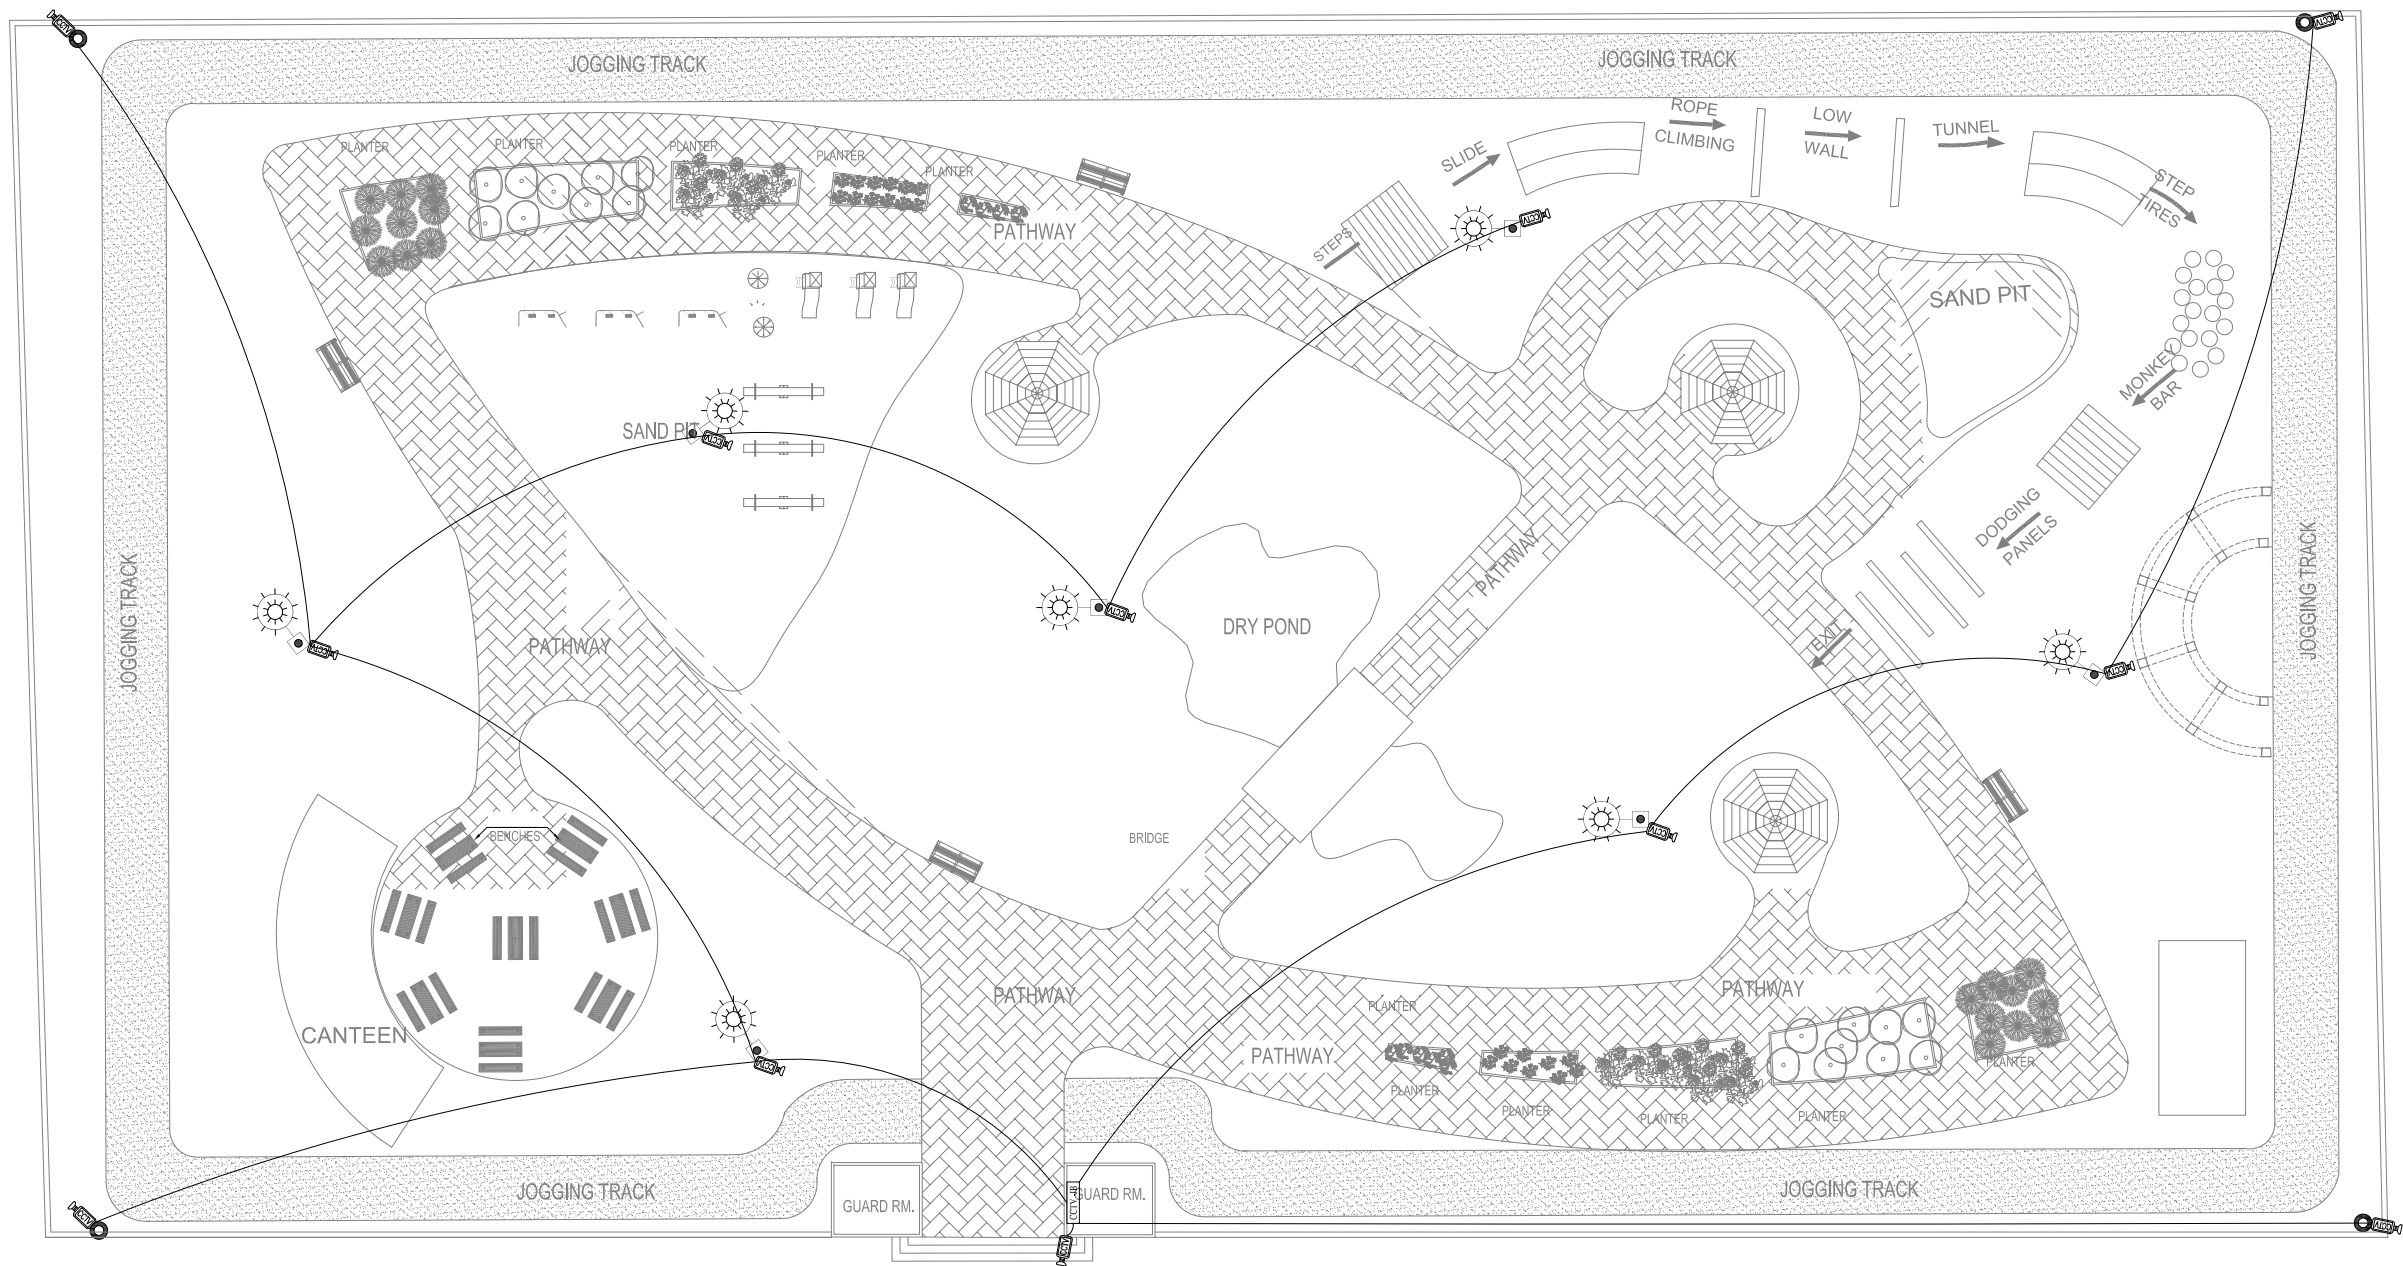

CLIENT:



PROJECT
IMPLEMENTATION
UNIT (PIU) KNIP



CONSULTANTS:
**G3 ENGINEERING
CONSULTANTS (PVT) LTD.**
House No.57-M Gulberg-II, Lahore, Pakistan
Tel : (92-42) 35441641, 35441642
Fax : (92-42) 35441645
E-mail : info@g3ec.com
URL : www.g3ec.com

PROJECT:

REHABILITATION & UP GRADATION OF
BOAT BASIN TO SCHON CHOWRANGI
WITH PEDESTRIAN TRAIL

NOTES:

1. ALL DIMENSIONS ARE IN FEET UNLESS OTHERWISE SPECIFIED.
2. THIS DRAWING IS AN INTELLECTUAL PROPERTY OF G3 ENGINEERING CONSULTANTS (PVT.) LTD. AND CANNOT BE REPRINTED OR REPRODUCED WITHOUT PRIOR APPROVAL OF G3.

REVISIONS:


No.	DESCRIPTION	DATE

TENDER DRAWINGS

DRAWING TITLE:

ST-09
CCTV
LAYOUT PLAN

DRAWN BY: Engr. M.RAFFEH	DATE: Aug 2021
ELECTRICAL ENGINEER: Engr. Ghulam Daraz Shaikh	
APPROVED BY: SAYED ALI ABBAS GILLANI	
DRAWING NO: 0249/PARKS/23	REV: 4
SCALE (A3): N.T.S	SHEET: 0/0

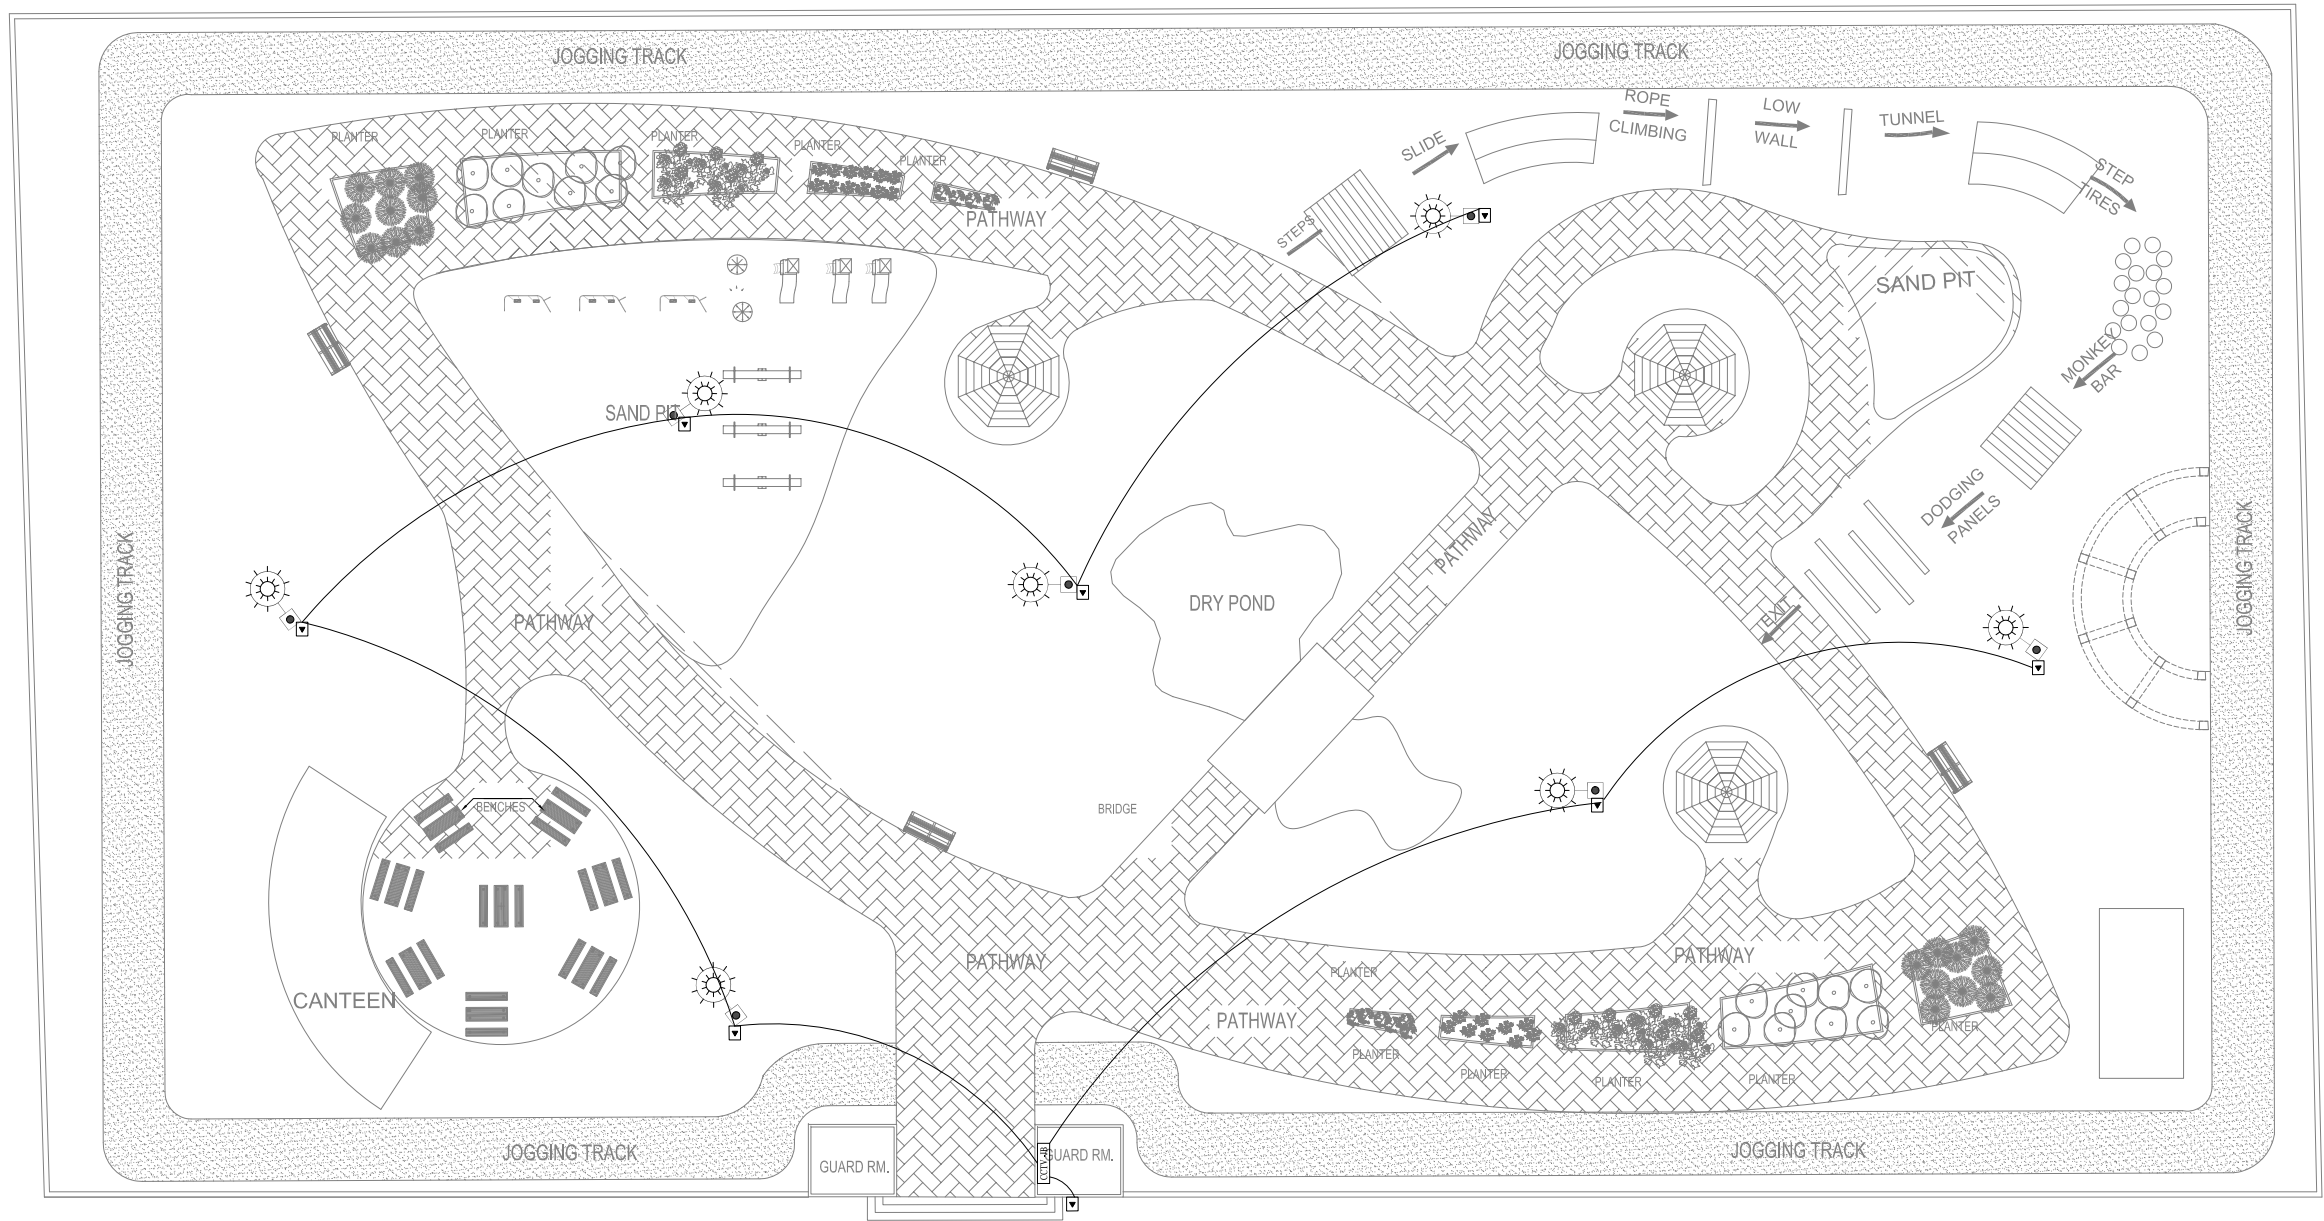

CLIENT:



PROJECT
IMPLEMENTATION
UNIT (PIU) KNIP



CONSULTANTS:

**G3 ENGINEERING
CONSULTANTS (PVT) LTD.**
House No.57-M Gulberg-III, Lahore, Pakistan

Tel : (92-42) 35441641, 35441642
Fax : (92-42) 35441645
E-mail : info@g3ec.com
URL : www.g3ec.com

PROJECT:

REHABILITATION & UP GRADATION OF
BOAT BASIN TO SCHON CHOWRANGI
WITH PEDESTRIAN TRAIL

NOTES:

1. ALL DIMENSIONS ARE IN FEET UNLESS OTHERWISE SPECIFIED.
2. THIS DRAWING IS AN INTELLECTUAL PROPERTY OF G3 ENGINEERING CONSULTANTS (PVT.) LTD. AND CANNOT BE REPRINTED OR REPRODUCED WITHOUT PRIOR APPROVAL OF G3.

REVISIONS:

No.	DESCRIPTION	DATE

TENDER DRAWINGS

DRAWING TITLE:

**ST-09
PUBLIC ADDRESS
SYSTEM
LAYOUT PLAN**

DRAWN BY:
Engr. M.RAFFEH

DATE:
Aug 2021

ELECTRICAL ENGINEER:
Engr. Ghulam Daraz Shaikh


APPROVED BY:
SAYED ALI ABBAS GILLANI

DRAWING NO:
0249/PARKS/24

REV:
4

SCALE (A3):
N.T.S

SHEET:
0/0

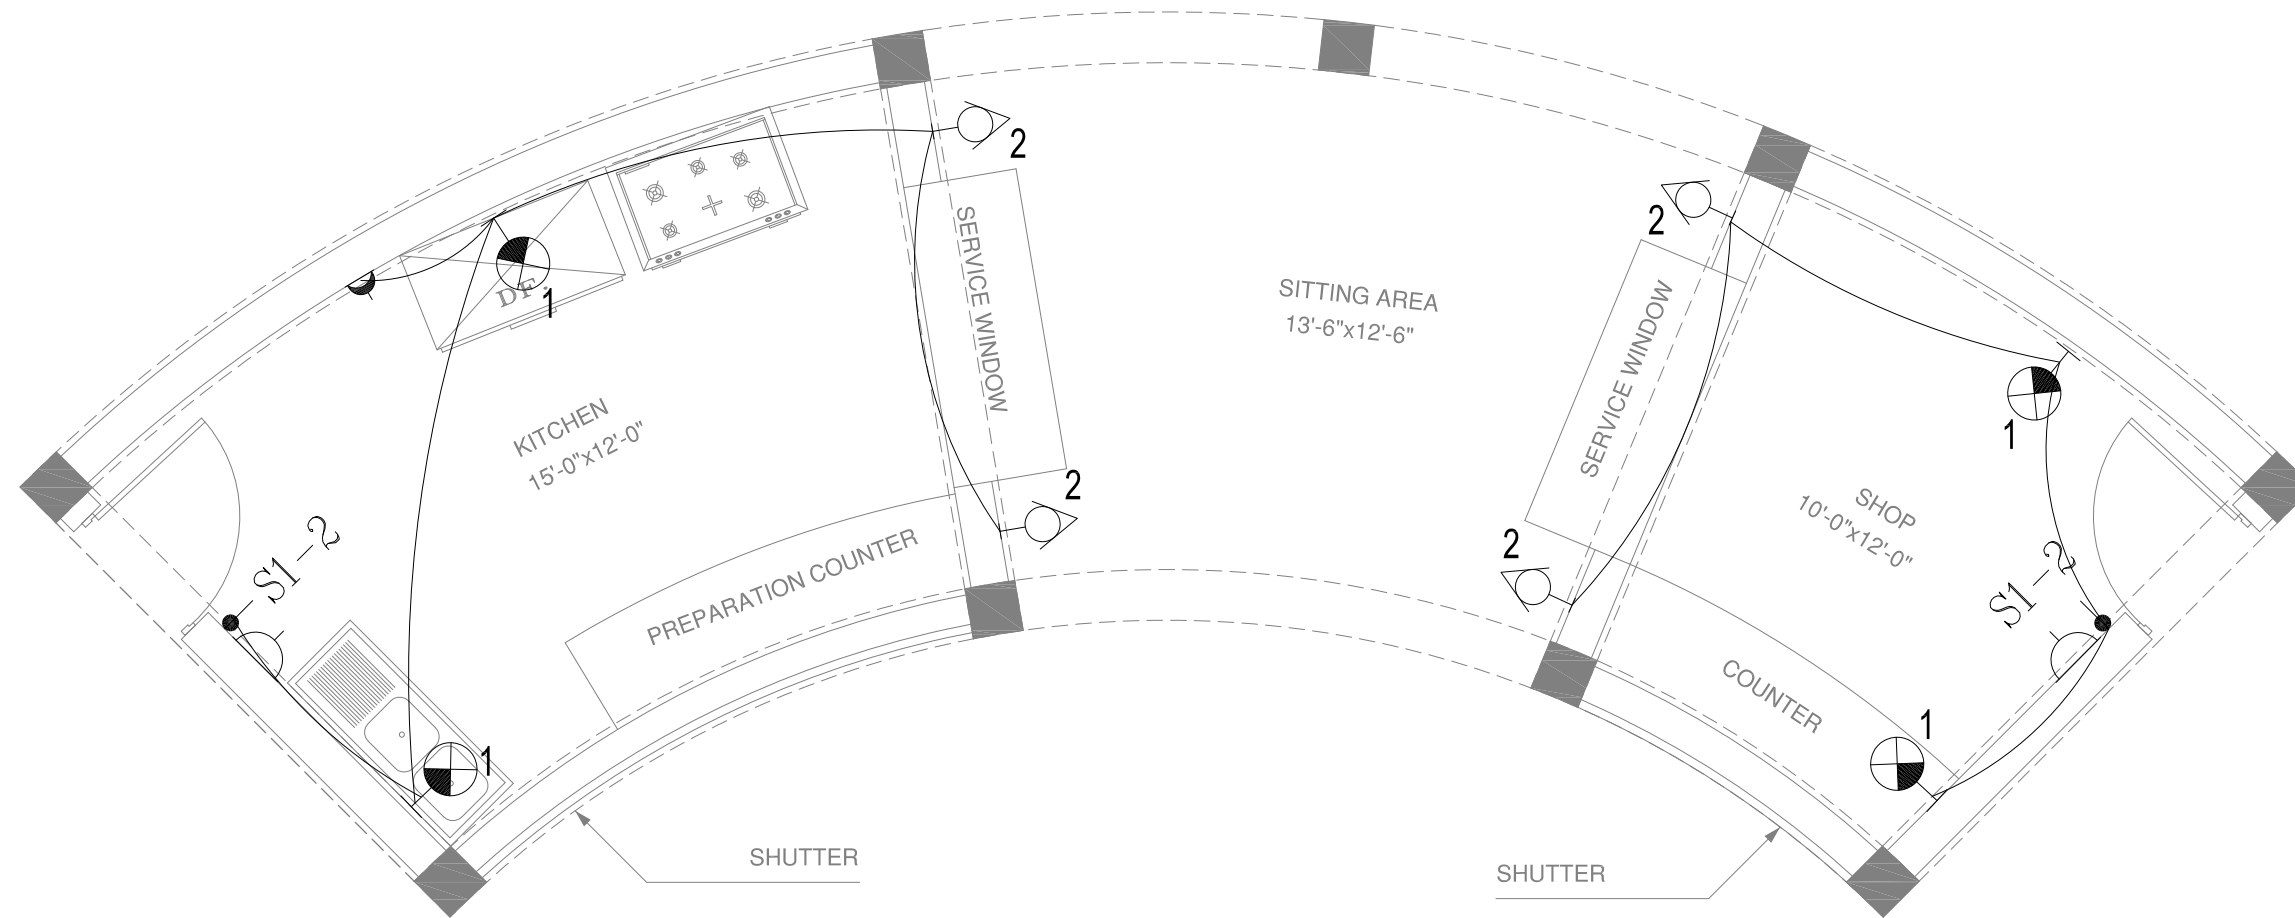

PLAN

CLIENT:



PROJECT
IMPLEMENTATION
UNIT (PIU) KNIP



CONSULTANTS:

**G3 ENGINEERING
CONSULTANTS (PVT.) LTD.**
House No.57-M Gulberg-III, Lahore, Pakistan

Tel : (92-42) 35441641, 35441642
Fax : (92-42) 35441645
E-mail : info@g3ec.com
URL : www.g3ec.com

PROJECT:

REHABILITATION & UP GRADATION OF
BOAT BASIN TO SCHON CHOWRANGI
WITH PEDESTRIAN TRAIL

NOTES:

1. ALL DIMENSIONS ARE IN FEET UNLESS OTHERWISE SPECIFIED.
2. THIS DRAWING IS AN INTELLECTUAL PROPERTY OF G3 ENGINEERING CONSULTANTS (PVT.) LTD. AND CANNOT BE REPRINTED OR REPRODUCED WITHOUT PRIOR APPROVAL OF G3.

REVISIONS:

No.	DESCRIPTION	DATE

TENDER DRAWINGS

DRAWING TITLE:

**ST-09 (CANTEEN)
ILLUMINATION
LAYOUT PLAN**

DRAWN BY:
Engr. M.RAFFEH

DATE:
Aug 2021

ELECTRICAL ENGINEER:
Engr. Ghulam Daraz Shaikh


APPROVED BY:
SAYED ALI ABBAS GILLANI

DRAWING NO:
0249/PARKS/25

REV:
4

SCALE (A3):
N.T.S

SHEET:
0/0

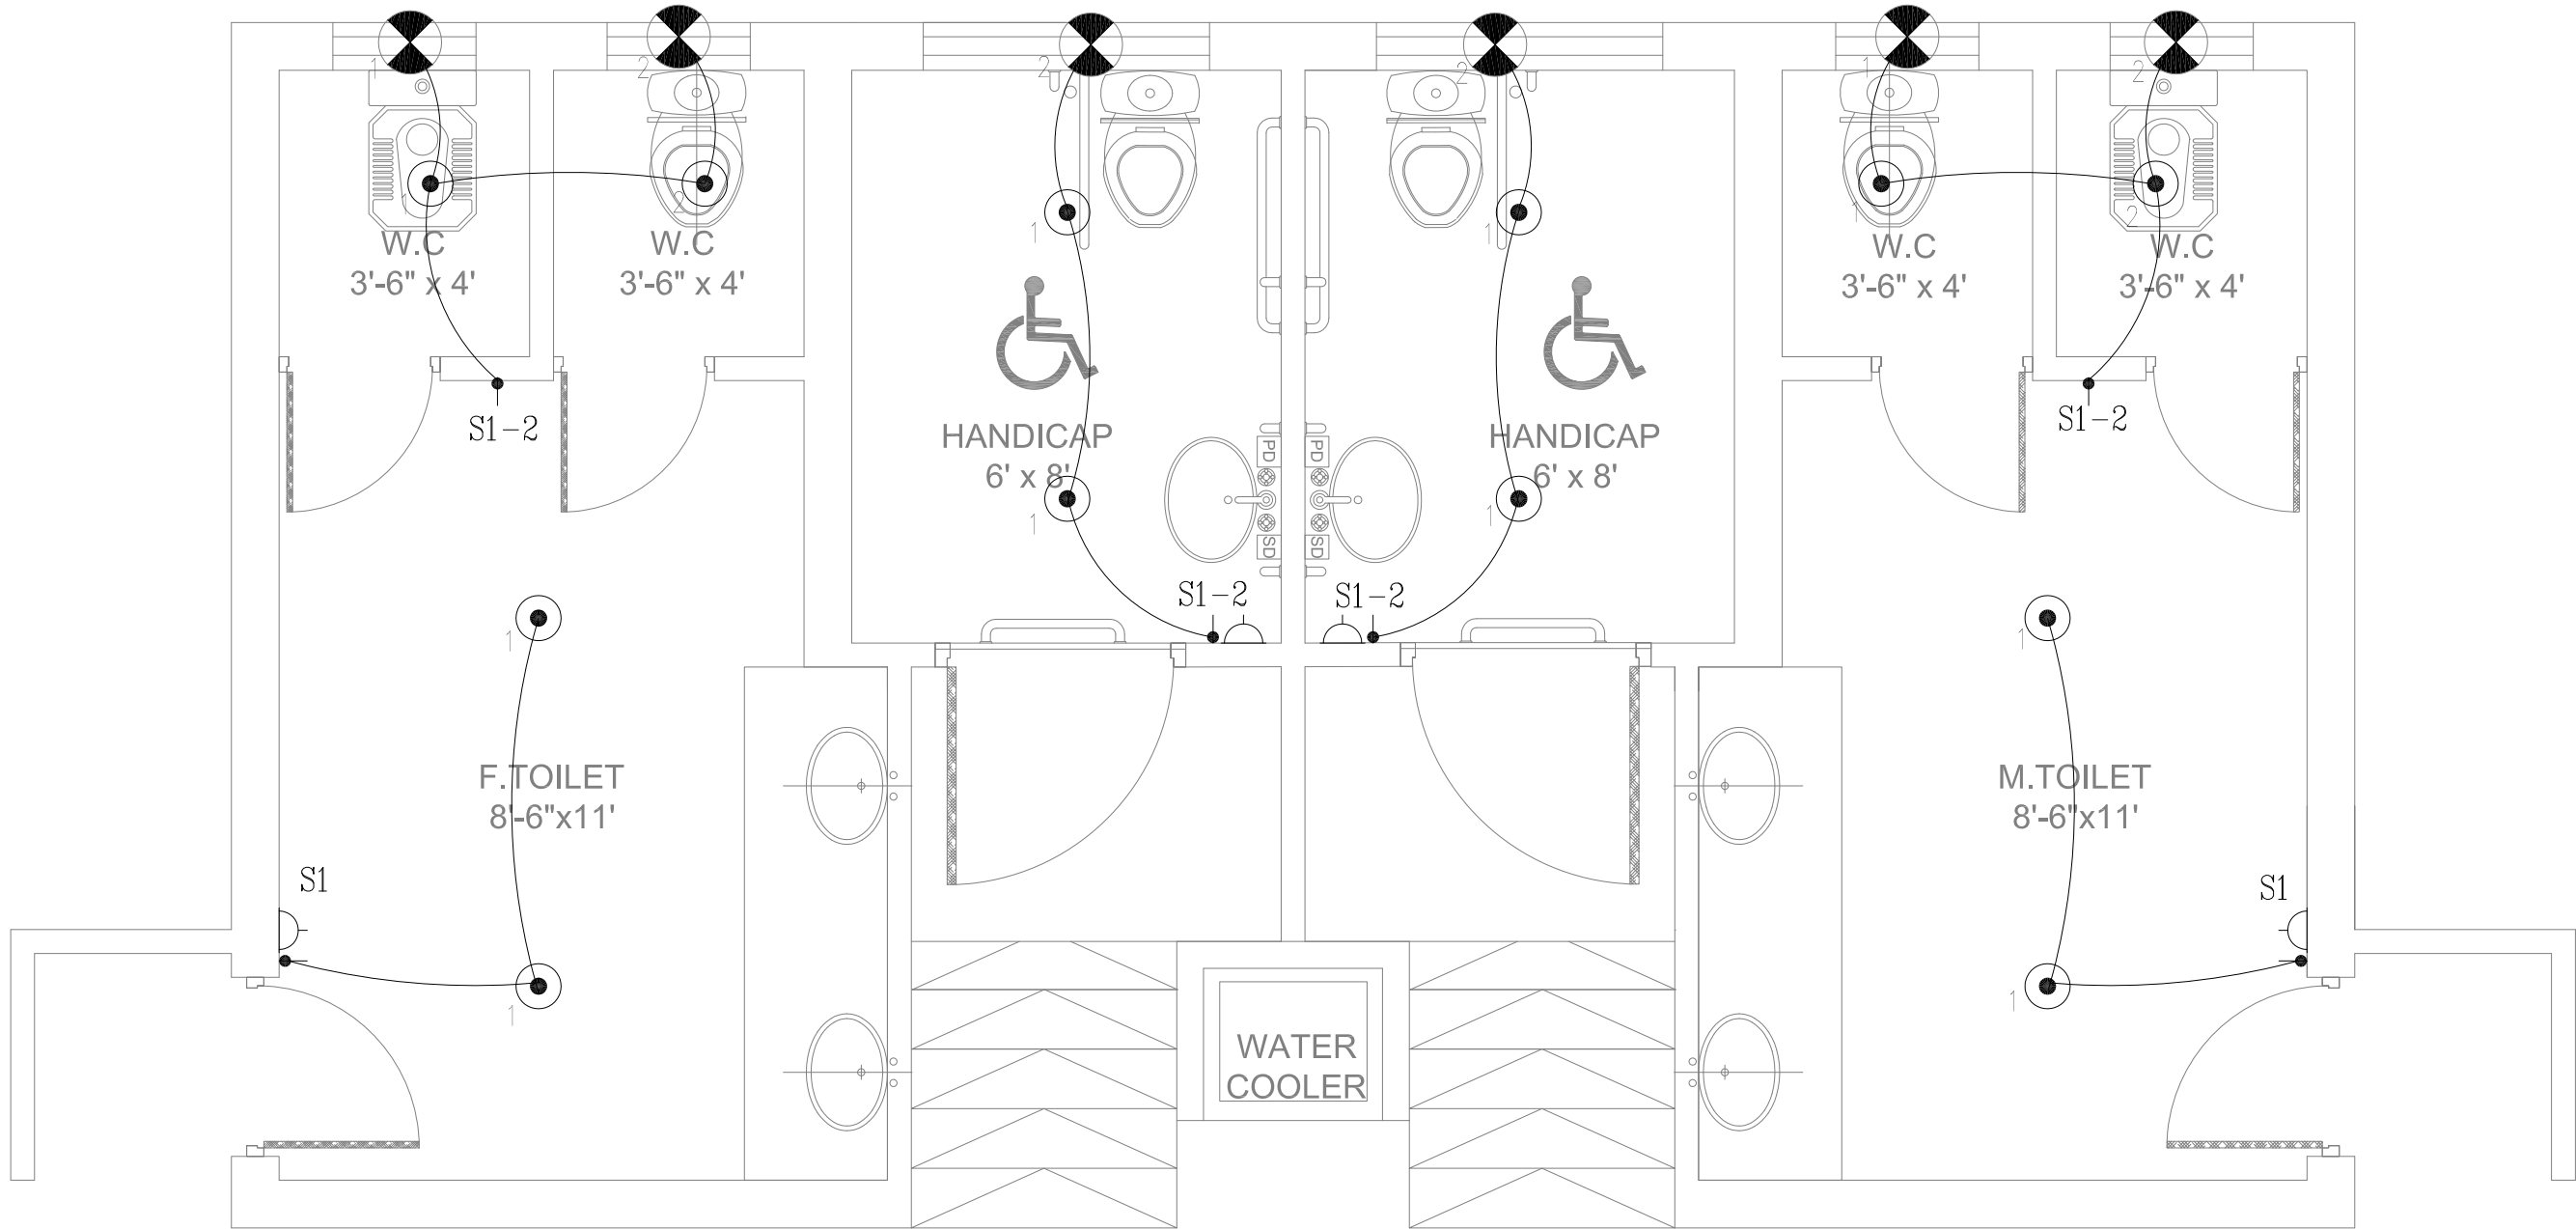


Toilet Block - Parks

CLIENT:



 PROJECT
IMPLEMENTATION
UNIT (PIU) KNIP



CONSULTANTS:

**G3 ENGINEERING
CONSULTANTS (PVT) LTD.**
House No.57-M Gulberg-II, Lahore, Pakistan

Tel : (92-42) 35441641, 35441642
Fax : (92-42) 35441645
E-mail : info@g3ec.com
URL : www.g3ec.com

PROJECT:

REHABILITATION & UP GRADATION OF
BOAT BASIN TO SCHON CHOWRANGI
WITH PEDESTRIAN TRAIL

NOTES:

1. ALL DIMENSIONS ARE IN FEET UNLESS OTHERWISE SPECIFIED.
2. THIS DRAWING IS AN INTELLECTUAL PROPERTY OF G3 ENGINEERING CONSULTANTS (PVT.) LTD. AND CANNOT BE REPRINTED OR REPRODUCED WITHOUT PRIOR APPROVAL OF G3.

REVISIONS:


No.	DESCRIPTION	DATE

TENDER DRAWINGS

DRAWING TITLE:

TOILET BLOCK- PARKS
ILLUMINATION
LAYOUT PLAN


DRAWN BY: Engr. M.RAFFEH	DATE: Aug 2021
ELECTRICAL ENGINEER: Engr. Ghulam Daraz Shaikh	
APPROVED BY: SAYED ALI ABBAS GILLANI	
DRAWING NO: 0249/PARKS/TB/26	REV: 4
SCALE (A3): N.T.S	SHEET: 0/0

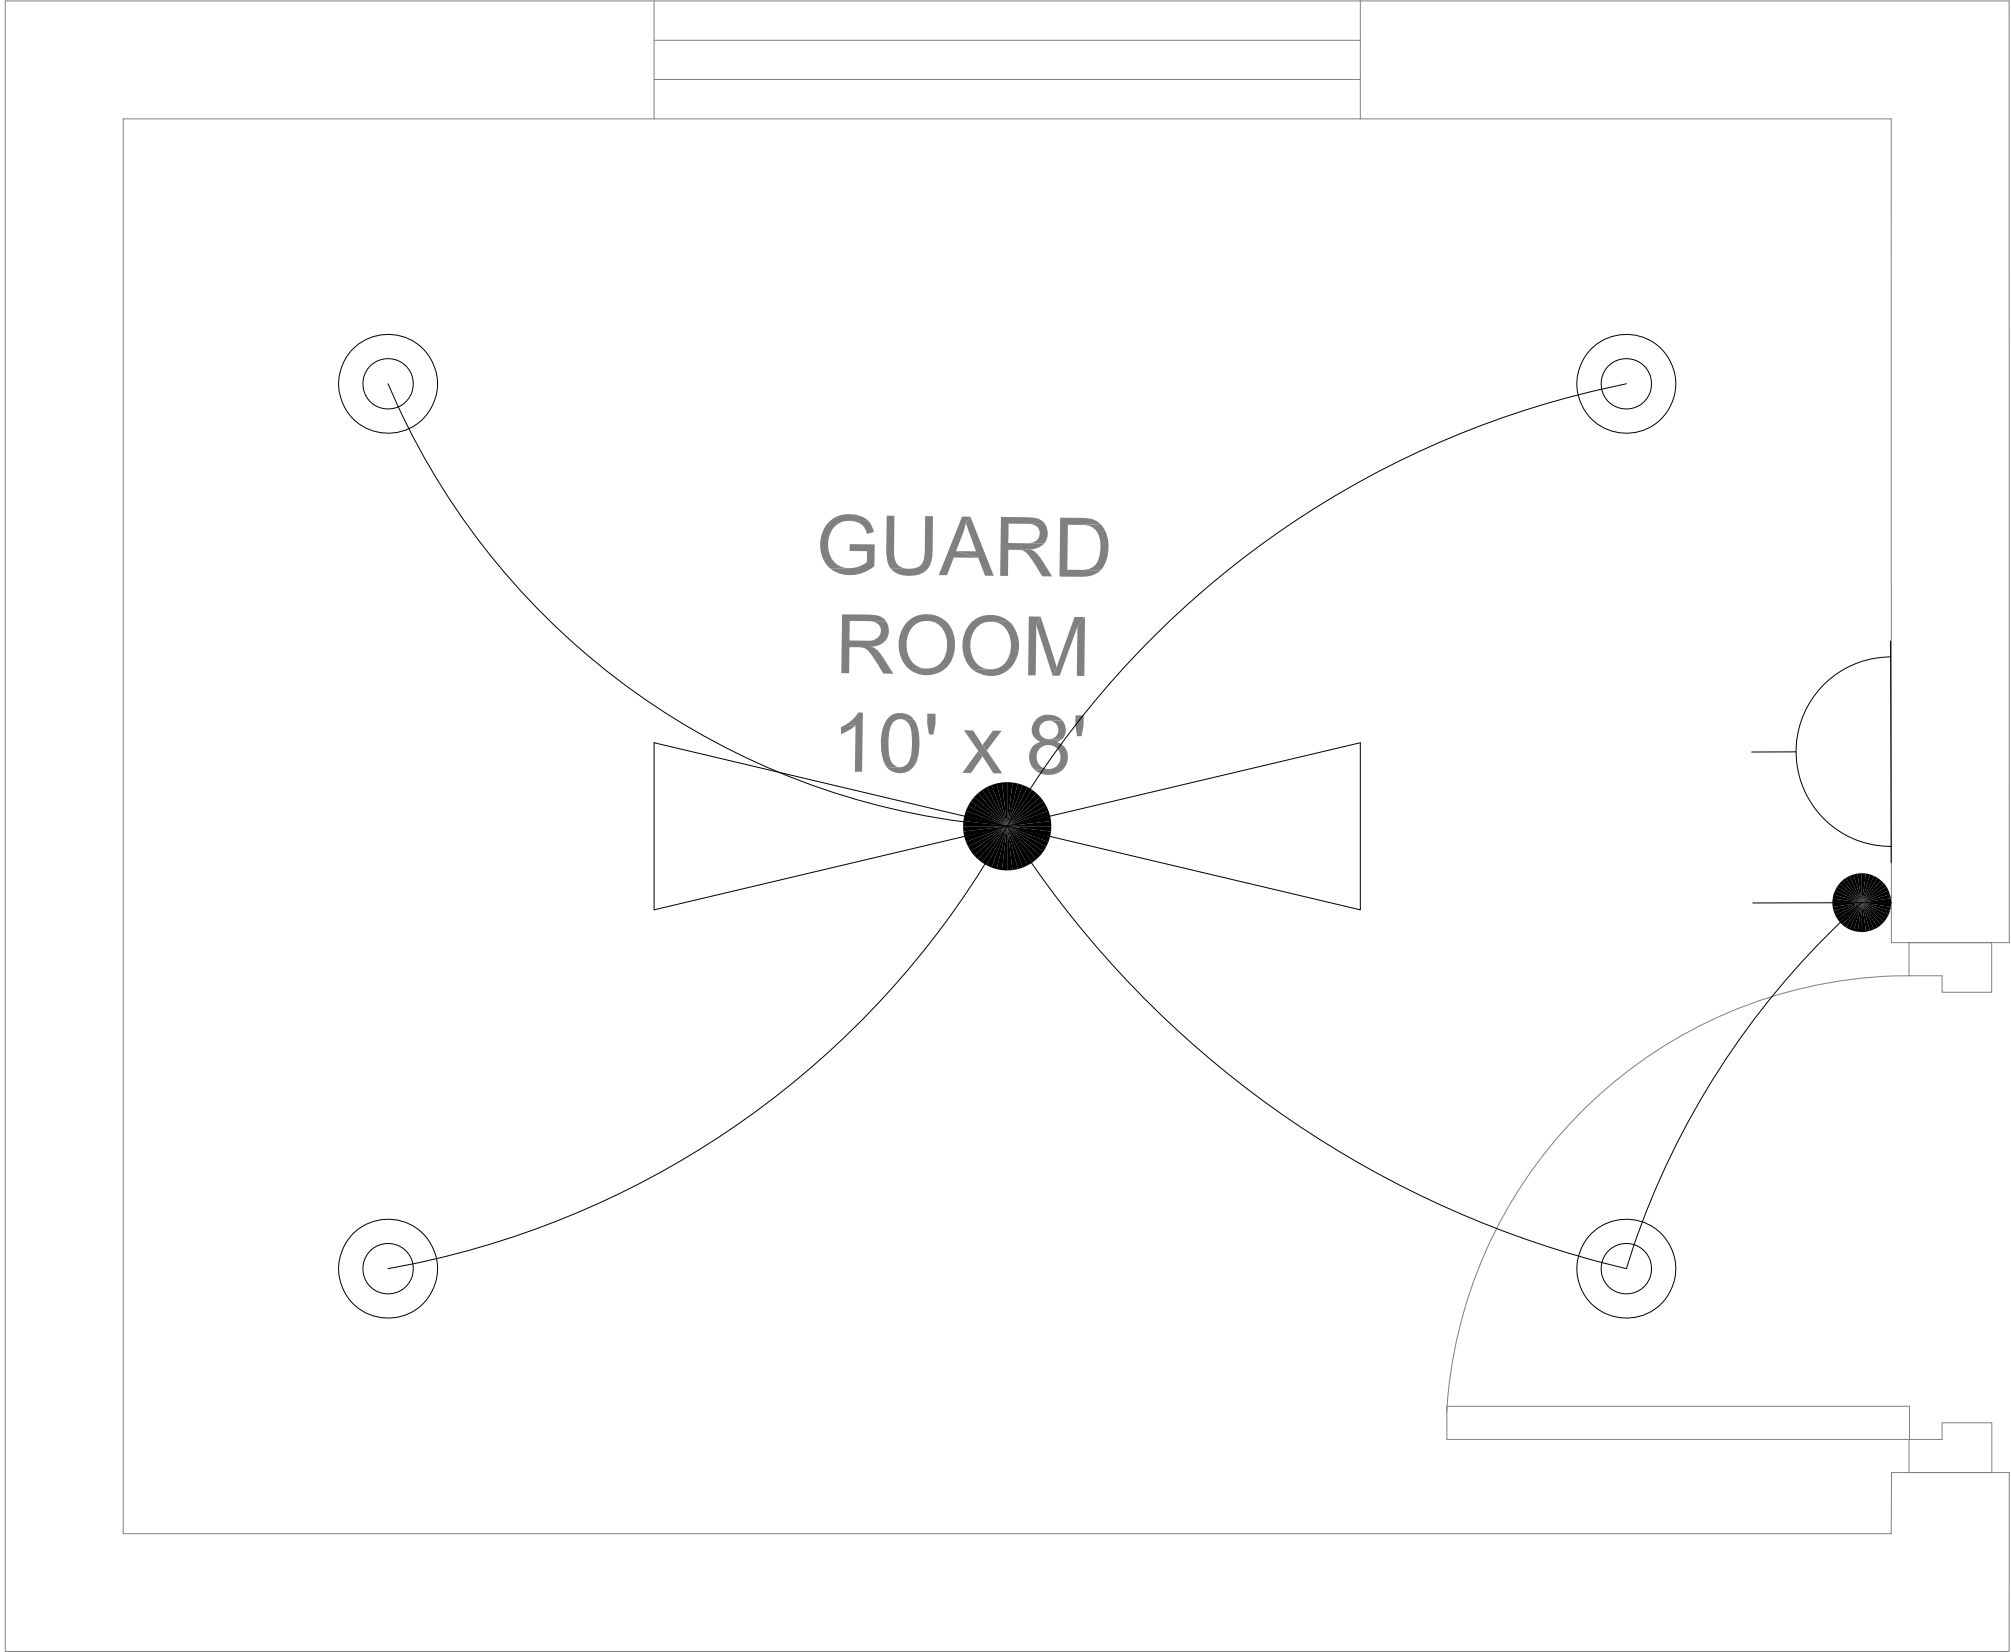

CLIENT:



 PROJECT
IMPLEMENTATION
UNIT (PIU) KNIP



CONSULTANTS:
**G3 ENGINEERING
CONSULTANTS (PVT)LTD.**
House No.57-M Gulberg-II, Lahore, Pakistan
Tel : (92-42) 35441641, 35441642
Fax : (92-42) 35441645
E-mail : info@g3ec.com
URL : www.g3ec.com

PROJECT:

REHABILITATION & UP GRADATION OF
BOAT BASIN TO SCHON CHOWRANGI
WITH PEDESTRIAN TRAIL

NOTES:
1. ALL DIMENSIONS ARE IN FEET UNLESS
OTHERWISE SPECIFIED.
2. THIS DRAWING IS AN INTELLECTUAL PROPERTY
OF G3 ENGINEERING CONSULTANTS (PVT.) LTD.
AND CANNOT BE REPRINTED OR REPRODUCED
WITHOUT PRIOR APPROVAL OF G3.

REVISIONS:



No.	DESCRIPTION	DATE

TENDER DRAWINGS


DRAWING TITLE:
**GUARD ROOMS
PARKS
ILLUMINATION LAYOUT**

DRAWN BY: Engr. M.RAFFEH	DATE: Aug 2021
ELECTRICAL ENGINEER: Engr. Ghulam Daraz Shaikh	
APPROVED BY: SAYED ALI ABBAS GILLANI	
DRAWING NO: 0249/PARKS/GD/27	REV: 4
SCALE (A3): N.T.S	SHEET: 0/0





LIGHTING DETAILS

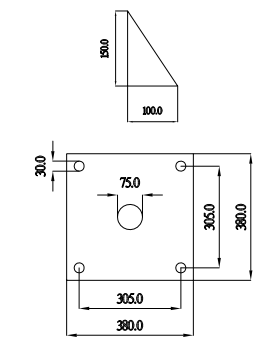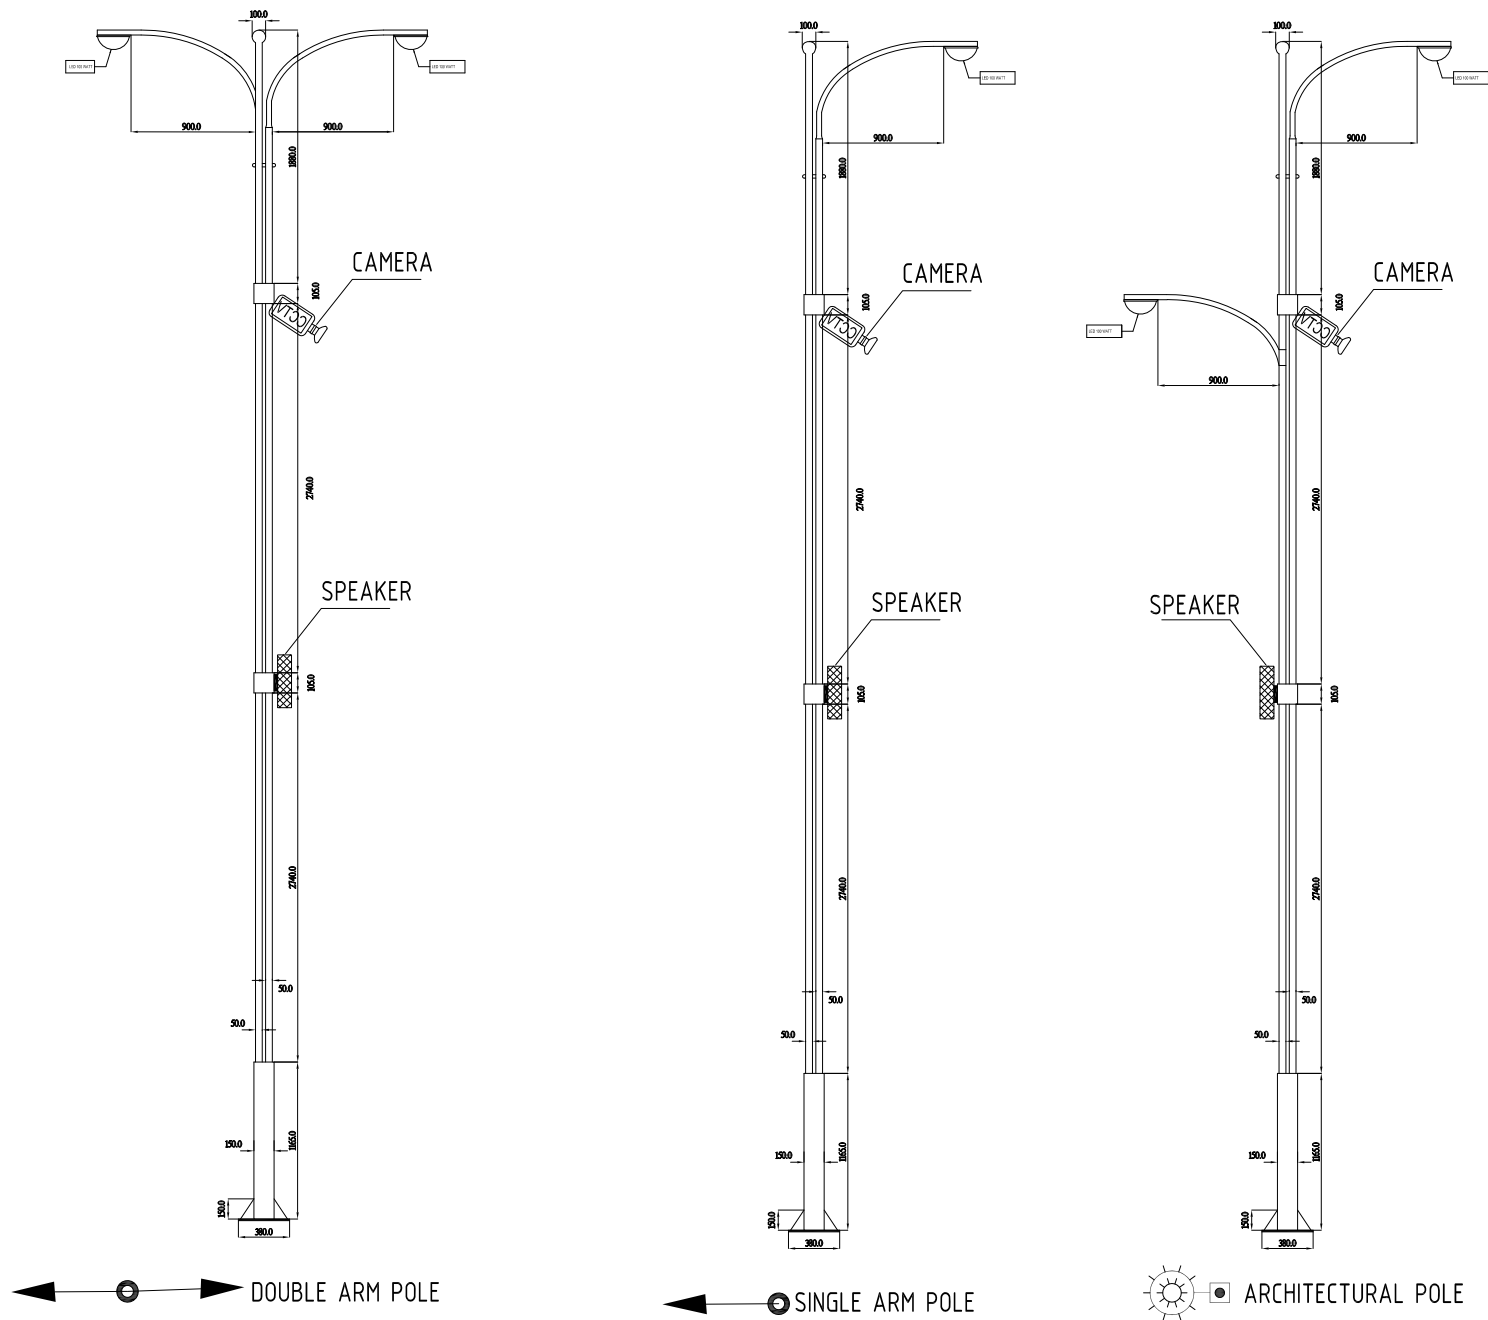

DETAIL OF M.S. PLATE
380x380x12mm THICK.

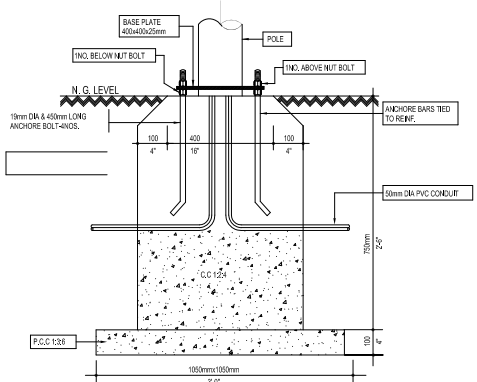

TYPICAL FOUNDATION DETAIL FOR
DOUBLE ARM ROAD LIGHT.

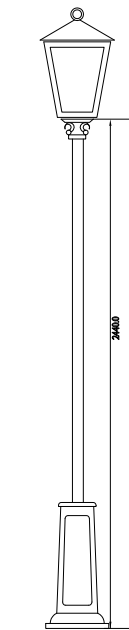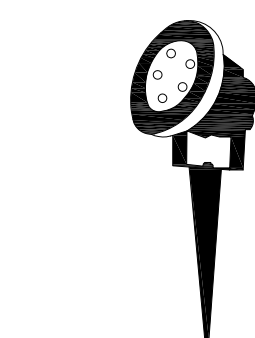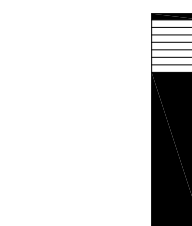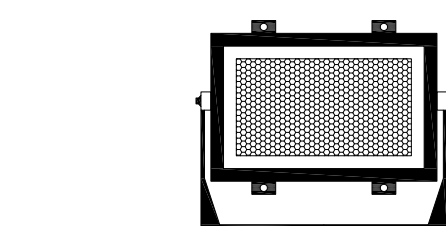

CLIENT:



PROJECT
IMPLEMENTATION
UNIT (PIU) KNIP



CONSULTANTS:
**G3 ENGINEERING
CONSULTANTS (PVT) LTD.**
House No.57-M Gulberg-II, Lahore, Pakistan
Tel : (92-42) 35441641, 35441642
Fax : (92-42) 35441645
E-mail : info@g3ec.com
URL : www.g3ec.com

PROJECT:

REHABILITATION & UP GRADATION OF
BOAT BASIN TO SCHON CHOWRANGI
WITH PEDESTRIAN TRAIL

NOTES:

1. ALL DIMENSIONS ARE IN FEET UNLESS OTHERWISE SPECIFIED.
2. THIS DRAWING IS AN INTELLECTUAL PROPERTY OF G3 ENGINEERING CONSULTANTS (PVT.) LTD. AND CANNOT BE REPRINTED OR REPRODUCED WITHOUT PRIOR APPROVAL OF G3.

REVISIONS:


No.	DESCRIPTION	DATE

TENDER DRAWINGS

DRAWING TITLE:

LIGHTING DETAILS

DRAWN BY: Engr. M.RAFFEH	DATE: Aug 2021
ELECTRICAL ENGINEER: Engr. Ghulam Daraz Shaikh	
APPROVED BY: SAYED ALI ABBAS GILLANI	
DRAWING NO: 0249/PARKS/28	REV: 4
SCALE (A3): N.T.S	SHEET: 0/0

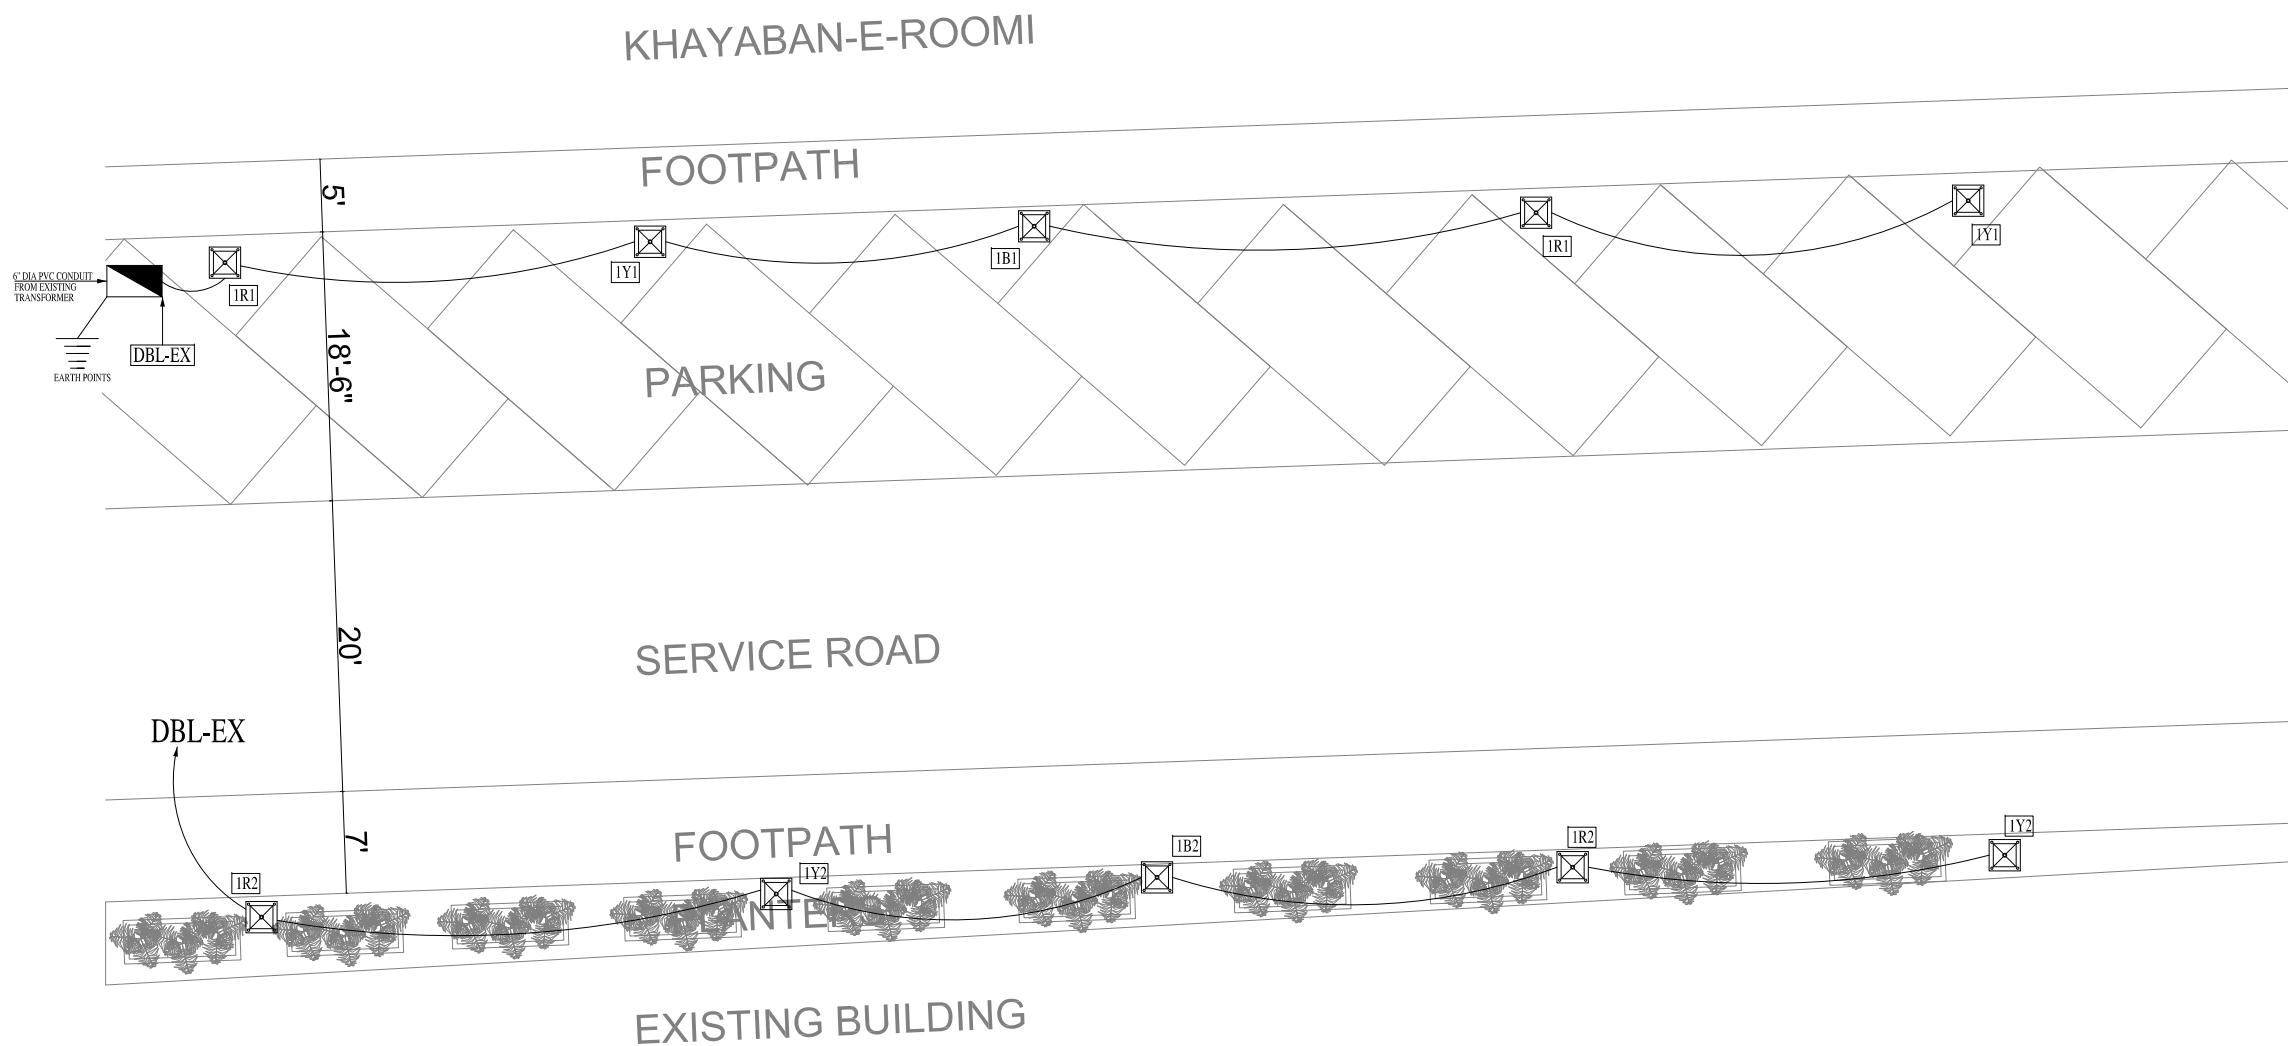

CLIENT:

 PROJECT IMPLEMENTATION UNIT (PIU) KNIP

 CONSULTANTS:

G3 ENGINEERING CONSULTANTS (PVT.) LTD.
House No.57-M Gulberg-II, Lahore, Pakistan

Tel : (92-42) 35441641, 35441642
Fax : (92-42) 35441645
E-mail : info@g3ec.com
URL : www.g3ec.com

PROJECT:

REHABILITATION & UP GRADATION OF BOAT BASIN TO SCHON CHOWRANGI WITH PEDESTRIAN TRAIL

NOTES:

1. ALL DIMENSIONS ARE IN FEET UNLESS OTHERWISE SPECIFIED.
2. THIS DRAWING IS AN INTELLECTUAL PROPERTY OF G3 ENGINEERING CONSULTANTS (PVT.) LTD. AND CANNOT BE REPRINTED OR REPRODUCED WITHOUT PRIOR APPROVAL OF G3.


REVISIONS:

No.	DESCRIPTION	DATE

TENDER DRAWINGS

DRAWING TITLE:
SERVICE ROAD ILLUMINATION AND POWER DISTRIBUTION LAYOUT

DRAWN BY: Engr. M.RAFFEH	DATE: Aug 2021
ELECTRICAL ENGINEER: Engr. Ghulam Daraz Shaikh	
APPROVED BY: SAYED ALI ABBAS GILLANI	
DRAWING NO: 0249/SR/29	REV: 4
SCALE (A3): N.T.S	SHEET: 0/0

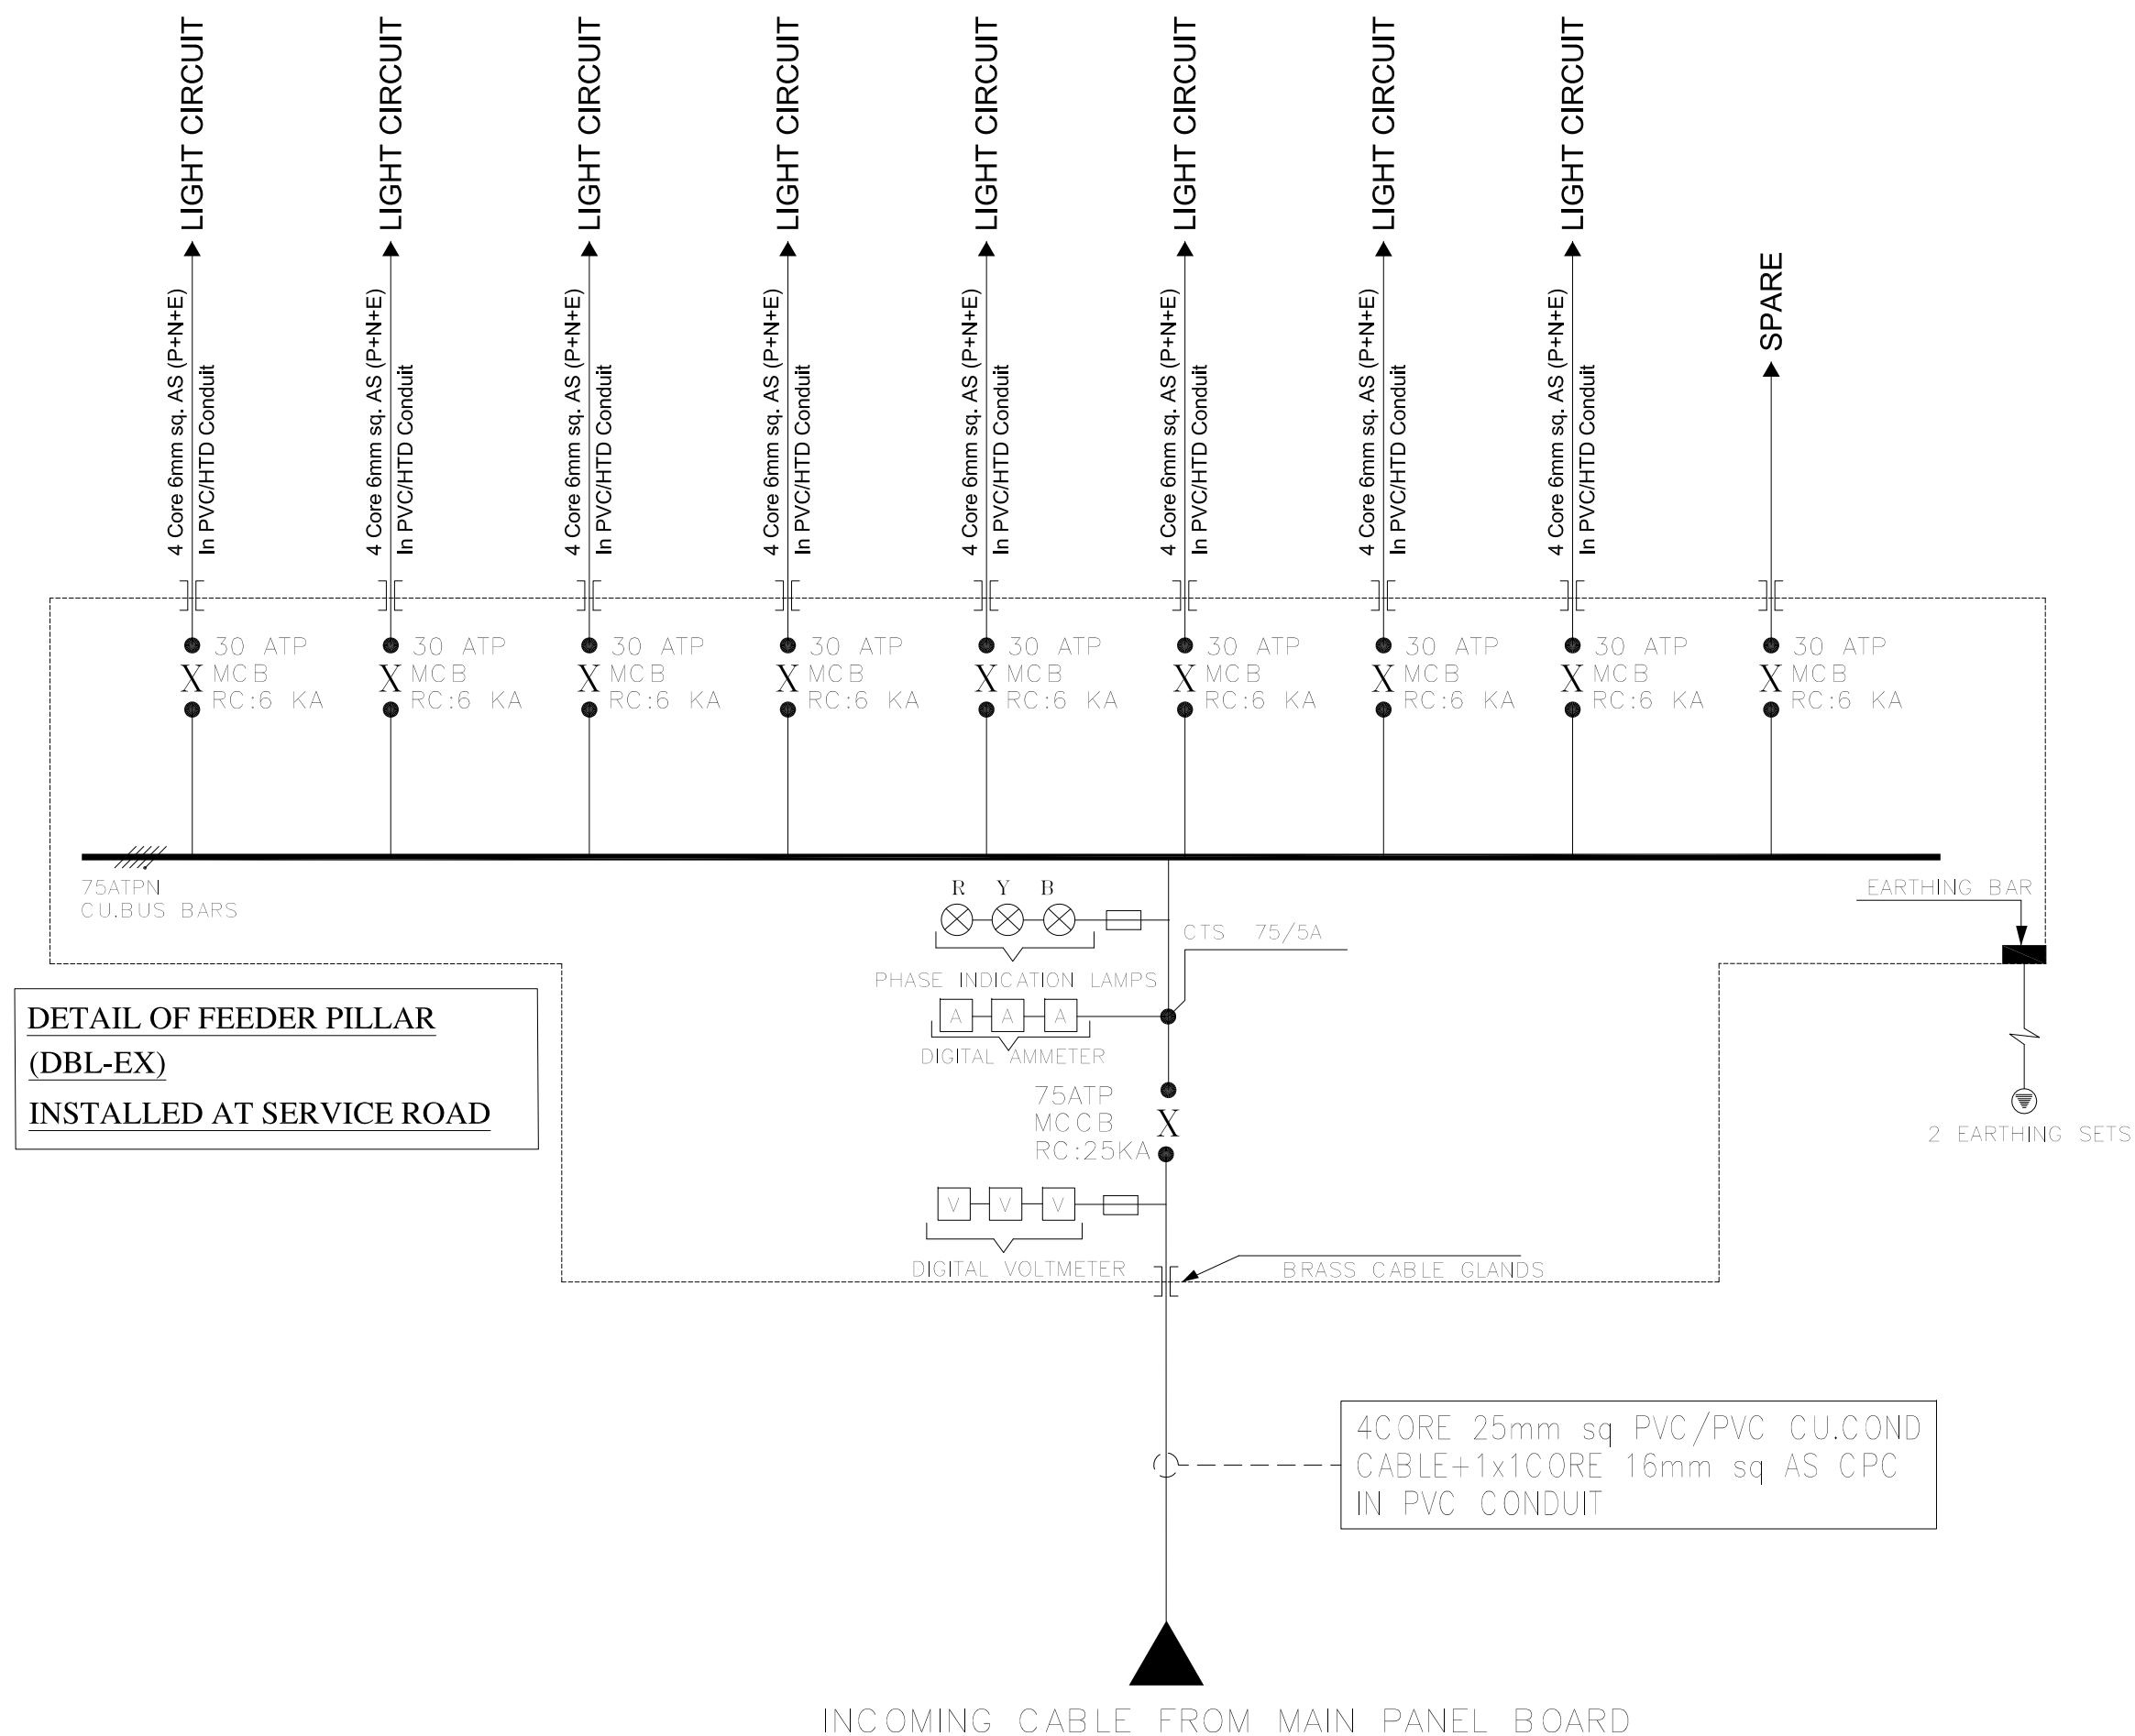

CLIENT:

PROJECT IMPLEMENTATION UNIT (PIU) KNIP

CONSULTANTS:

G3 ENGINEERING CONSULTANTS (PVT) LTD.
House No.57-M Gulberg-III, Lahore, Pakistan

Tel : (92-42) 35441641, 35441642
Fax : (92-42) 35441645
E-mail : info@g3ec.com
URL : www.g3ec.com

PROJECT:

REHABILITATION & UP GRADATION OF BOAT BASIN TO SCHON CHOWRANGI WITH PEDESTRIAN TRAIL

NOTES:

- ALL DIMENSIONS ARE IN FEET UNLESS OTHERWISE SPECIFIED.
- THIS DRAWING IS AN INTELLECTUAL PROPERTY OF G3 ENGINEERING CONSULTANTS (PVT.) LTD. AND CANNOT BE REPRINTED OR REPRODUCED WITHOUT PRIOR APPROVAL OF G3.

REVISIONS:

No.	DESCRIPTION	DATE

TENDER DRAWINGS

DRAWING TITLE:

SINGLE LINE DIAGRAM LAYOUT

DRAWN BY: Engr. M.RAFFEH **DATE:** Aug 2021

ELECTRICAL ENGINEER: Engr. Ghulam Daraz Shaikh

APPROVED BY: SAYED ALI ABBAS GILLANI

 
DRAWING NO: 0249/SR/30 **REV:** 4

SCALE (A3): N.T.S **SHEET:** 0/0

CLIENT:



PROJECT
IMPLEMENTATION
UNIT (PIU) KNIP



CONSULTANTS:

G3 ENGINEERING
CONSULTANTS (PVT.) LTD.
House No.57-M Gulberg-II, Lahore, Pakistan

Tel : (92-42) 35441641, 35441642
Fax : (92-42) 35441645
E-mail : info@g3ec.com
URL : www.g3ec.com

PROJECT:

REHABILITATION & UP GRADATION OF
BOAT BASIN TO SCHON CHOWRANGI
WITH PEDESTRIAN TRAIL

NOTES:

1. ALL DIMENSIONS ARE IN FEET UNLESS OTHERWISE SPECIFIED.
2. THIS DRAWING IS AN INTELLECTUAL PROPERTY OF G3 ENGINEERING CONSULTANTS (PVT.) LTD. AND CANNOT BE REPRINTED OR REPRODUCED WITHOUT PRIOR APPROVAL OF G3.

REVISIONS:

No.	DESCRIPTION	DATE

TENDER DRAWINGS

DRAWING TITLE:

SINGLE LINE DIAGRAM
(ST-05)

DRAWN BY:
Engr. M.RAFFEH

DATE:
Aug 2021

ELECTRICAL ENGINEER:
Engr. Ghulam Daraz Shaikh







APPROVED BY:
SAYED ALI ABBAS GILLANI

DRAWING NO:
0249/SLD/031

REV:
4

SCALE (A3):
N.T.S

SHEET:
0/0

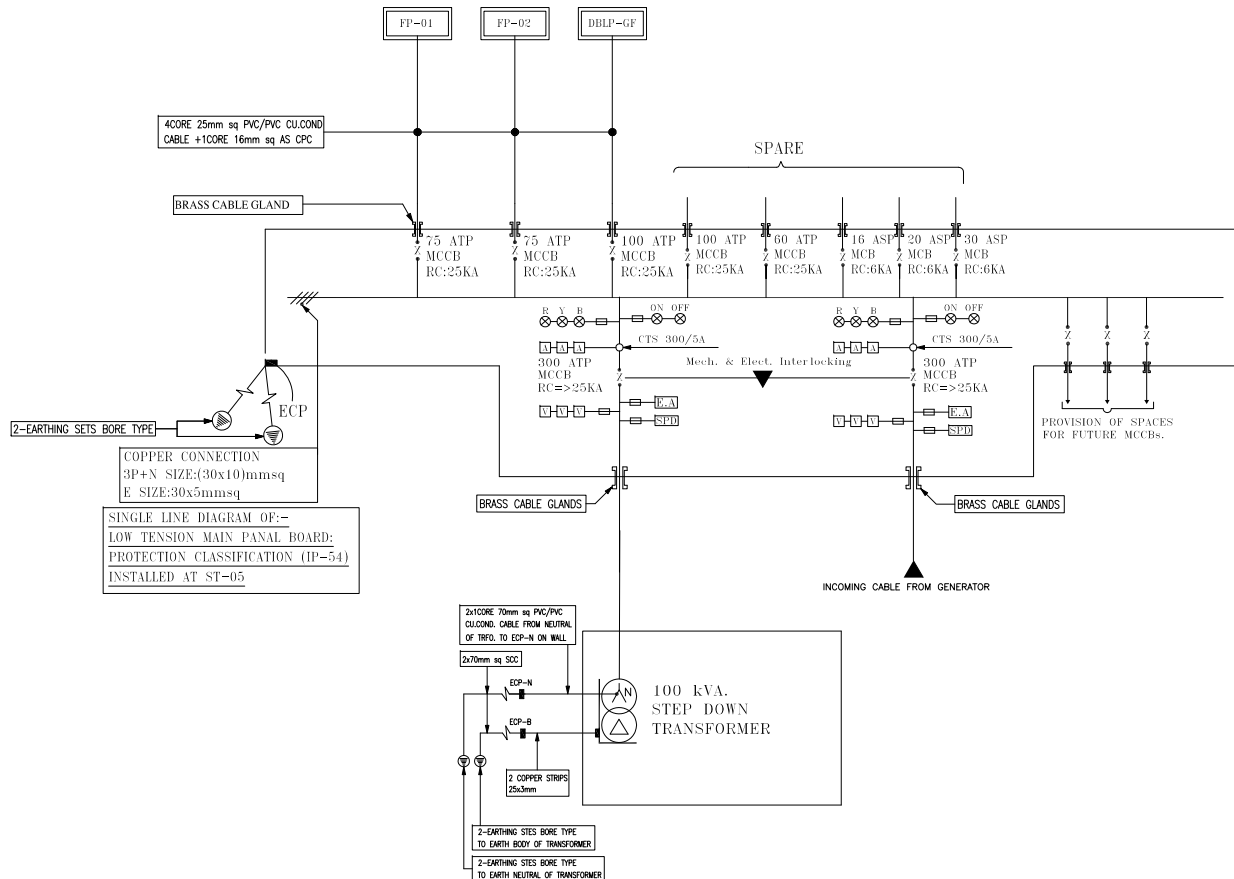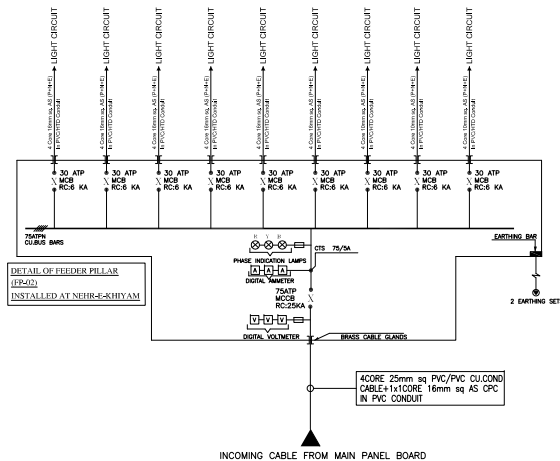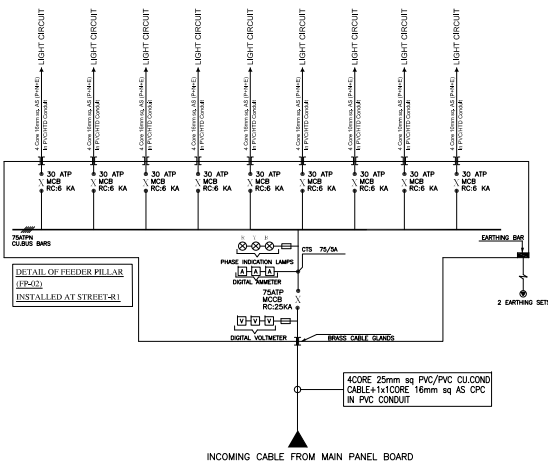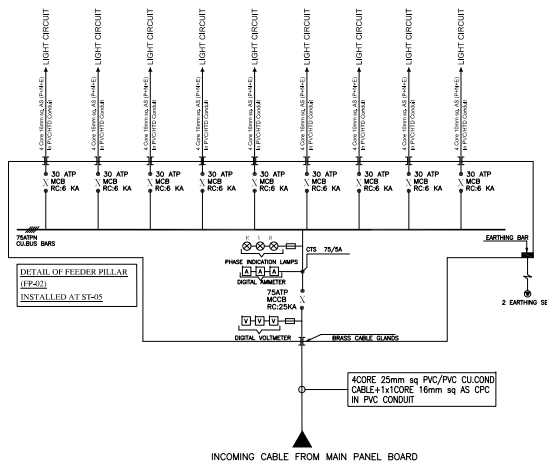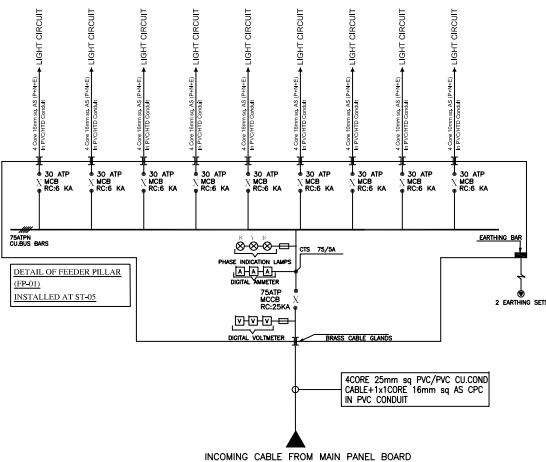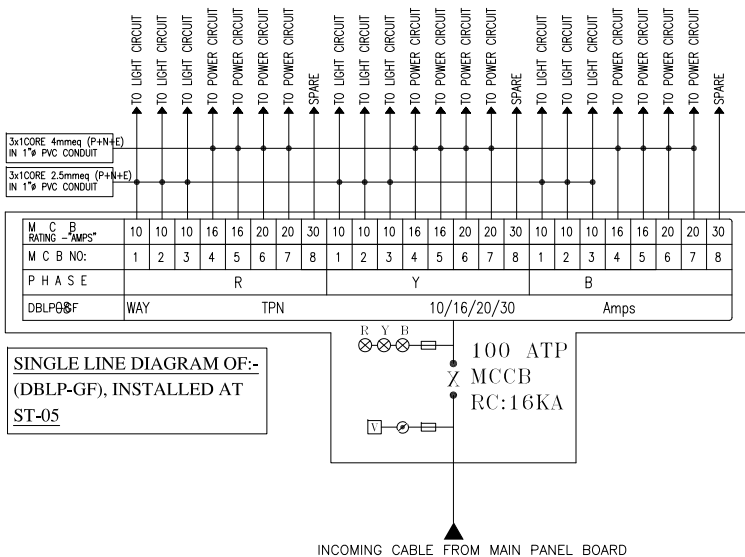

CLIENT:



PROJECT
IMPLEMENTATION
UNIT (PIU) KNIP



CONSULTANTS:

G3 ENGINEERING
CONSULTANTS (PVT.) LTD.
House No.57-M Gulberg-II, Lahore, Pakistan

Tel : (92-42) 35441641, 35441642
Fax : (92-42) 35441645
E-mail : info@g3ec.com
URL : www.g3ec.com

PROJECT:

REHABILITATION & UP GRADATION OF
BOAT BASIN TO SCHON CHOWRANGI
WITH PEDESTRIAN TRAIL

NOTES:

1. ALL DIMENSIONS ARE IN FEET UNLESS OTHERWISE SPECIFIED.
2. THIS DRAWING IS AN INTELLECTUAL PROPERTY OF G3 ENGINEERING CONSULTANTS (PVT.) LTD. AND CANNOT BE REPRINTED OR REPRODUCED WITHOUT PRIOR APPROVAL OF G3.

REVISIONS:

No.	DESCRIPTION	DATE

TENDER DRAWINGS

DRAWING TITLE:

SINGLE LINE DIAGRAM
(ST-06)

DRAWN BY:

Engr. M.RAFFEH

DATE:

Aug 2021

ELECTRICAL ENGINEER:

Engr. Ghulam Daraz Shaikh

APPROVED BY:

SAYED ALI ABBAS GILLANI

DRAWING NO:

0249/SLD/032

REV:







4

SCALE (A3):

N.T.S

SHEET:

0/0

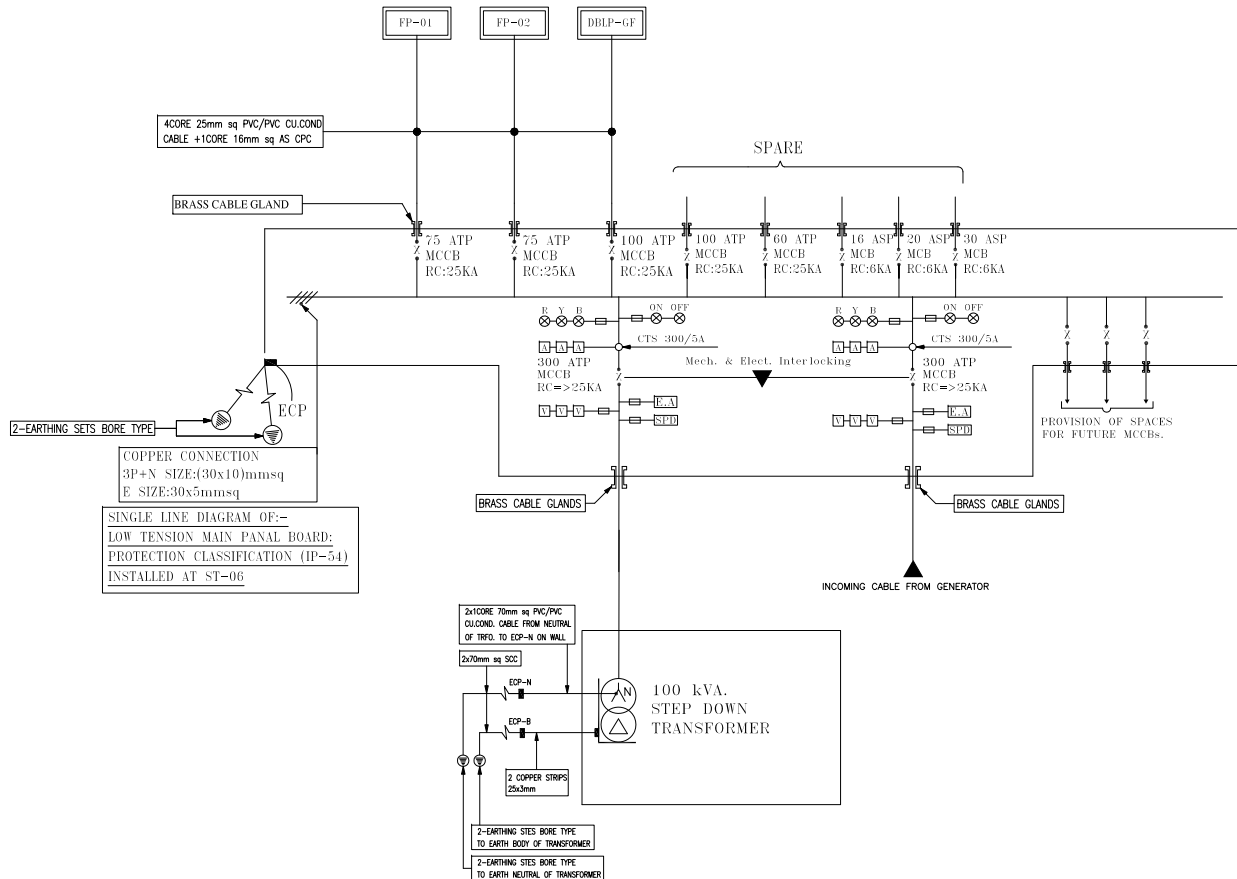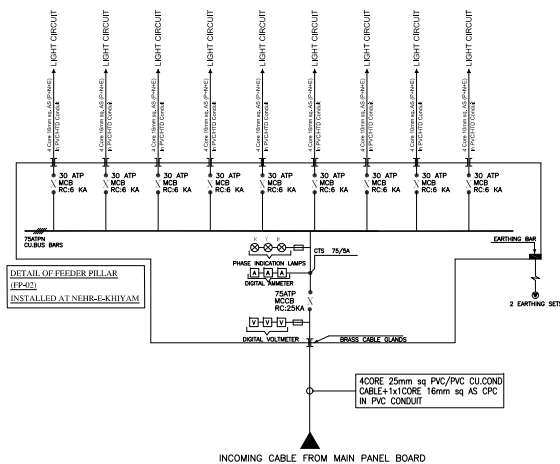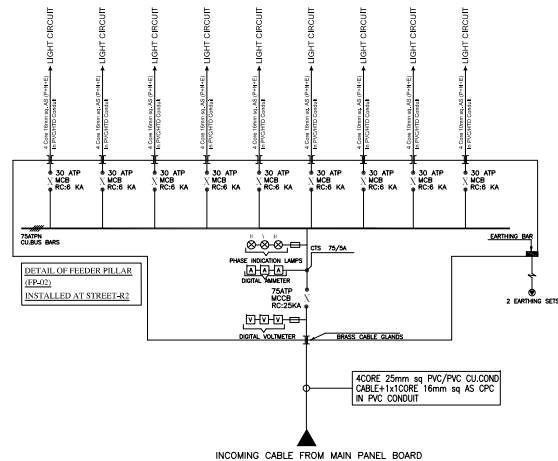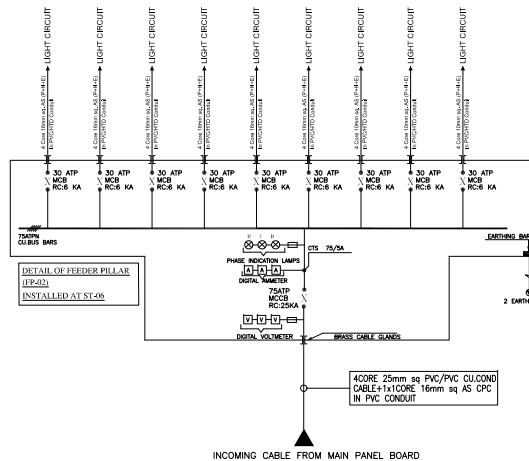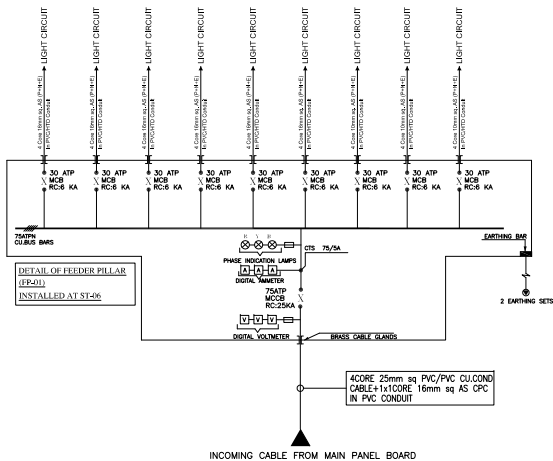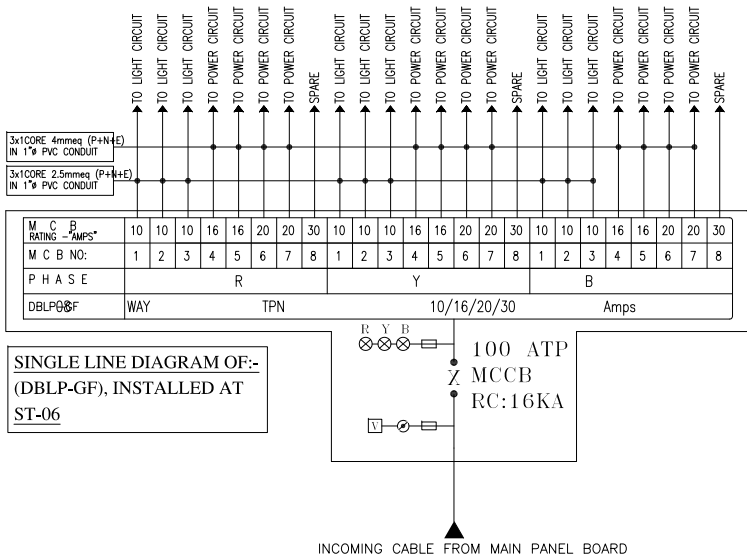



**G3 ENGINEERING
CONSULTANTS (PVT)LTD.**
House No.57-M Gulberg-III, Lahore, Pakista



 
REHABILITATION & UP GRADATION OF BOAT BASIN TO SCHON CHOWRANGI WITH PEDESTRIAN TRAIL

1. ALL DIMENSIONS ARE IN FEET UNLESS OTHERWISE SPECIFIED.
2. THIS DRAWING IS AN INTELLECTUAL PROPERTY OF G3 ENGINEERING CONSULTANTS (PVT.) LTD. AND CANNOT BE REPRINTED OR REPRODUCED WITHOUT PRIOR APPROVAL OF G3.

[illegible]

SINGLE LINE DIAGRAM (ST-08)

0/0

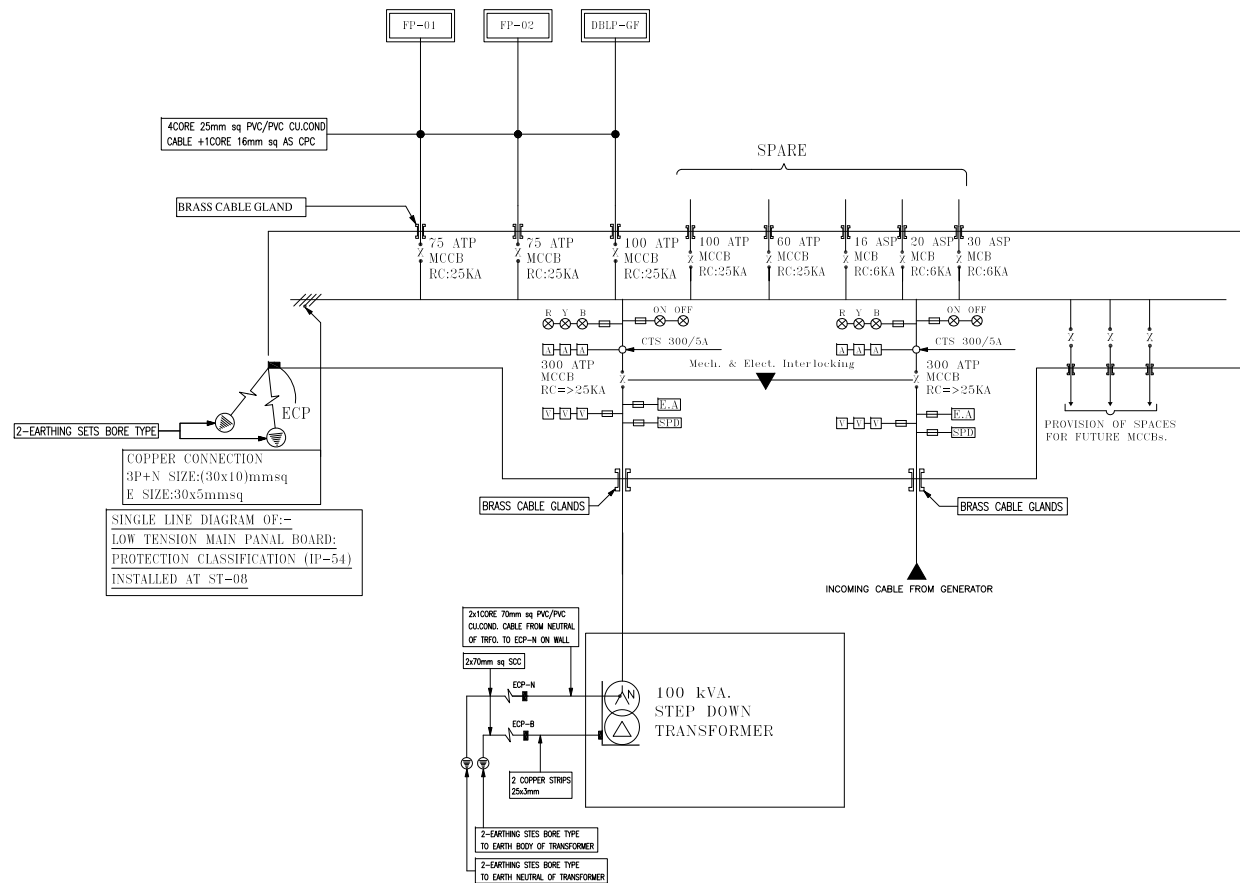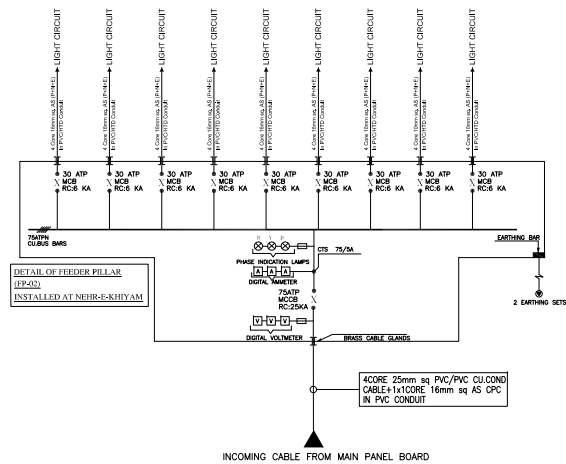

CLIENT:



PROJECT
IMPLEMENTATION
UNIT (PIU) KNIP



CONSULTANTS:

G3 ENGINEERING
CONSULTANTS (PVT) LTD.
House No.57-M Gulberg-II, Lahore, Pakistan

Tel : (92-42) 35441641, 35441642
Fax : (92-42) 35441645
E-mail : info@g3ec.com
URL : www.g3ec.com

PROJECT:

REHABILITATION & UP GRADATION OF
BOAT BASIN TO SCHON CHOWRANGI
WITH PEDESTRIAN TRAIL

NOTES:

1. ALL DIMENSIONS ARE IN FEET UNLESS OTHERWISE SPECIFIED.
2. THIS DRAWING IS AN INTELLECTUAL PROPERTY OF G3 ENGINEERING CONSULTANTS (PVT.) LTD. AND CANNOT BE REPRINTED OR REPRODUCED WITHOUT PRIOR APPROVAL OF G3.

REVISIONS:


No.	DESCRIPTION	DATE

TENDER DRAWINGS


DRAWING TITLE:

SINGLE LINE DIAGRAM
(ST-09)


DRAWN BY: Engr. M.RAFFEH	DATE: Aug 2021
ELECTRICAL ENGINEER: Engr. Ghulam Daraz Shaikh	
APPROVED BY: SAYED ALI ABBAS GILLANI	
DRAWING NO: 0249/SLD/034	REV: 4
SCALE (A3): N.T.S	SHEET: 0/0

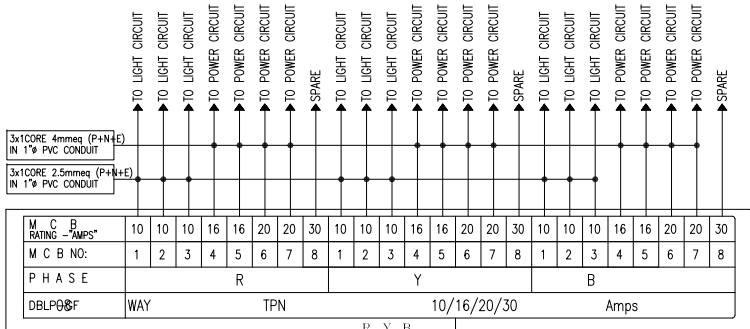


INCOMING CABLE FROM MAIN PANEL BOARD

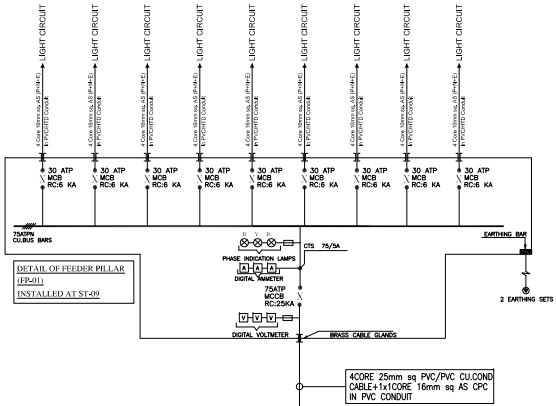


INCOMING CABLE FROM MAIN PANEL BOARD

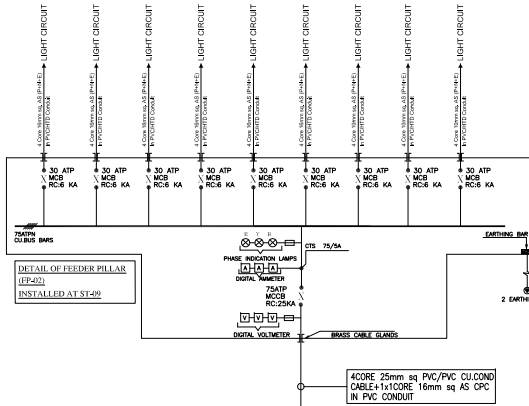


INCOMING CABLE FROM MAIN PANEL BOARD

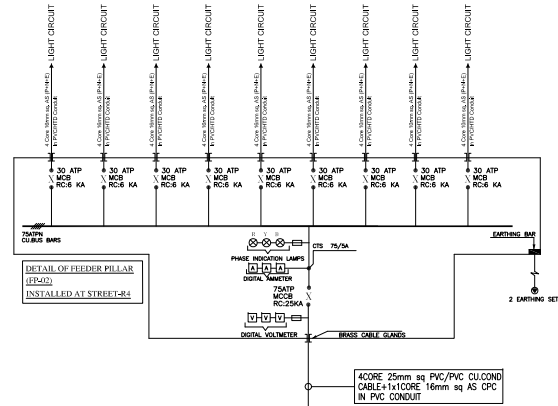


INCOMING CABLE FROM MAIN PANEL BOARD

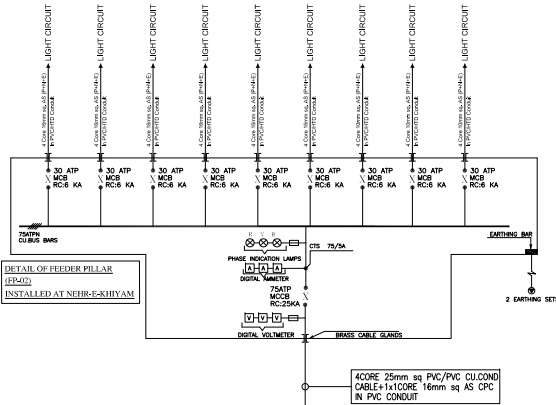

INCOMING CABLE FROM MAIN PANEL BOARD

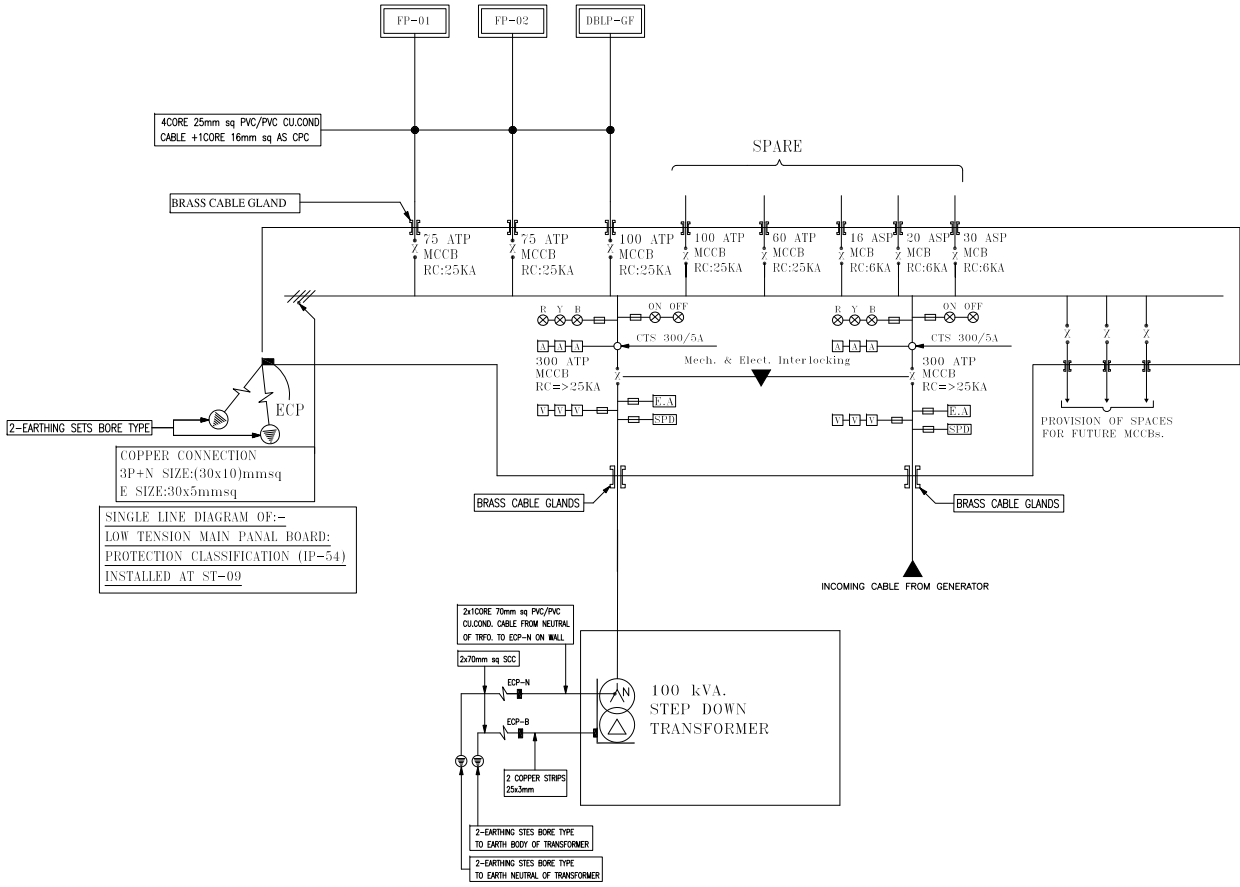

SINGLE LINE DIAGRAM OF:-
LOW TENSION MAIN PANEL BOARD:
PROTECTION CLASSIFICATION (IP-54)
INSTALLED AT ST-09

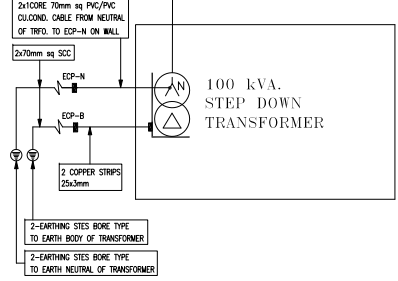






**G3 ENGINEERING
CONSULTANTS (PVT)LTD.**
House No.57-M Gulberg-III, Lahore, Pakistan

REHABILITATION & UP GRADATION OF BOAT BASIN TO SCHON CHOWRANGI WITH PEDESTRIAN TRAIL

1. ALL DIMENSIONS ARE IN FEET UNLESS OTHERWISE SPECIFIED.
2. THIS DRAWING IS AN INTELLECTUAL PROPERTY OF G3 ENGINEERING CONSULTANTS (PVT.) LTD. AND CANNOT BE REPRINTED OR REPRODUCED WITHOUT PRIOR APPROVAL OF G3.

[illegible]

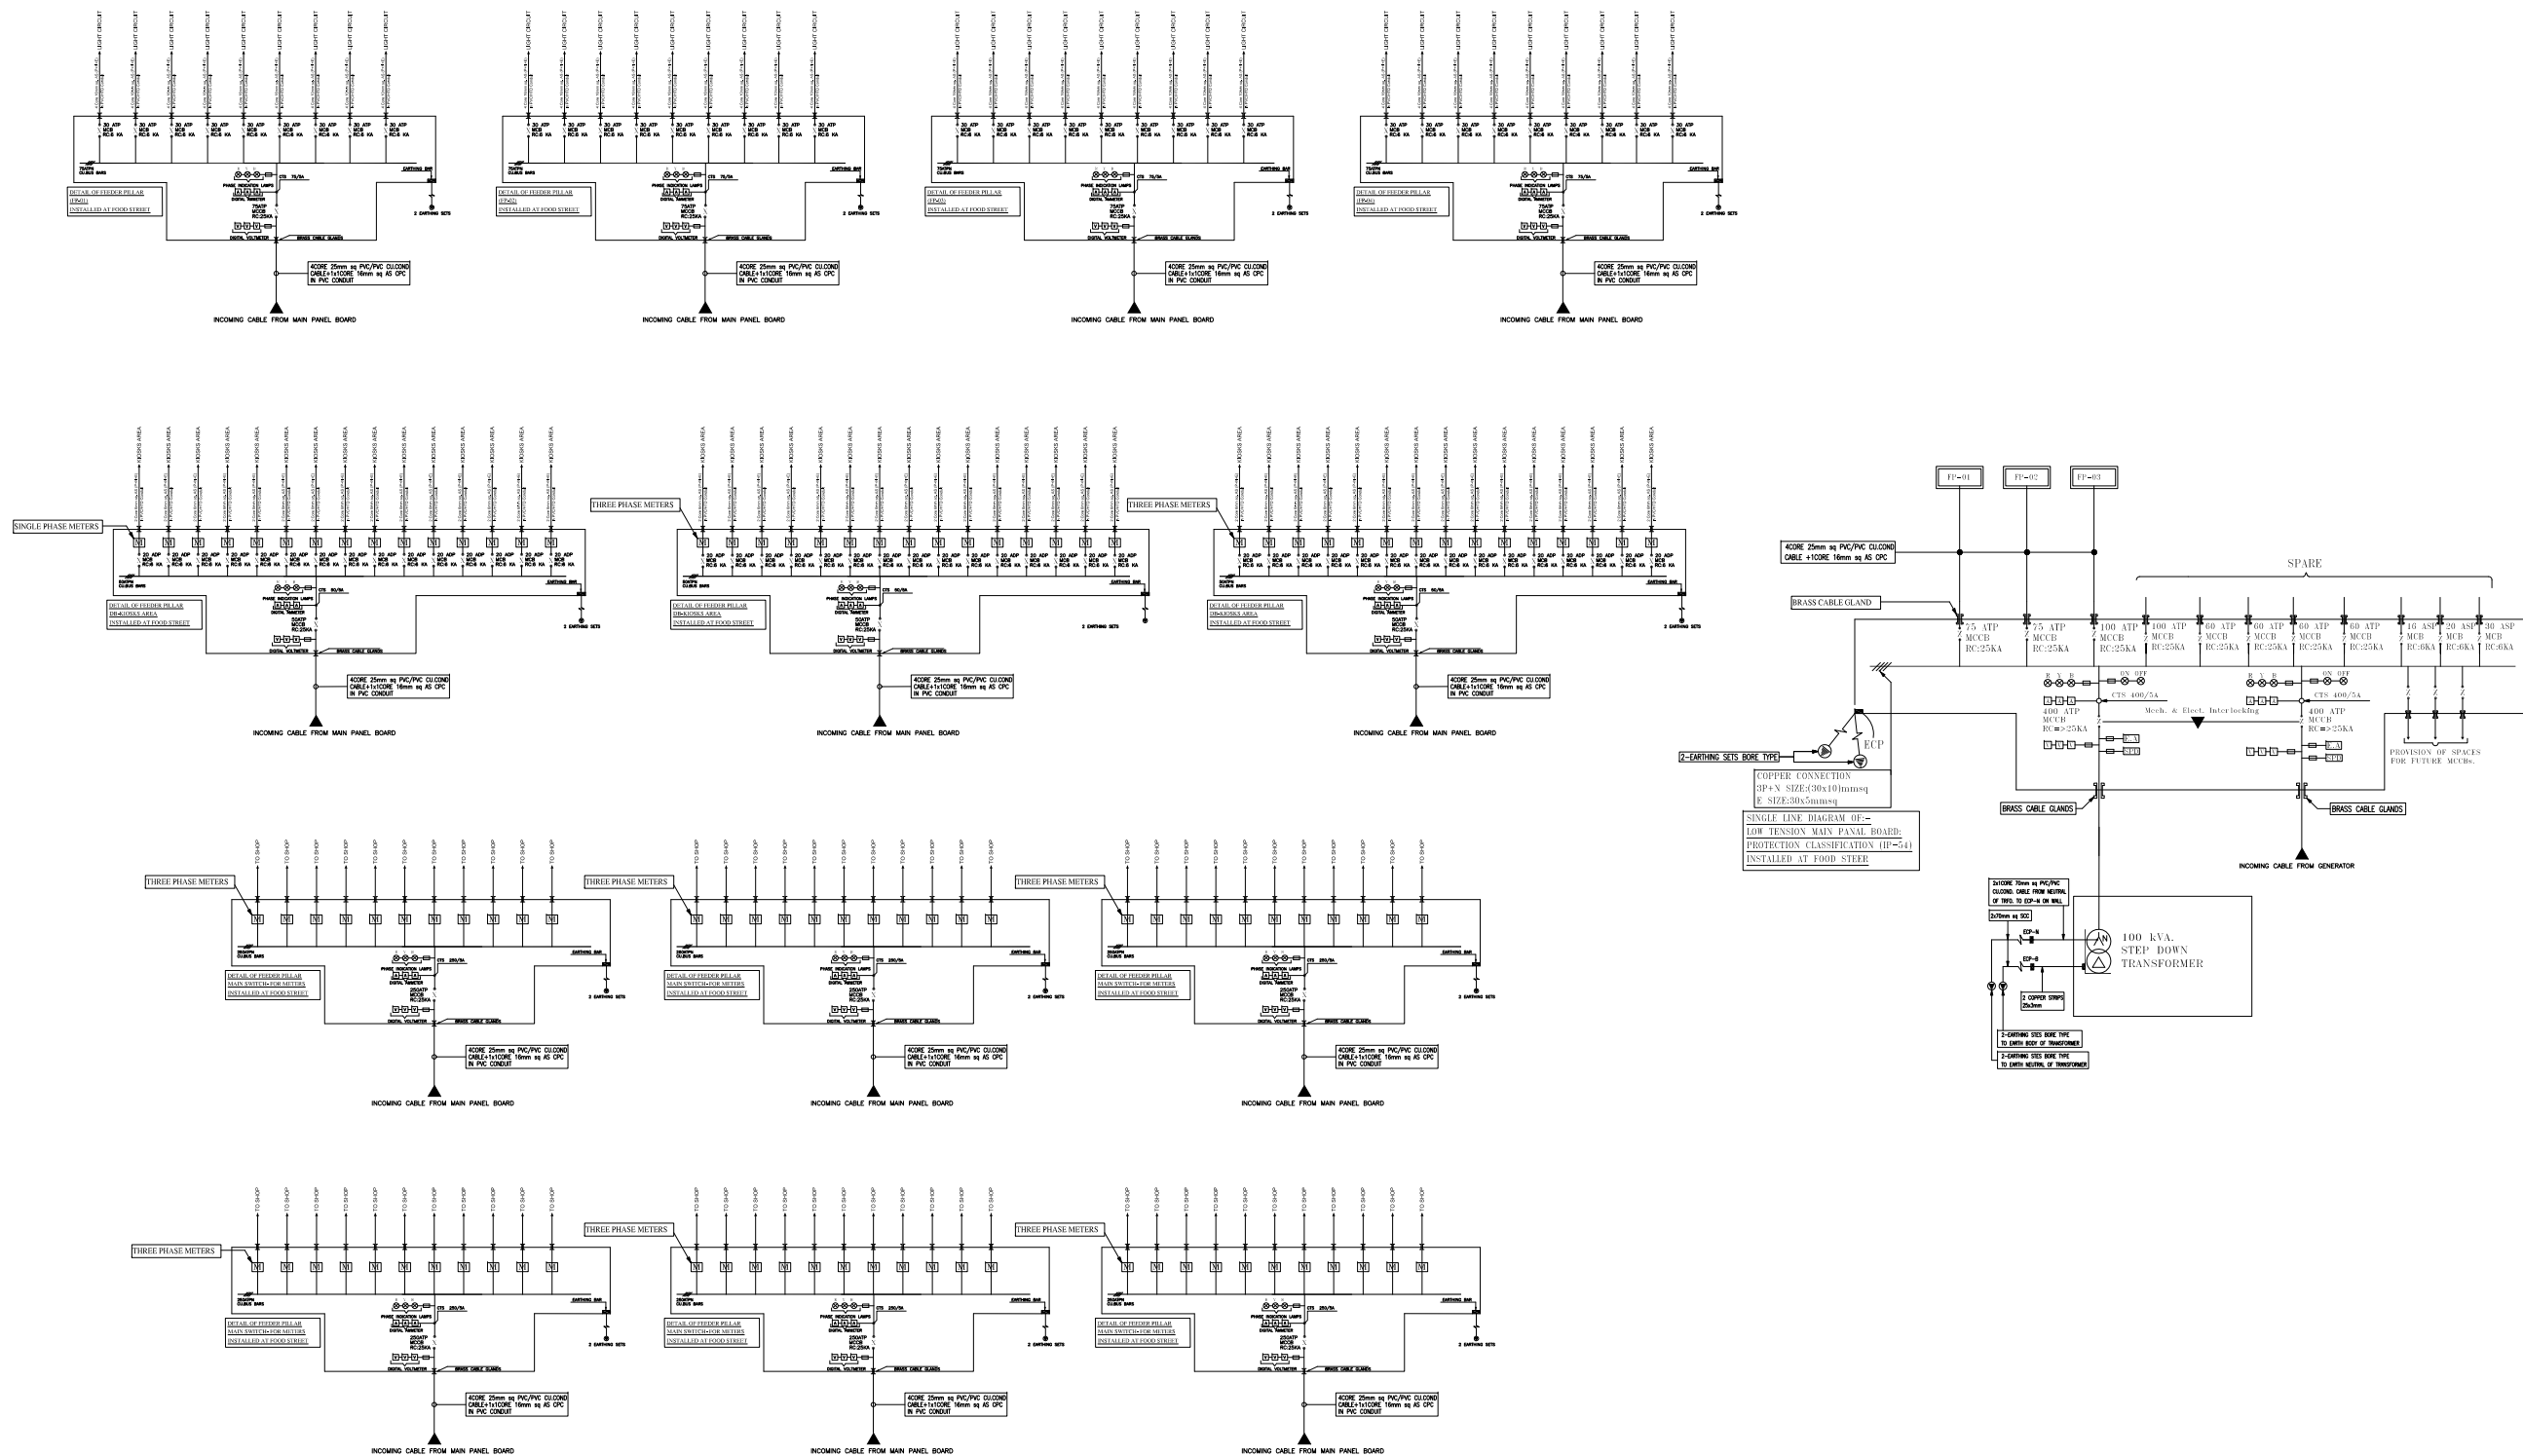

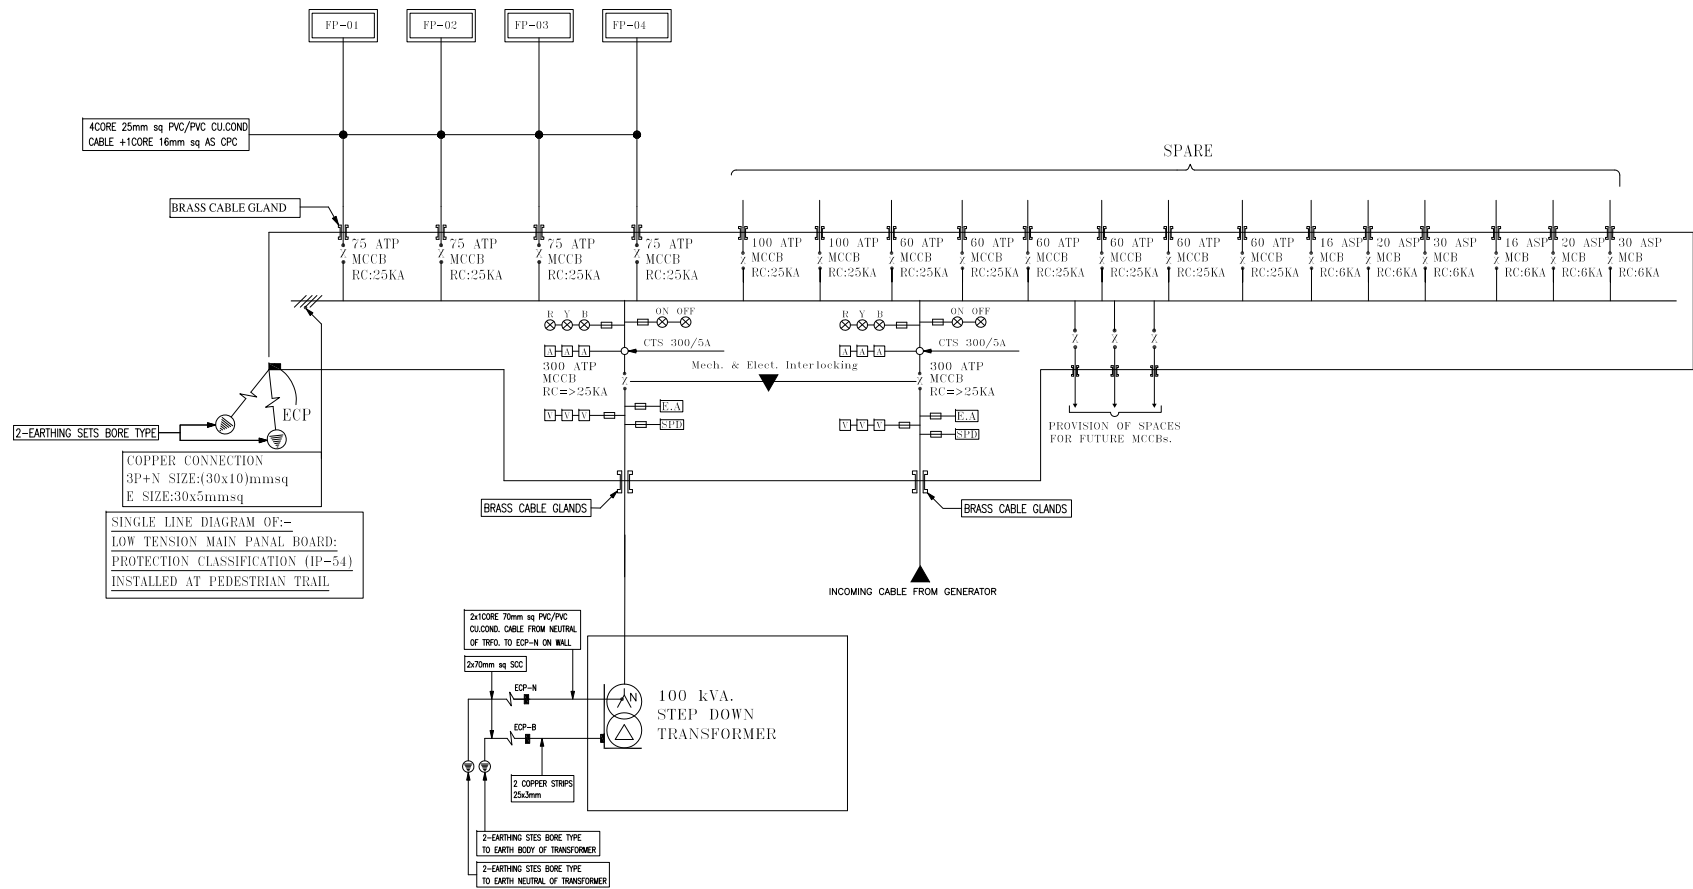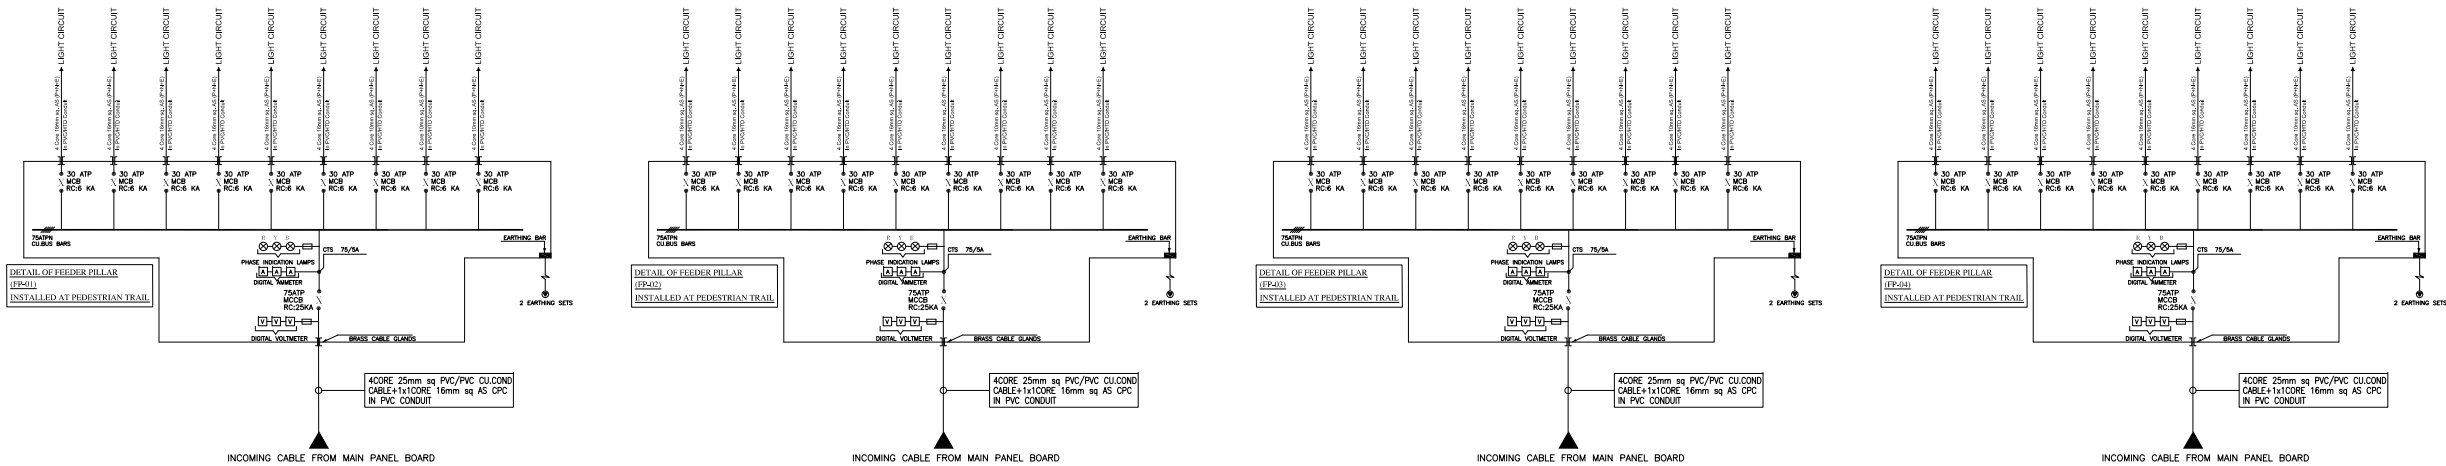

CLIENT:



PROJECT
IMPLEMENTATION
UNIT (PIU) KNIP



CONSULTANTS:

G3 ENGINEERING
CONSULTANTS (PVT.) LTD.
House No.57-M Gulberg-II, Lahore, Pakistan

Tel : (92-42) 35441641, 35441642
Fax : (92-42) 35441645
E-mail : info@g3ec.com
URL : www.g3ec.com

PROJECT:

REHABILITATION & UP GRADATION OF
BOAT BASIN TO SCHON CHOWRANGI
WITH PEDESTRIAN TRAIL

NOTES:

1. ALL DIMENSIONS ARE IN FEET UNLESS OTHERWISE SPECIFIED.
2. THIS DRAWING IS AN INTELLECTUAL PROPERTY OF G3 ENGINEERING CONSULTANTS (PVT.) LTD. AND CANNOT BE REPRINTED OR REPRODUCED WITHOUT PRIOR APPROVAL OF G3.

REVISIONS:

No.	DESCRIPTION	DATE

TENDER DRAWINGS

DRAWING TITLE:

SINGLE LINE DIAGRAM
(PEDESTRIAN TRAIL)

DRAWN BY: Engr. M.RAFFEH	DATE: Aug 2021
ELECTRICAL ENGINEER: Engr. Ghulam Daraz Shaikh	
APPROVED BY: SAYED ALI ABBAS GILLANI	
DRAWING NO: 0249/SLD/036	REV: 4
SCALE (A3): N.T.S	SHEET: 0/0

REHABILITATION & UP-GRADATION OF GIZRI SPORTS GROUND


LIST OF DRAWINGS
ELECTRICAL DRAWINGS

S.NO	DRAWING DETAIL	DRAWING NO.
1.	LIST OF DRAWING	0249/PG/01
2.	PLAY GROUND ILLUMINATION LAYOUT PLAN	0249/PG/02
3.	POWER DISTRIBUTION LAYOUT PLAN	0249/PG/03
4.	CCTV LAYOUT PLAN	0249/PG/04
5.	PUBLIC ADDRESS SYSTEM PLAN	0249/PG/05
6.	EXISTING PAVILION ILLUMINATION PLAN	0249/PG/EP/06
7	PROPOSED PAVILION ILLUMINATION PLAN	0249/PG/PP/07
8	BAKERY CUM SHOP ILLUMINATION LAYOUT PLAN	0249/PG/SH/08
9	ENTRANCE GATE PLAY GROUND	0249/G/EG/09
10	BOUNDARY WALL PLAY GROUND	0249/PG/BW/10
11	STREET POLE LAYOUT PLAN	0249/PG/SP/11
12	DISTRIBUTION BOARD DETAIL	0249/PG/SLD/12
13	MAIN PANEL BOARD	0249/PG/SLD/13

CLIENT:



 PROJECT
IMPLEMENTATION
UNIT (PIU) KNIP



CONSULTANTS:
**G3 ENGINEERING
CONSULTANTS (PVT.) LTD.**
House No.57-M Gulberg-II, Lahore, Pakistan
Tel : (92-42) 35441641, 35441642
Fax : (92-42) 35441645
E-mail : Info@g3ec.com
URL : www.g3ec.com

PROJECT:

REHABILITATION & UP GRADATION
OF GIZRI SPORTS GROUND

NOTES:
1. ALL DIMENSIONS ARE IN FEET UNLESS
OTHERWISE SPECIFIED.
2. THIS DRAWING IS AN INTELLECTUAL PROPERTY
OF G3 ENGINEERING CONSULTANTS (PVT.) LTD.
AND CANNOT BE REPRINTED OR REPRODUCED
WITHOUT PRIOR APPROVAL OF G3.

REVISIONS:


No.	DESCRIPTION	DATE

TENDER DRAWINGS

DRAWING TITLE:

LIST OF DRAWINGS


DRAWN BY: M.RAFFEH	DATE: Aug 2021
ELECTRICAL ENGINEER: Engr. Ghulam Daraz Shaikh	
APPROVED BY: Engr. SAYED ALI ABBAS GILLANI	
DRAWING NO: 0249/PG/01	REV: 4
SCALE (A3): N.T.S	SHEET: 1/11

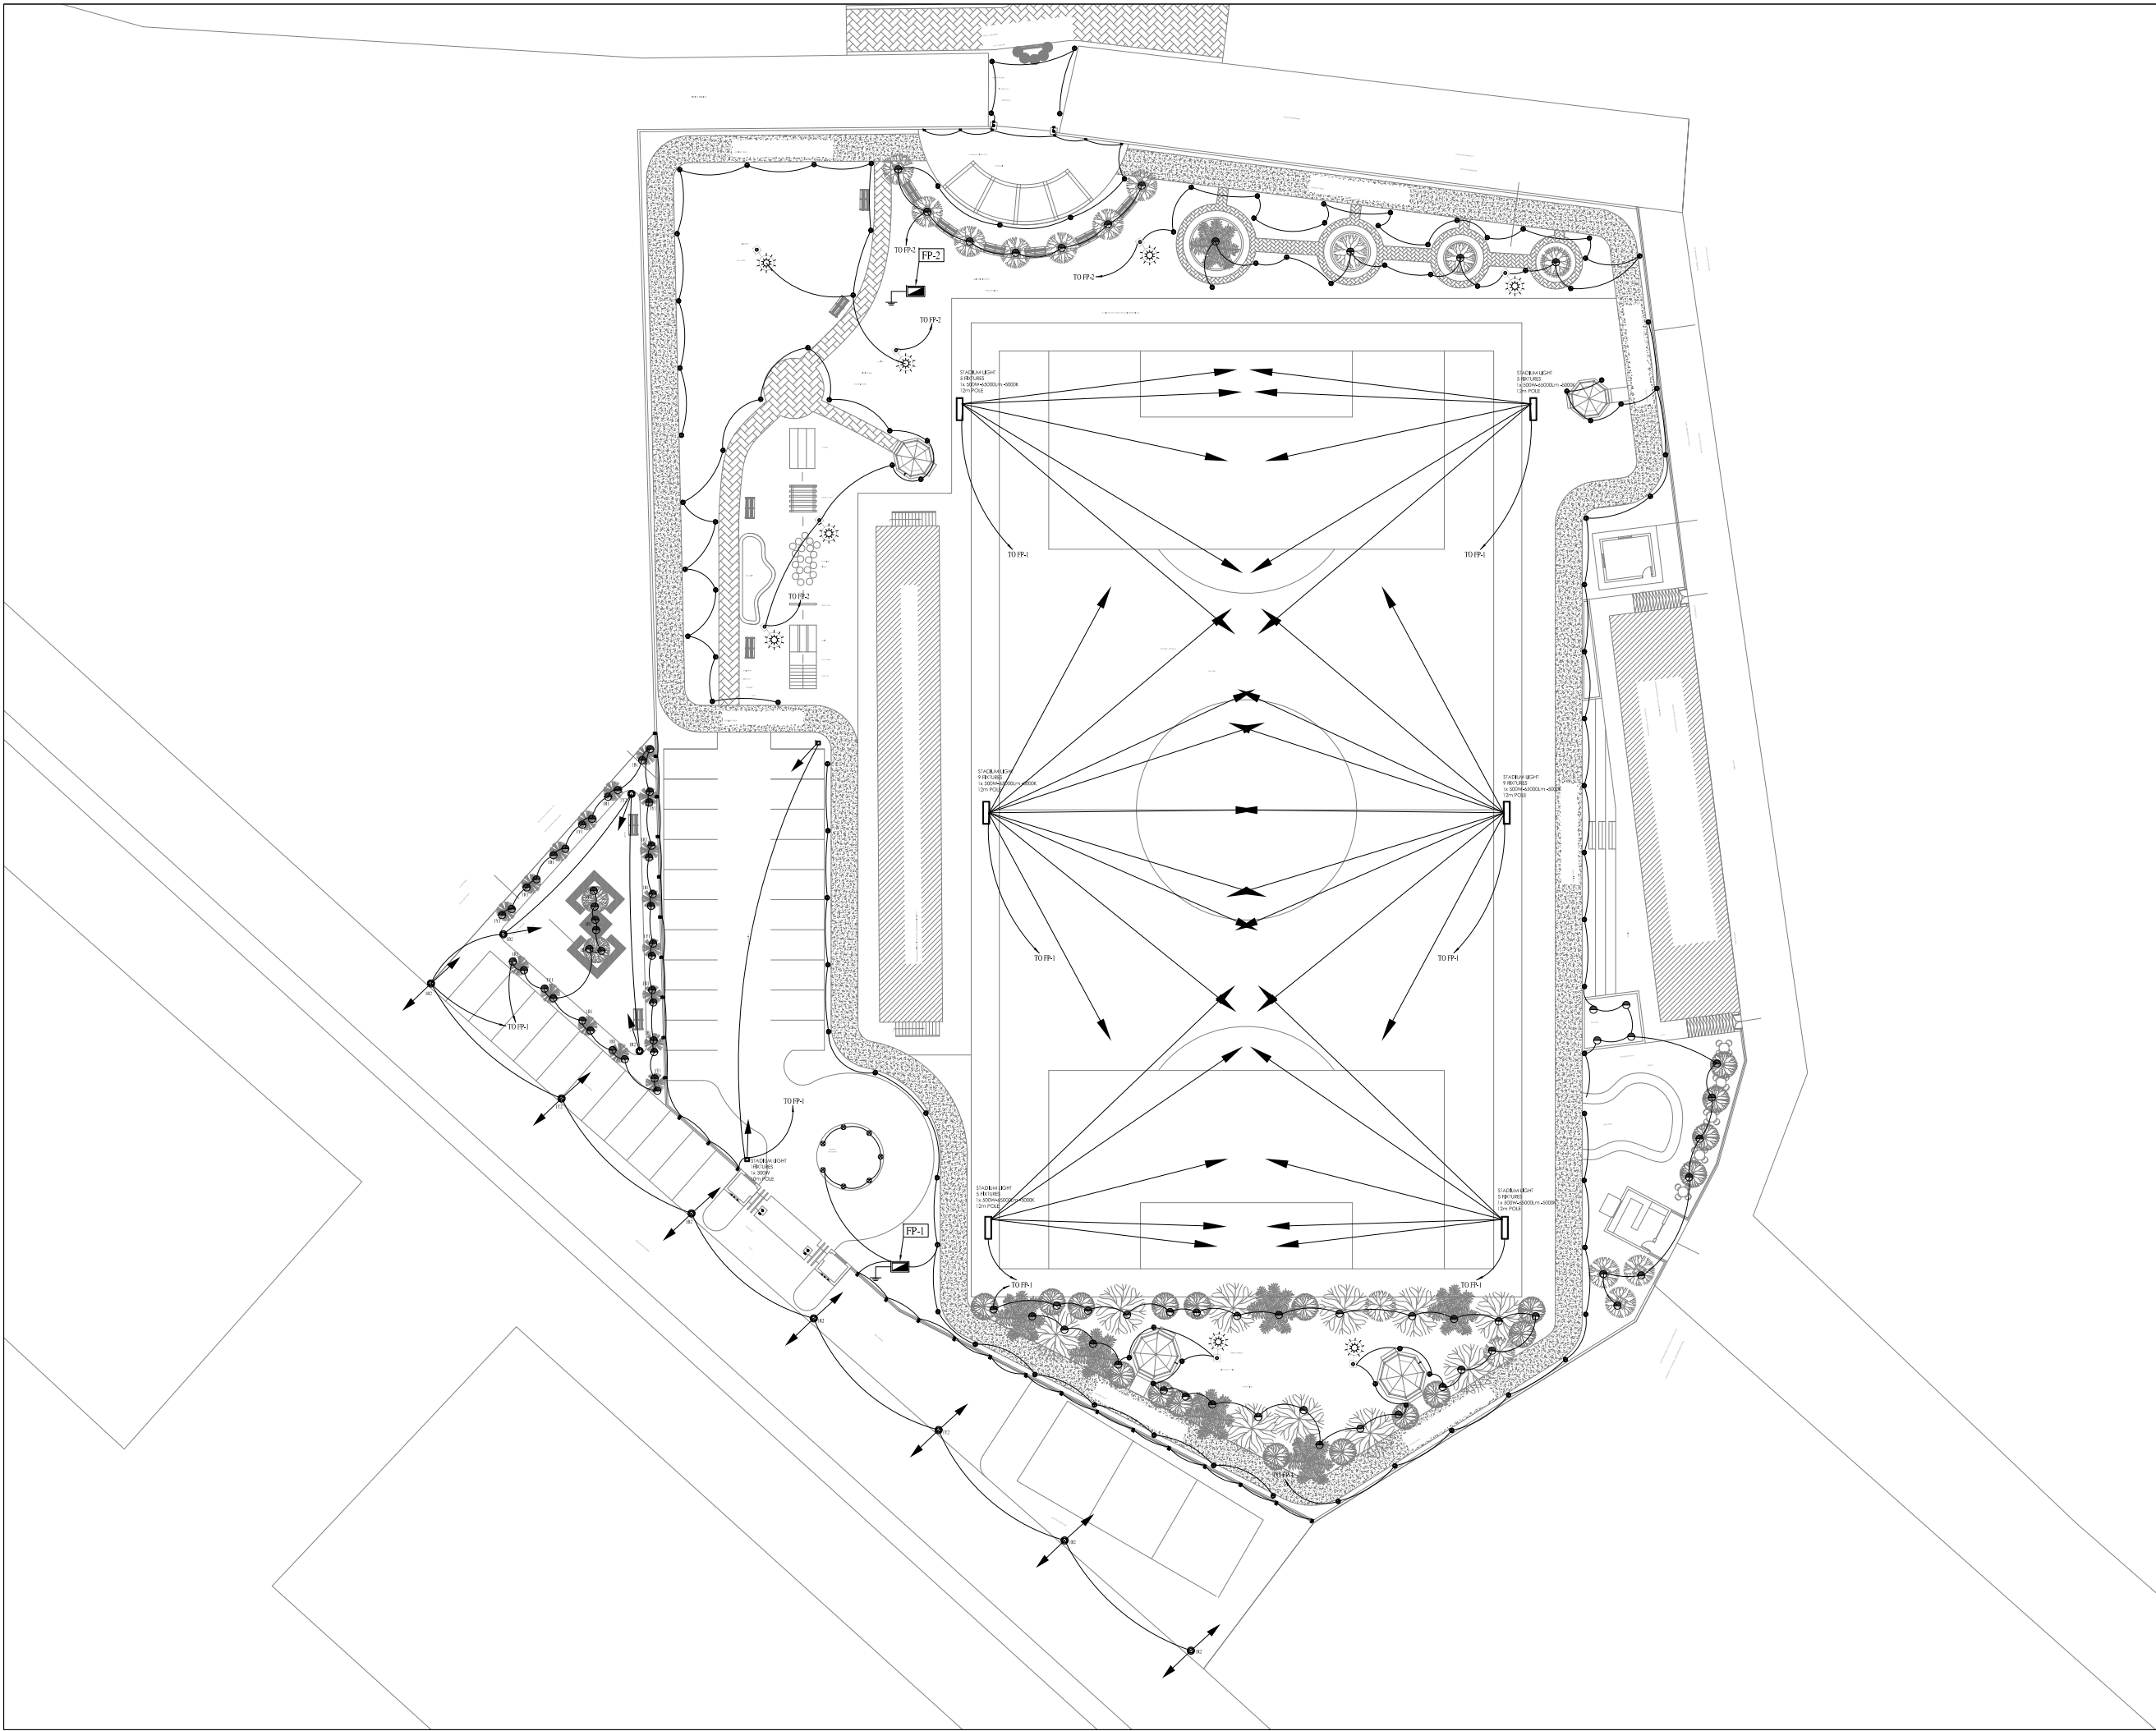

CLIENT:



 PROJECT
IMPLEMENTATION
UNIT (PIU) KNIP



CONSULTANTS:

**G3 ENGINEERING
CONSULTANTS (PVT) LTD.**
House No.57-M Gulberg-II, Lahore, Pakistan

Tel : (92-42) 35441641, 35441642
Fax : (92-42) 35441645
E-mail : info@g3ec.com
URL : www.g3ec.com

PROJECT:

REHABILITATION & UP GRADATION
OF GIZRI SPORTS GROUND

NOTES:

1. ALL DIMENSIONS ARE IN FEET UNLESS OTHERWISE SPECIFIED.
2. THIS DRAWING IS AN INTELLECTUAL PROPERTY OF G3 ENGINEERING CONSULTANTS (PVT.) LTD. AND CANNOT BE REPRINTED OR REPRODUCED WITHOUT PRIOR APPROVAL OF G3.

REVISIONS:

No.	DESCRIPTION	DATE

TENDER DRAWINGS

DRAWING TITLE:

PLAY GROUND
ILLUMINATION
LAYOUT PLAN

DRAWN BY:
M.RAFFEH

DATE:
Aug 2021

ELECTRICAL ENGINEER:
Engr. Ghulam Daraz Shaikh


APPROVED BY:
Engr. SAYED ALI ABBAS GILLANI

DRAWING NO:
0249/PG/02

REV:
4

SCALE (A3):
N.T.S


SHEET:
2/11

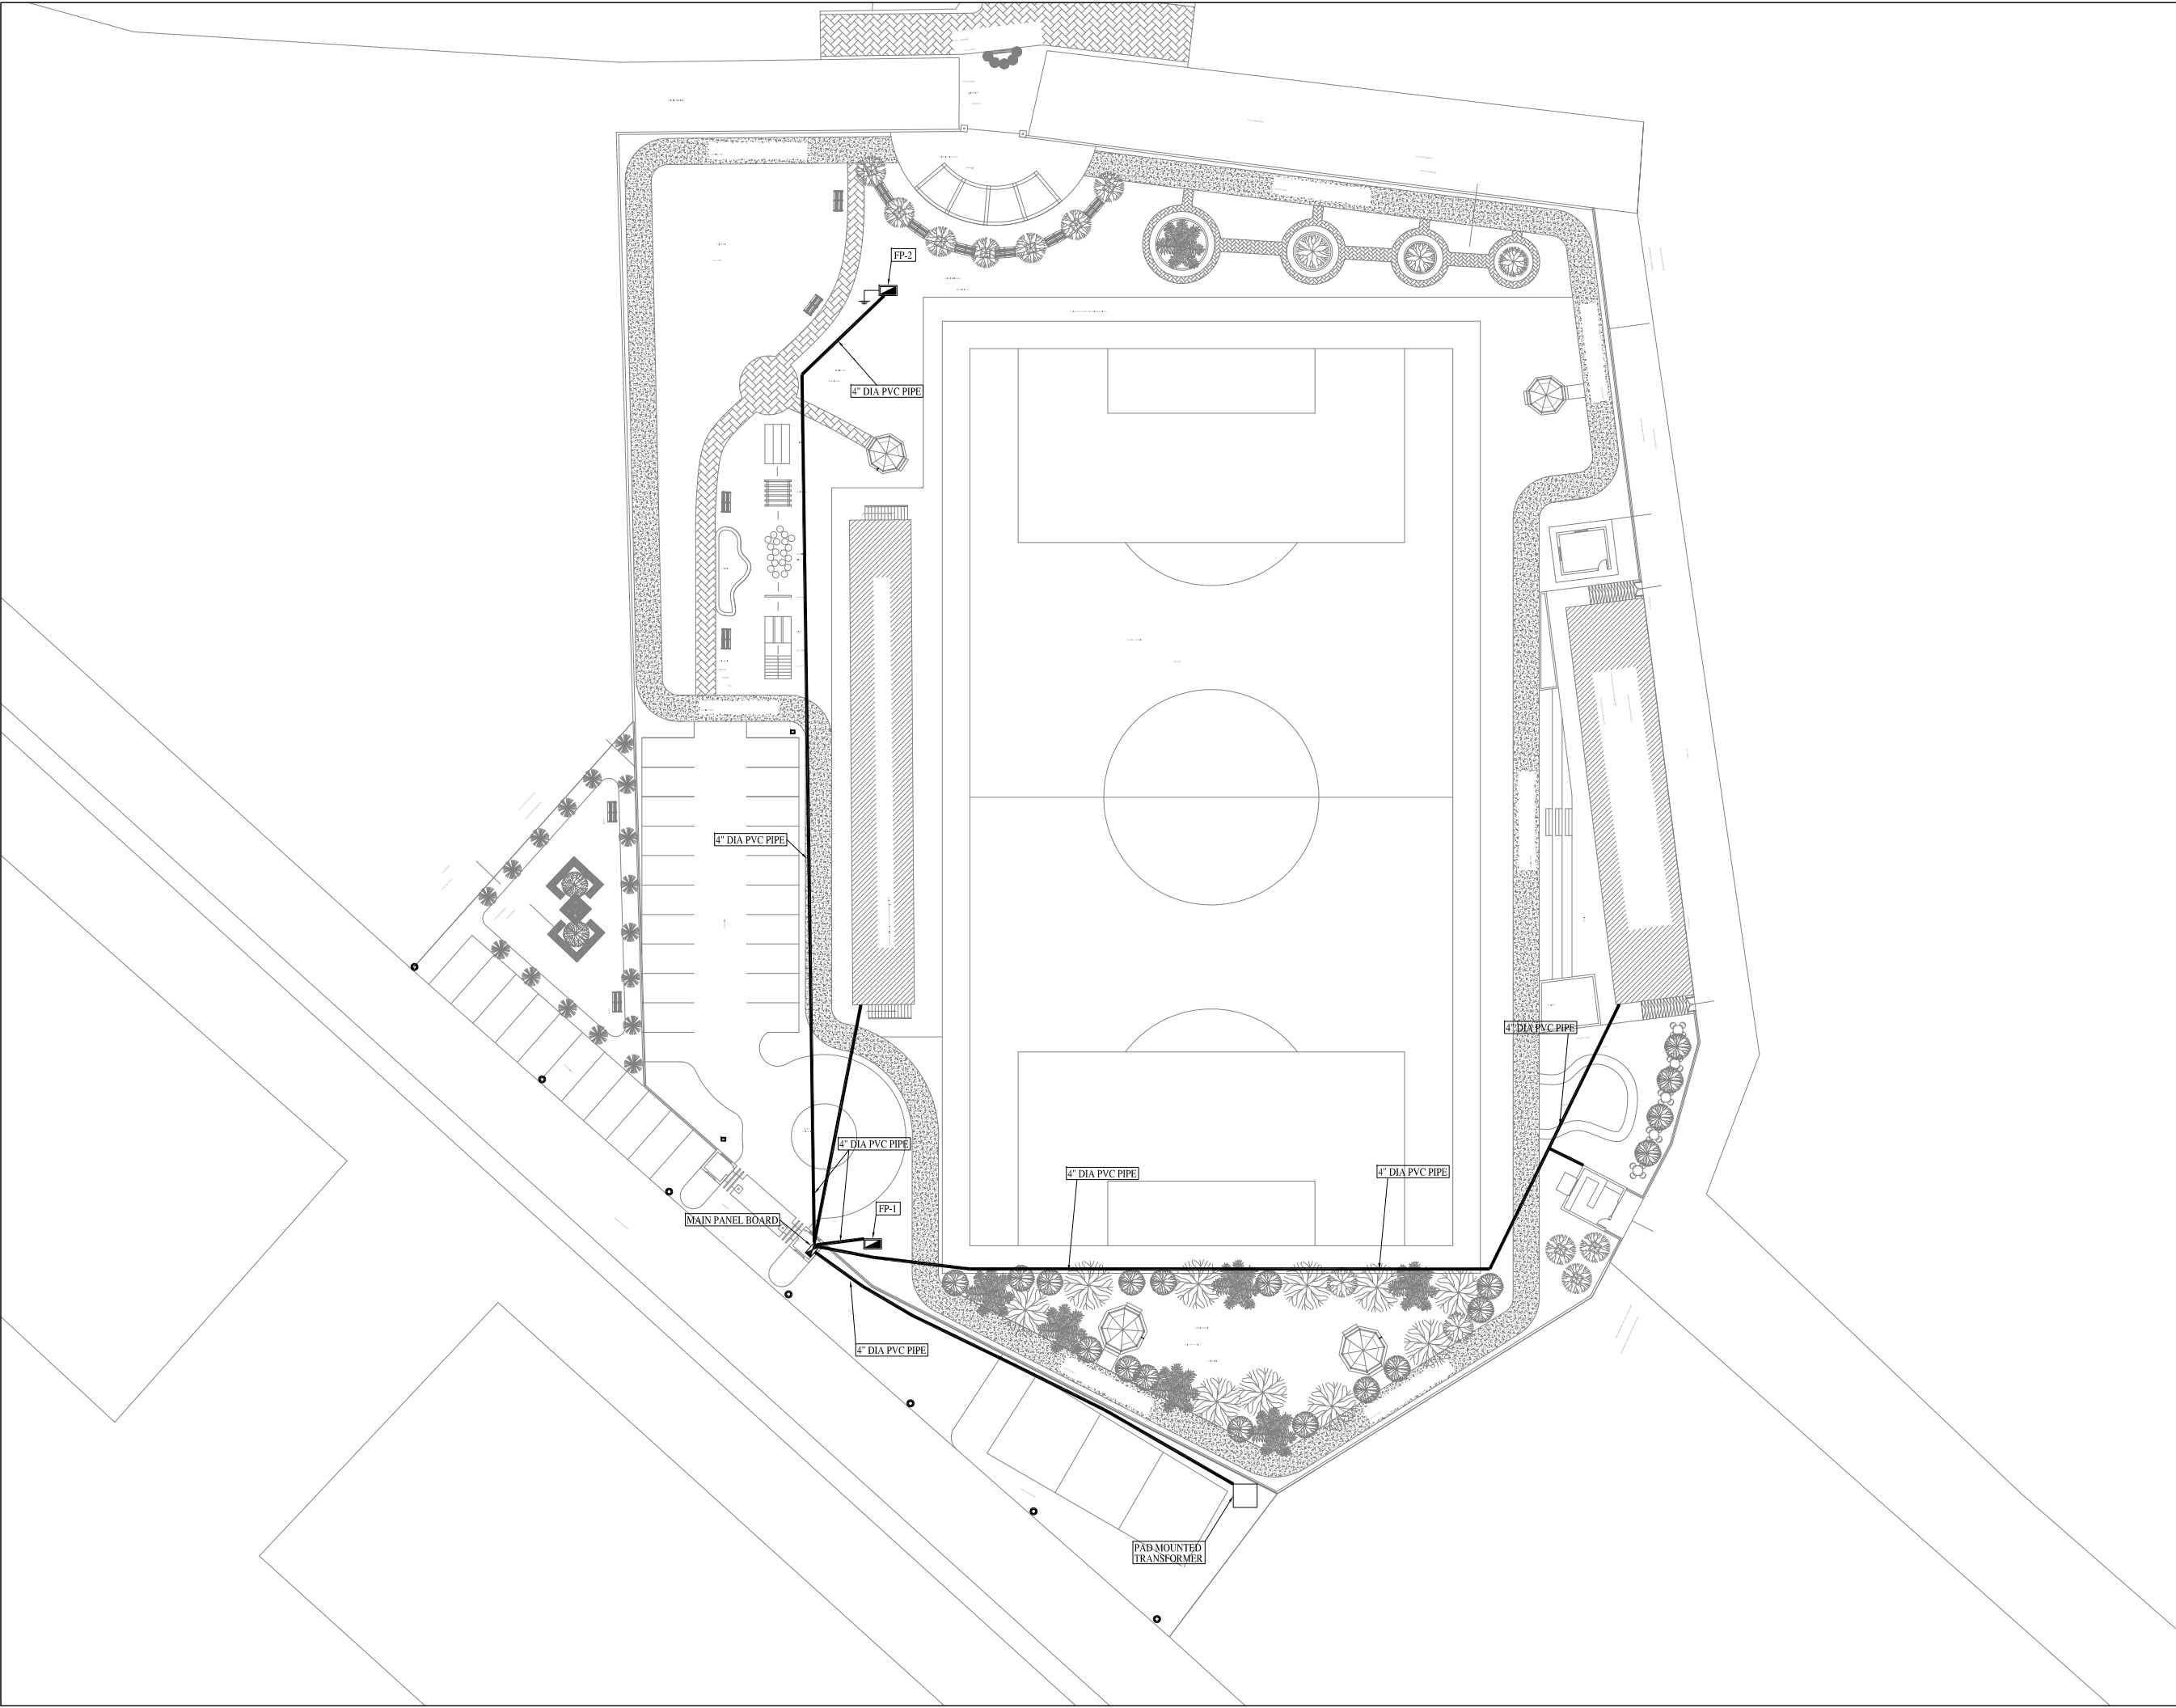

CLIENT:



 PROJECT
IMPLEMENTATION
UNIT (PIU) KNIP



CONSULTANTS:

**G3 ENGINEERING
CONSULTANTS (PVT.) LTD.**
House No.57-M Gulberg-II, Lahore, Pakistan

Tel : (92-42) 35441641, 35441642
Fax : (92-42) 35441645
E-mail : Info@g3ec.com
URL : www.g3ec.com

PROJECT:

REHABILITATION & UP GRADATION
OF GIZRI SPORTS GROUND

NOTES:

1. ALL DIMENSIONS ARE IN FEET UNLESS OTHERWISE SPECIFIED.
2. THIS DRAWING IS AN INTELLECTUAL PROPERTY OF G3 ENGINEERING CONSULTANTS (PVT.) LTD. AND CANNOT BE REPRINTED OR REPRODUCED WITHOUT PRIOR APPROVAL OF G3.

REVISIONS:

No.	DESCRIPTION	DATE

TENDER DRAWINGS

DRAWING TITLE:

POWER DISTRIBUTION
LAYOUT PLAN

DRAWN BY:

M.RAFFEH

DATE:

Aug 2021

ELECTRICAL ENGINEER:

Engr. Ghulam Daraz Shaikh

APPROVED BY:

Engr. SAYED ALI ABBAS GILLANI

DRAWING NO:

0249/PG/03

REV:


4

SCALE (A3):

N.T.S

SHEET:

3/11

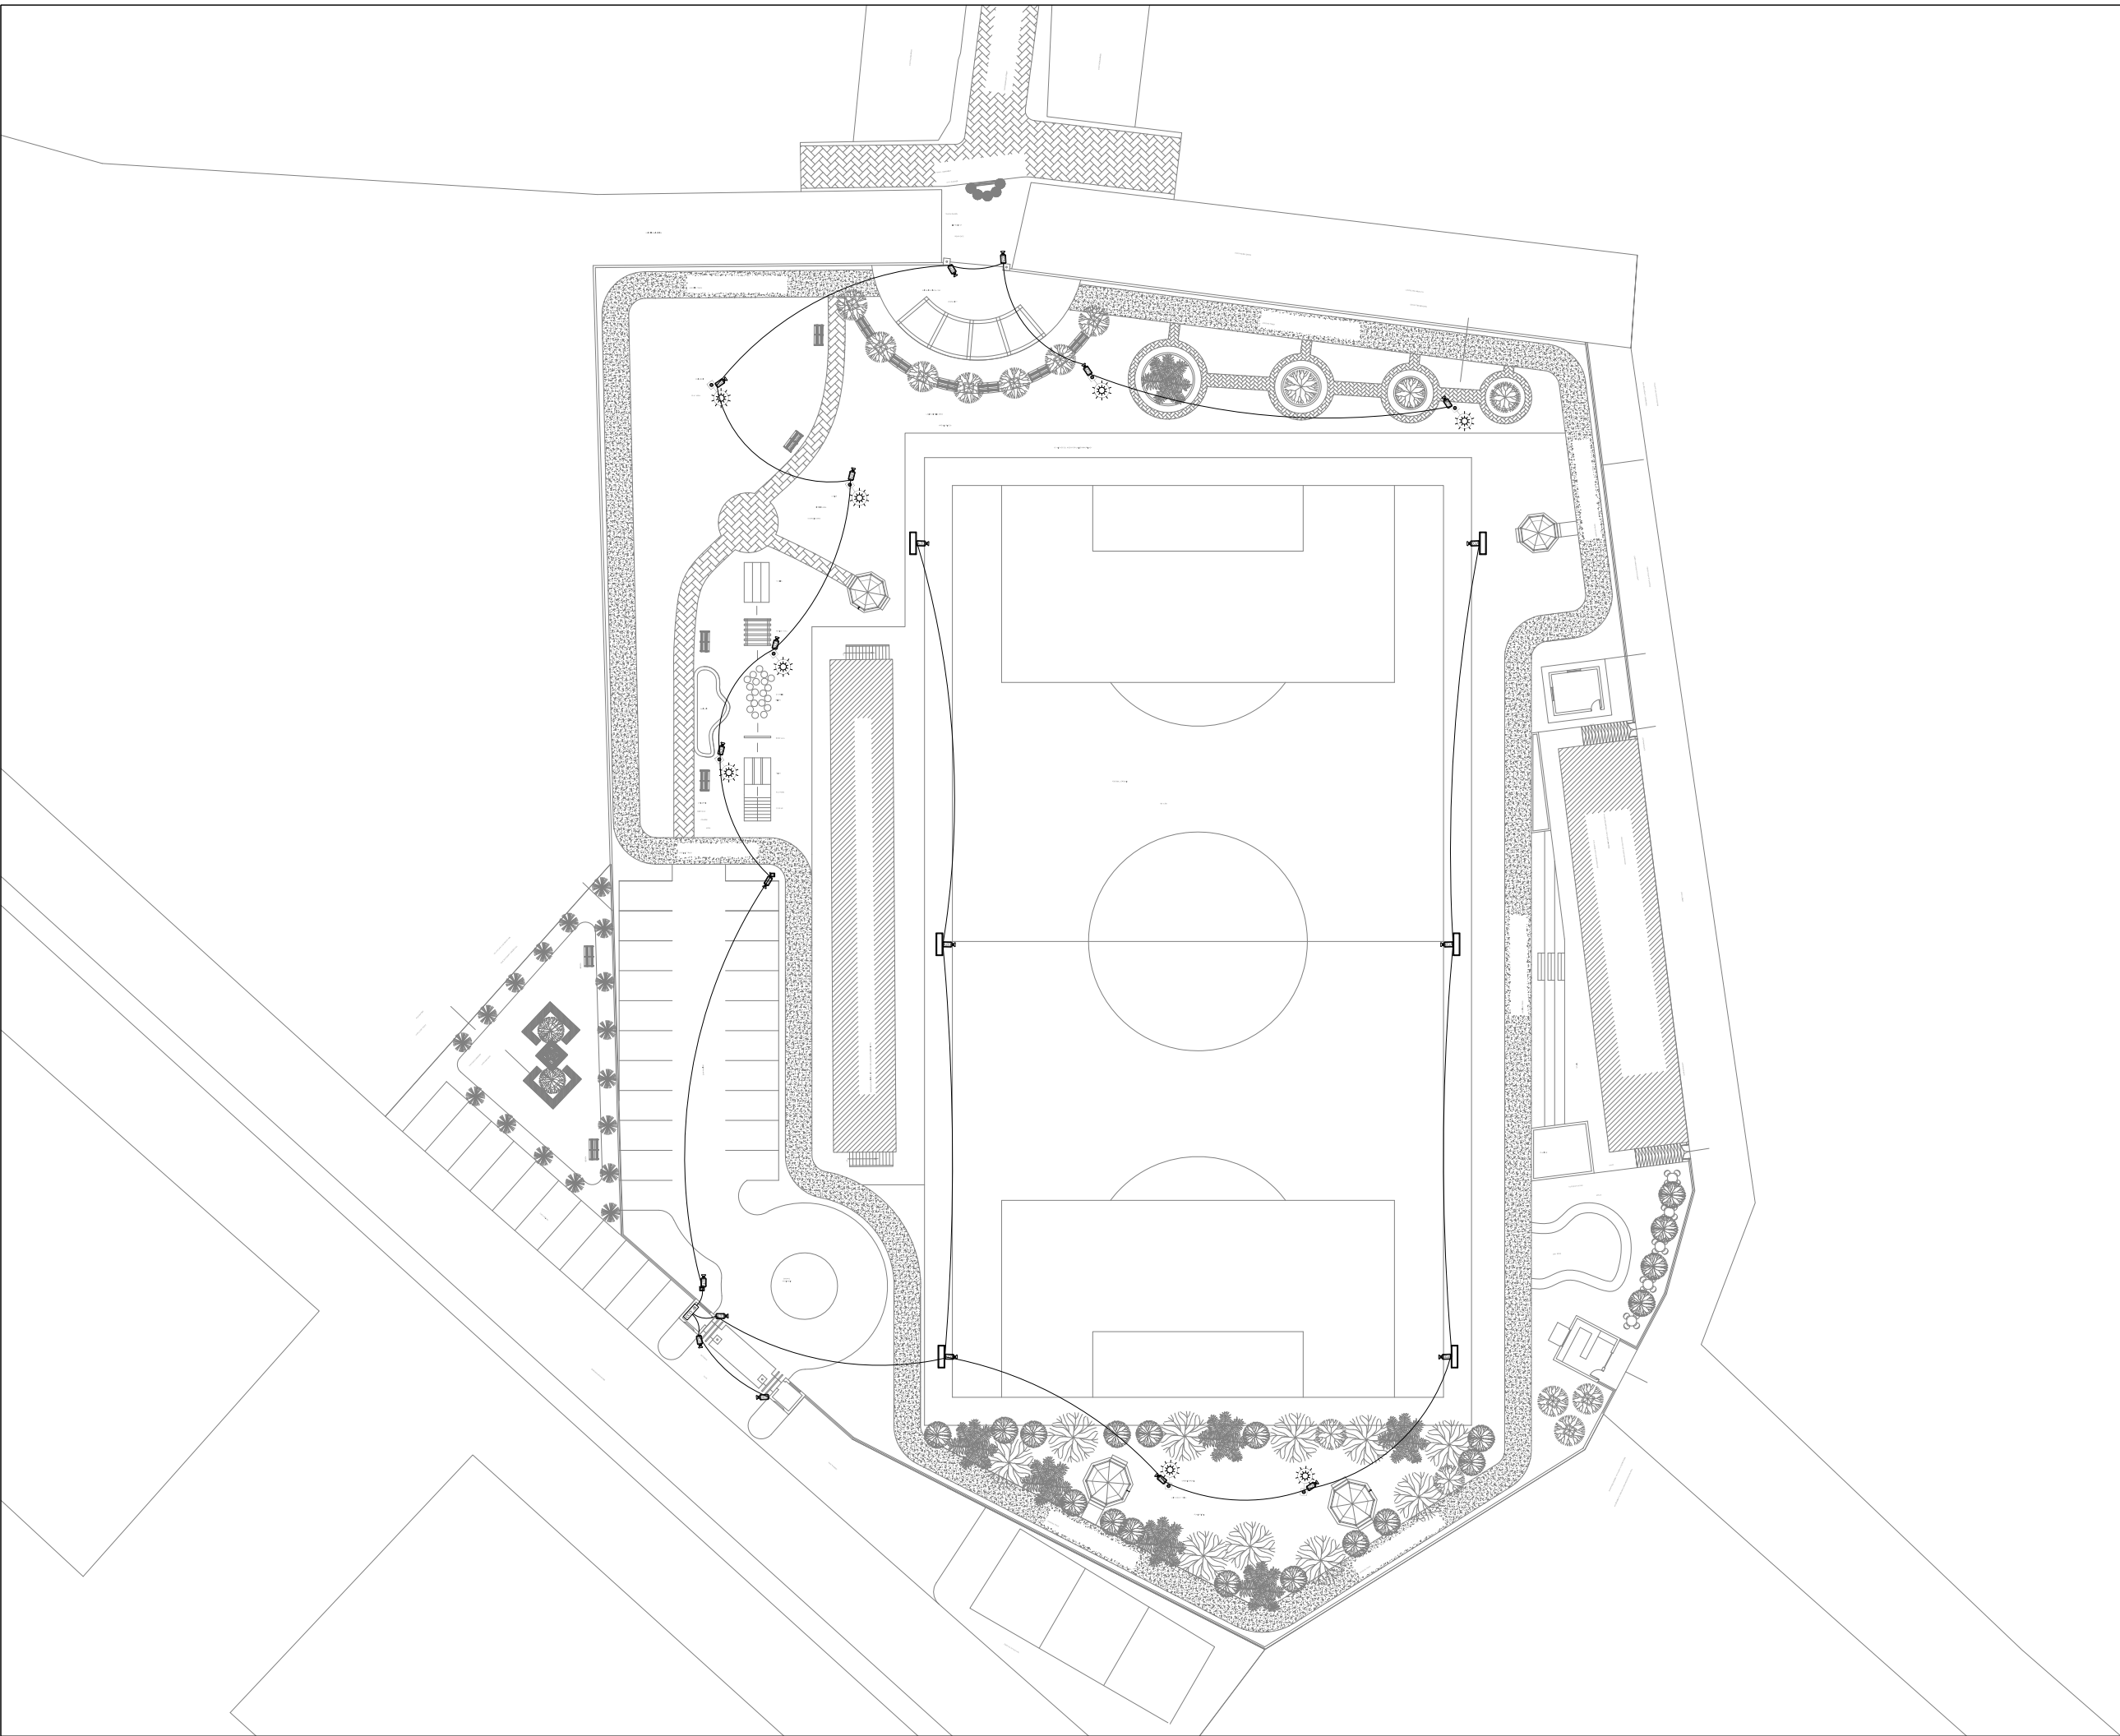

CLIENT:



CONSULTANTS:
G3 ENGINEERING CONSULTANTS (PVT) LTD.
House No.57-M Gulberg-II, Lahore, Pakistan
Tel : (92-42) 35441641, 35441642
Fax : (92-42) 35441645
E-mail : Info@g3ec.com
URL : www.g3ec.com

PROJECT:

REHABILITATION & UP GRADATION
OF GIZRI SPORTS GROUND

- NOTES:
1. ALL DIMENSIONS ARE IN FEET UNLESS OTHERWISE SPECIFIED.
 2. THIS DRAWING IS AN INTELLECTUAL PROPERTY OF G3 ENGINEERING CONSULTANTS (PVT.) LTD. AND CANNOT BE REPRINTED OR REPRODUCED WITHOUT PRIOR APPROVAL OF G3.

REVISIONS:


No.	DESCRIPTION	DATE

TENDER DRAWINGS

DRAWING TITLE:

CCTV LAYOUT PLAN


DRAWN BY: M.RAFFEH	DATE: Aug 2021
ELECTRICAL ENGINEER: Engr. Ghulam Daraz Shaikh	
APPROVED BY: Engr. SAYED ALI ABBAS GILLANI	
DRAWING NO: 0249/PG/04	REV: 4
SCALE (A3): N.T.S	SHEET: 4/11

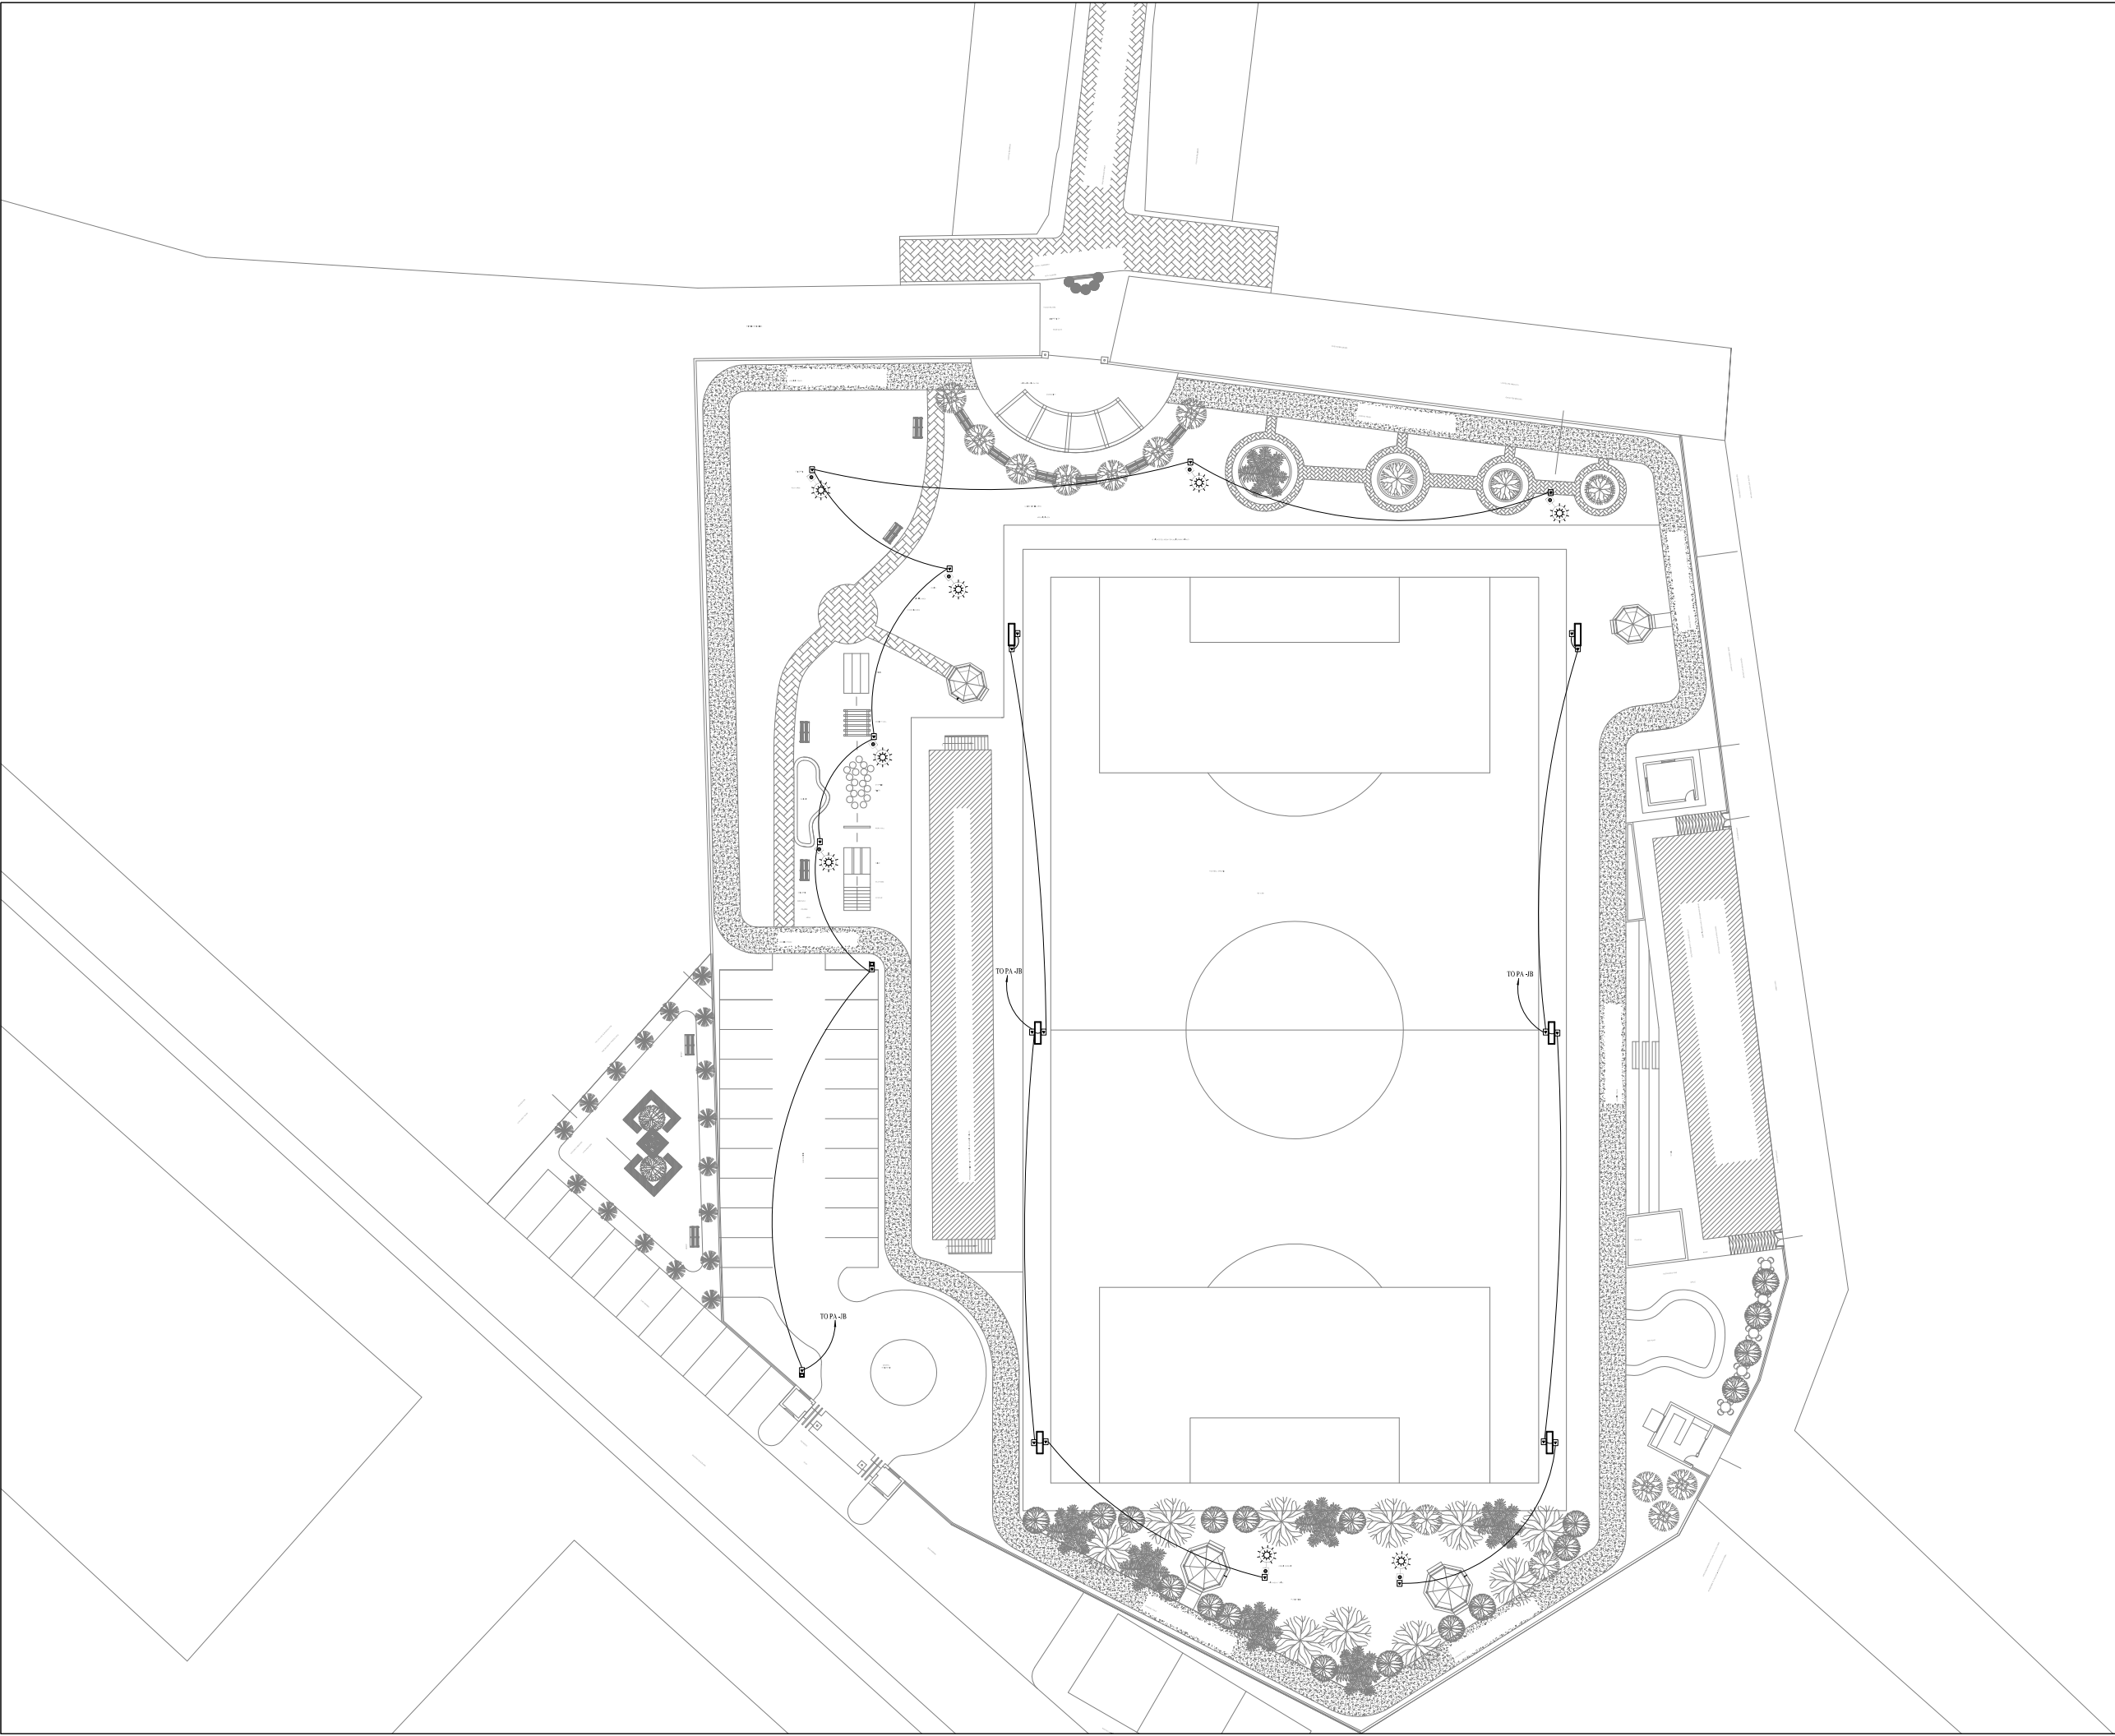

CLIENT:



 PROJECT
IMPLEMENTATION
UNIT (PIU) KNIP



CONSULTANTS:
**G3 ENGINEERING
CONSULTANTS (PVT.) LTD.**
House No.57-M Gulberg-II, Lahore, Pakistan
Tel : (92-42) 35441641, 35441642
Fax : (92-42) 35441645
E-mail : Info@g3ec.com
URL : www.g3ec.com

PROJECT:

REHABILITATION & UP GRADATION
OF GIZRI SPORTS GROUND

NOTES:
1. ALL DIMENSIONS ARE IN FEET UNLESS
OTHERWISE SPECIFIED.
2. THIS DRAWING IS AN INTELLECTUAL PROPERTY
OF G3 ENGINEERING CONSULTANTS (PVT.) LTD.
AND CANNOT BE REPRINTED OR REPRODUCED
WITHOUT PRIOR APPROVAL OF G3.

REVISIONS:

No.	DESCRIPTION	DATE

TENDER DRAWINGS

DRAWING TITLE:

PUBLIC ADDRESS
SYSTEM PLAN

DRAWN BY: M.RAFFEH	DATE: Aug 2021
ELECTRICAL ENGINEER: Engr. Ghulam Daraz Shaikh	
APPROVED BY: Engr. SAYED ALI ABBAS GILLANI	
DRAWING NO: 0249/PG/05	REV: 4
SCALE (A3): N.T.S	SHEET: 5/11

CLIENT:



CONSULTANTS:
G3 ENGINEERING CONSULTANTS (PVT) LTD.
House No.57-M Gulberg-II, Lahore, Pakistan

Tel : (92-42) 35441641, 35441642
Fax : (92-42) 35441645
E-mail : Info@g3ec.com
URL : www.g3ec.com

PROJECT:

REHABILITATION & UP GRADATION
OF GIZRI SPORTS GROUND

- NOTES:
1. ALL DIMENSIONS ARE IN FEET UNLESS OTHERWISE SPECIFIED.
 2. THIS DRAWING IS AN INTELLECTUAL PROPERTY OF G3 ENGINEERING CONSULTANTS (PVT.) LTD. AND CANNOT BE REPRINTED OR REPRODUCED WITHOUT PRIOR APPROVAL OF G3.

REVISIONS:


No.	DESCRIPTION	DATE

TENDER DRAWINGS


DRAWING TITLE:

EXISTING PAVILION
ILLUMINATION PLAN

DRAWN BY: M.RAFFEH	DATE: Aug 2021
ELECTRICAL ENGINEER: Engr. Ghulam Daraz Shaikh	
APPROVED BY: Engr. SAYED ALI ABBAS GILLANI	
DRAWING NO: 0249/PG/EP/06	REV: 4
SCALE (A3): N.T.S	SHEET: 6/11

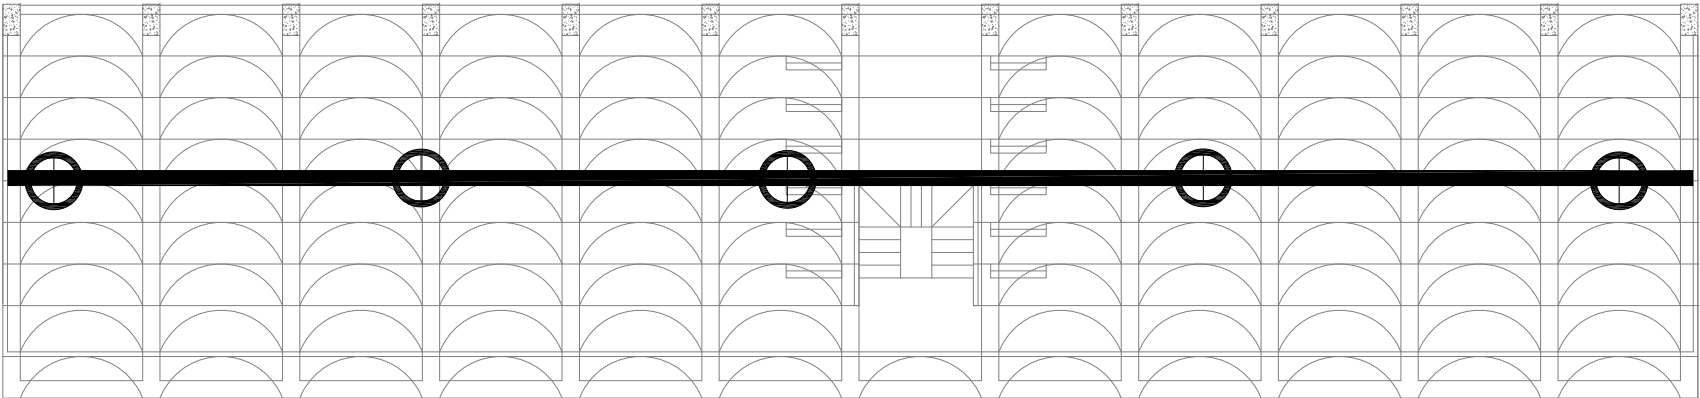

LEVEL-2

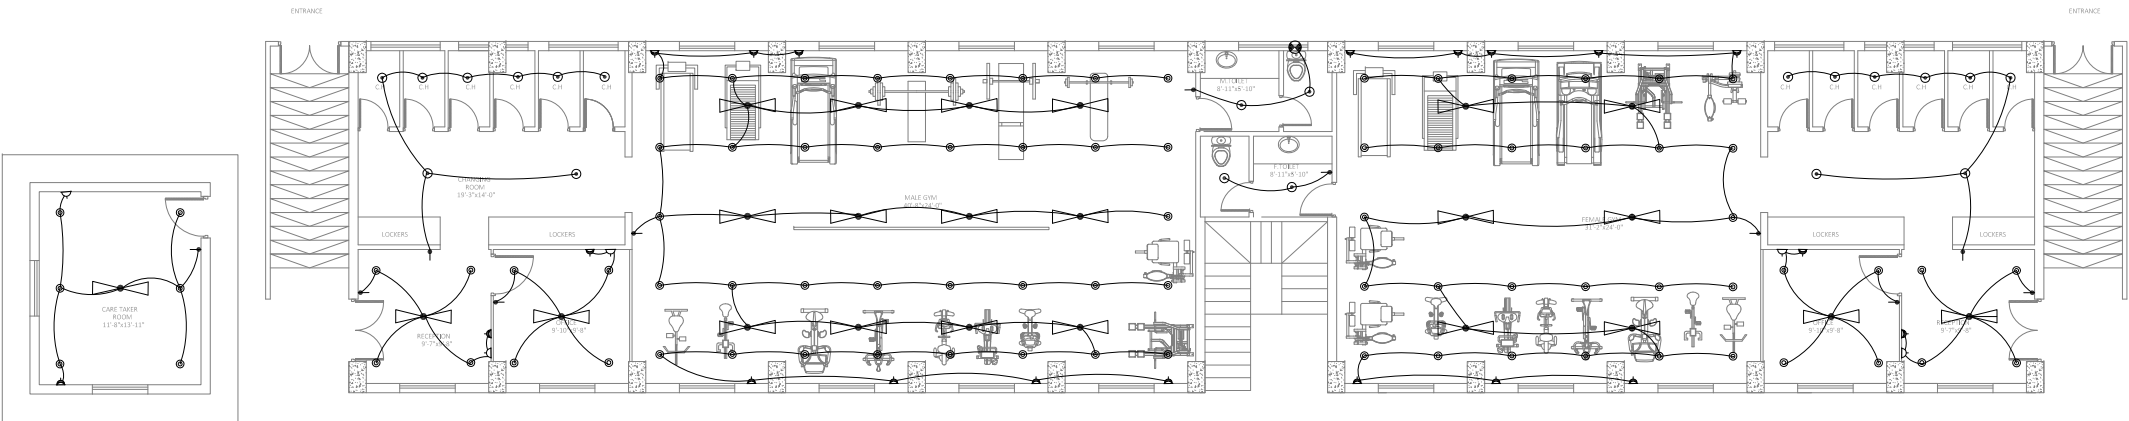


LEVEL-1

PROJECT
IMPLEMENTATION
UNIT (PIU) KNIP



 **G3 ENGINEERING
CONSULTANTS (PVT)LTD.**
House No.57-M Gulberg-III, Lahore, Pakistan



Tel : (92-42) 35441641, 35441642
Fax : (92-42) 35441645
E-mail : Info@g3ec.com
URL : www.g3ec.com

REHABILITATION & UP GRADATION OF GIZRI SPORTS GROUND



1. ALL DIMENSIONS ARE IN FEET UNLESS OTHERWISE SPECIFIED.
2. THIS DRAWING IS AN INTELLECTUAL PROPERTY OF G3 ENGINEERING CONSULTANTS (PVT.) LTD. AND CANNOT BE REPRINTED OR REPRODUCED WITHOUT PRIOR APPROVAL OF G3.


[illegible]

PROPOSED PAVILION ILLUMINATION PLAN

APPROVED BY:
Engr. SAYED ALI ABBAS GILLANI

SCALE (A3): N.T.S	SHEET: 7/11
----------------------	----------------

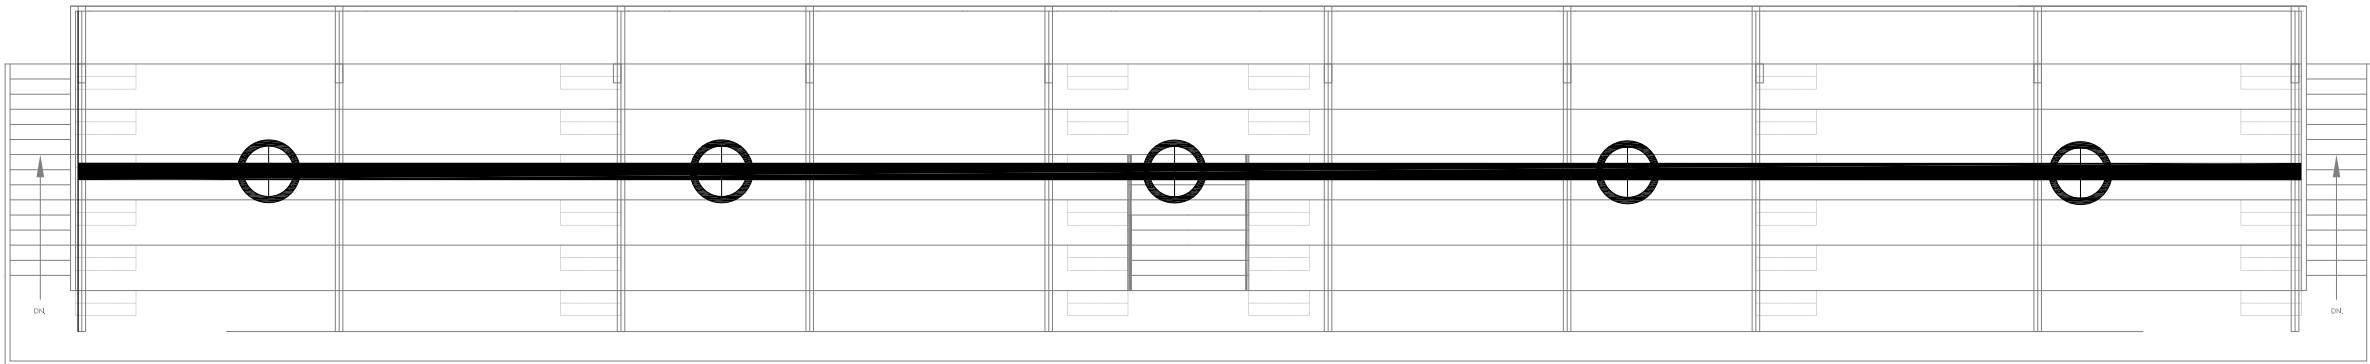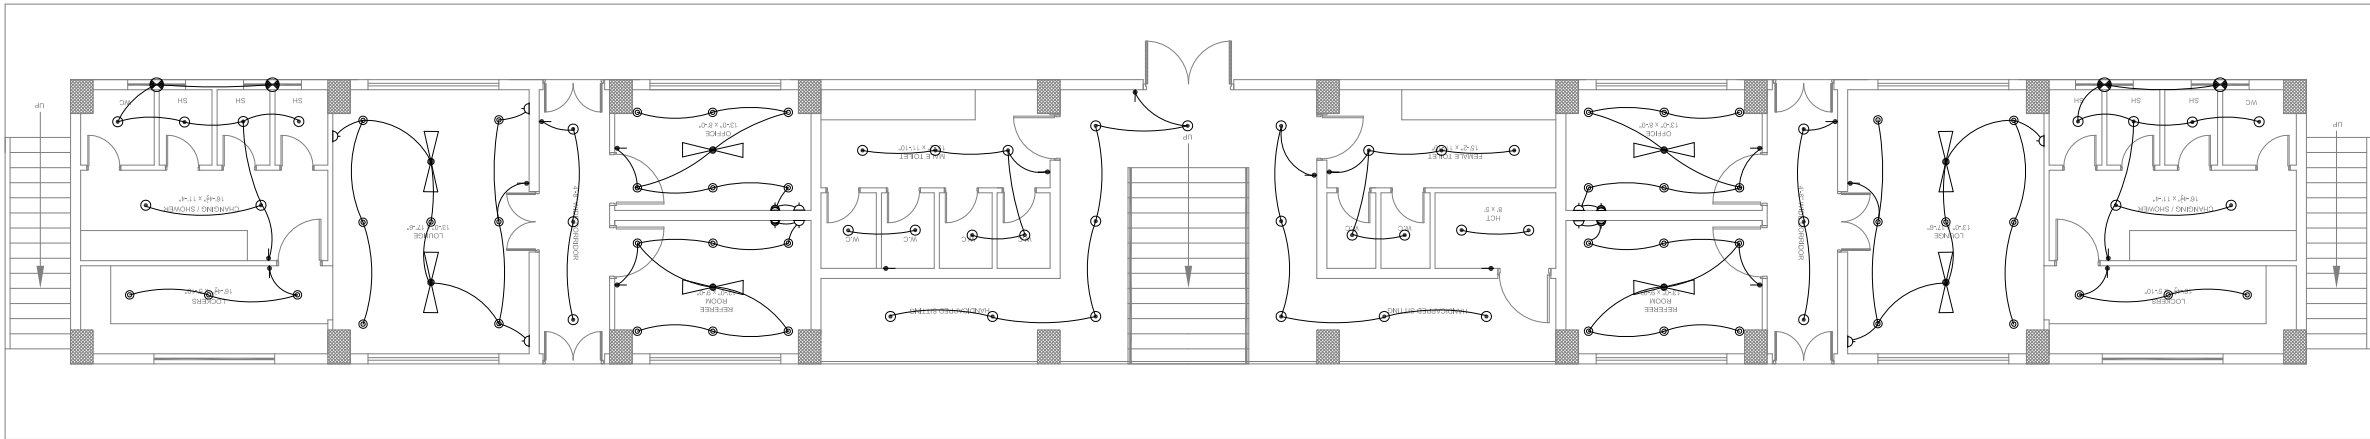

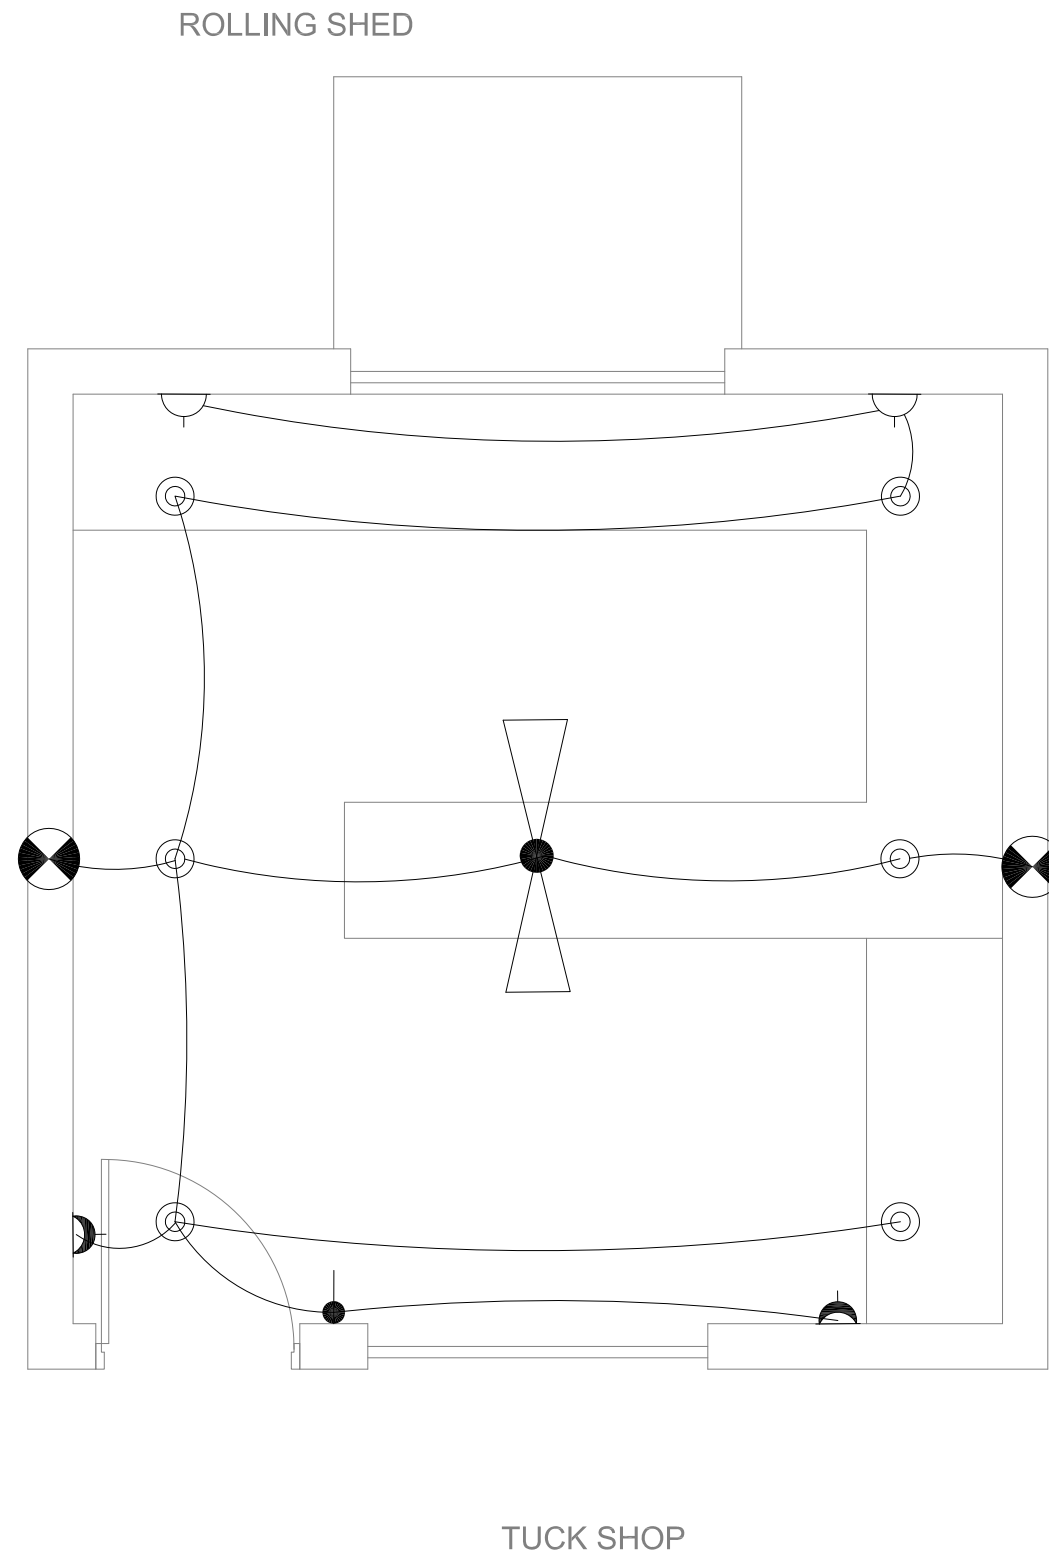

CLIENT:



CONSULTANTS:
G3 ENGINEERING CONSULTANTS (PVT) LTD.
House No.57-M Gulberg-II, Lahore, Pakistan
Tel : (92-42) 35441641, 35441642
Fax : (92-42) 35441645
E-mail : Info@g3ec.com
URL : www.g3ec.com

PROJECT:

REHABILITATION & UP GRADATION
OF GIZRI SPORTS GROUND

NOTES:
1. ALL DIMENSIONS ARE IN FEET UNLESS OTHERWISE SPECIFIED.
2. THIS DRAWING IS AN INTELLECTUAL PROPERTY OF G3 ENGINEERING CONSULTANTS (PVT.) LTD. AND CANNOT BE REPRINTED OR REPRODUCED WITHOUT PRIOR APPROVAL OF G3.

REVISIONS:

No.	DESCRIPTION	DATE


TENDER DRAWINGS

DRAWING TITLE:
**TUCK SHOP
ILLUMINATION
LAYOUT PLAN**

DRAWN BY: M.RAFFEH	DATE: Aug 2021
ELECTRICAL ENGINEER: Engr. Ghulam Daraz Shaikh	
APPROVED BY: Engr. SAYED ALI ABBAS GILLANI	
DRAWING NO: 0249/PG/SH/08	REV: 4
SCALE (A3): N.T.S	SHEET: 8/11



 PROJECT
IMPLEMENTATION
UNIT (PIU) KNIP



CONSULTANTS:

**G3 ENGINEERING
CONSULTANTS (PVT.) LTD.**
House No.57-M Gulberg-II, Lahore, Pakistan

Tel : (92-42) 35441641, 35441642
Fax : (92-42) 35441645
E-mail : Info@g3ec.com
URL : www.g3ec.com

PROJECT:

**REHABILITATION & UP GRADATION
OF GIZRI SPORTS GROUND**

NOTES:

1. ALL DIMENSIONS ARE IN FEET UNLESS OTHERWISE SPECIFIED.
2. THIS DRAWING IS AN INTELLECTUAL PROPERTY OF G3 ENGINEERING CONSULTANTS (PVT.) LTD. AND CANNOT BE REPRINTED OR REPRODUCED WITHOUT PRIOR APPROVAL OF G3.

REVISIONS:

No.	DESCRIPTION	DATE

TENDER DRAWINGS

DRAWING TITLE:

**ENTRANCE GATE
PLAY GROUND**

DRAWN BY:

M.RAFFEH

DATE:

Aug 2021

ELECTRICAL ENGINEER:

Engr. Ghulam Daraz Shaikh

APPROVED BY:

Engr. SAYED ALI ABBAS GILLANI

DRAWING NO:

0249/PG/EG/09

REV:



4

 

SCALE (A3):

N.T.S

SHEET:

9/11

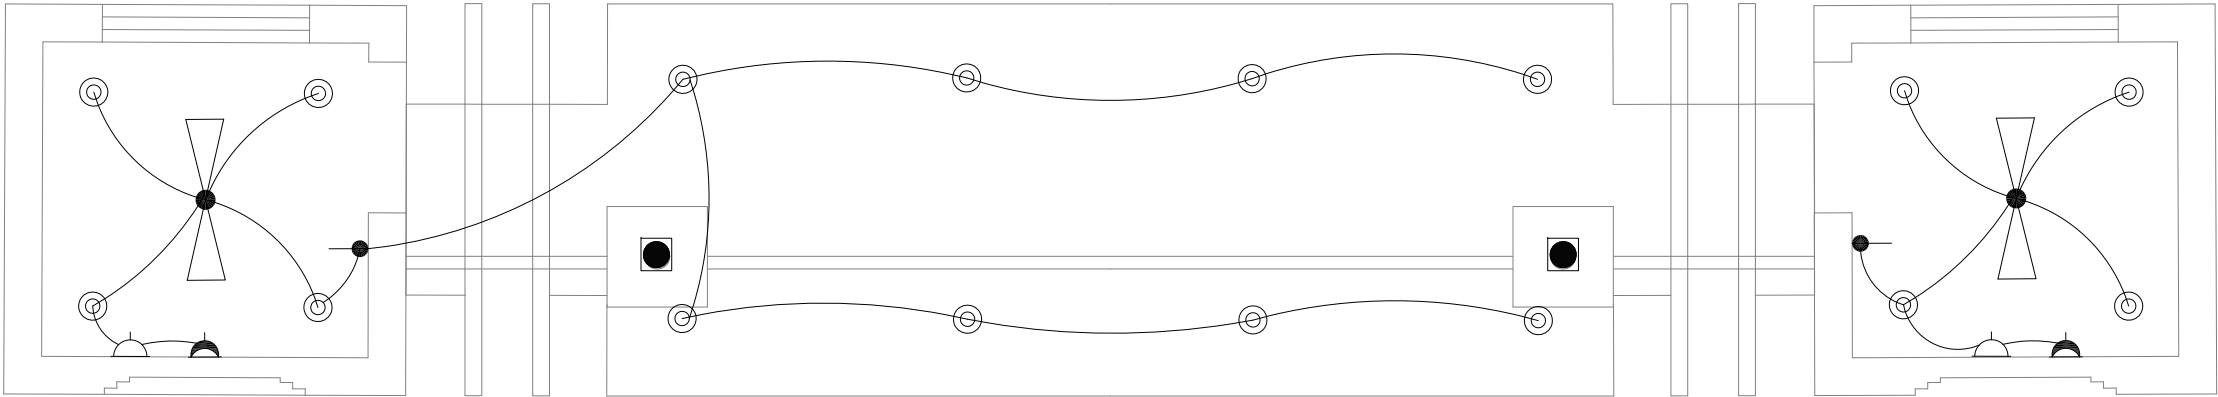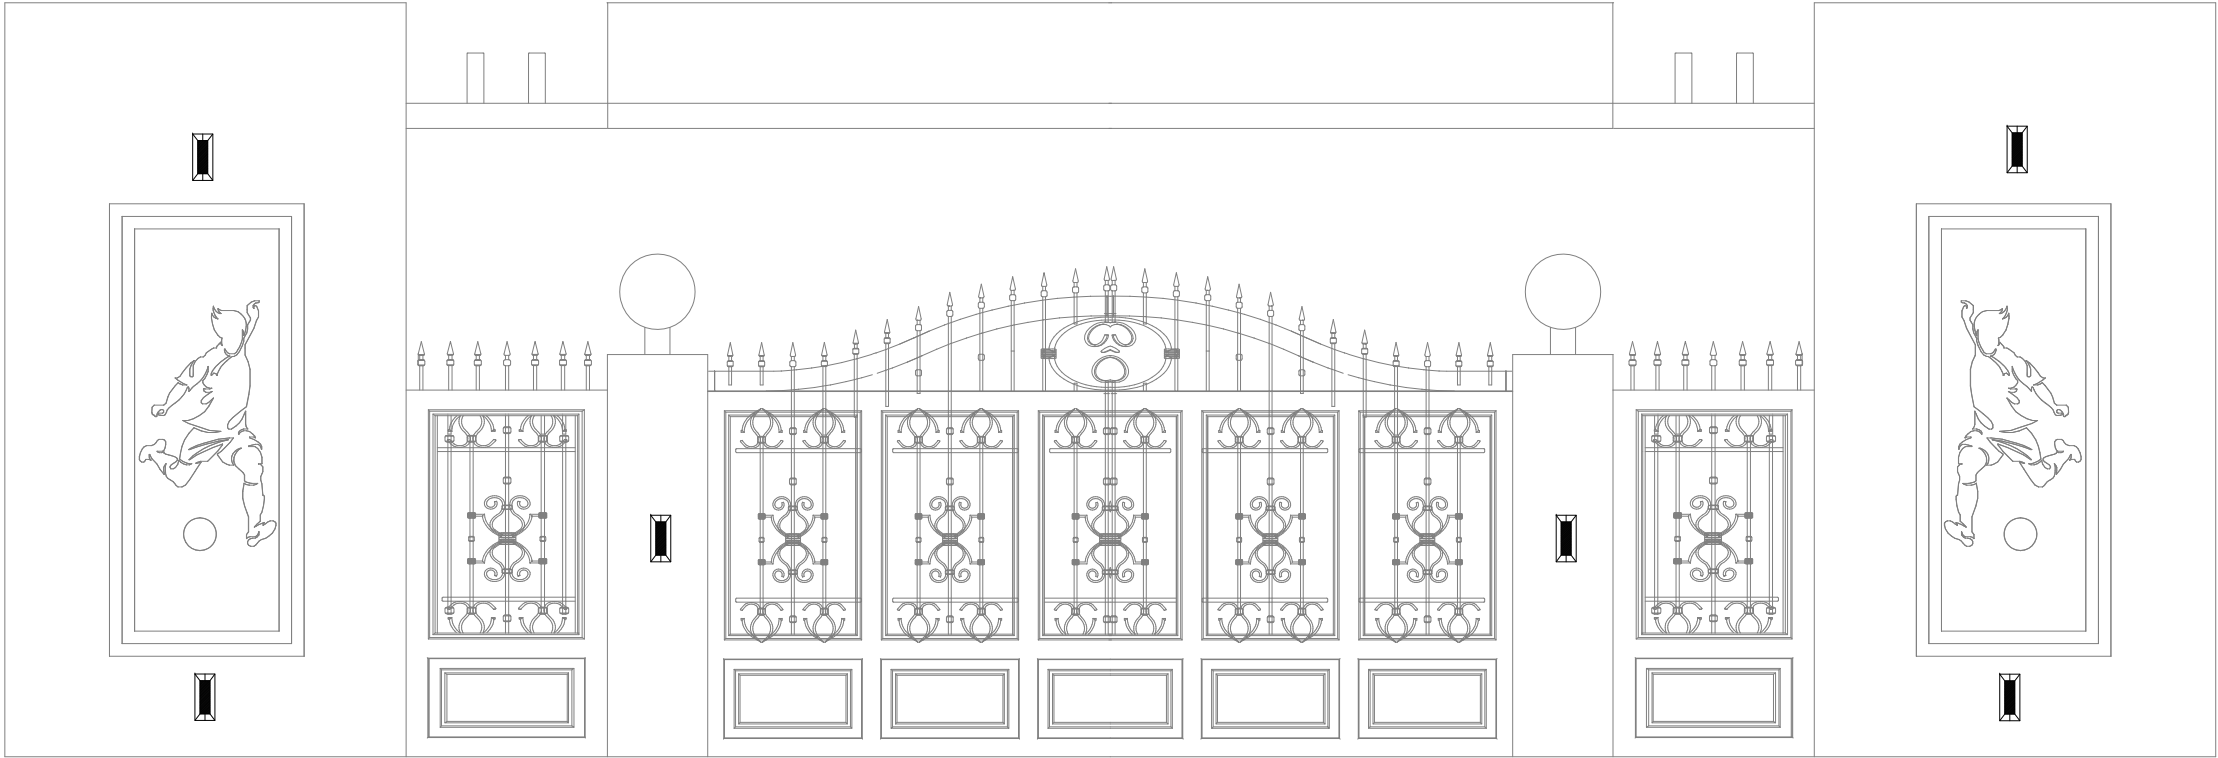

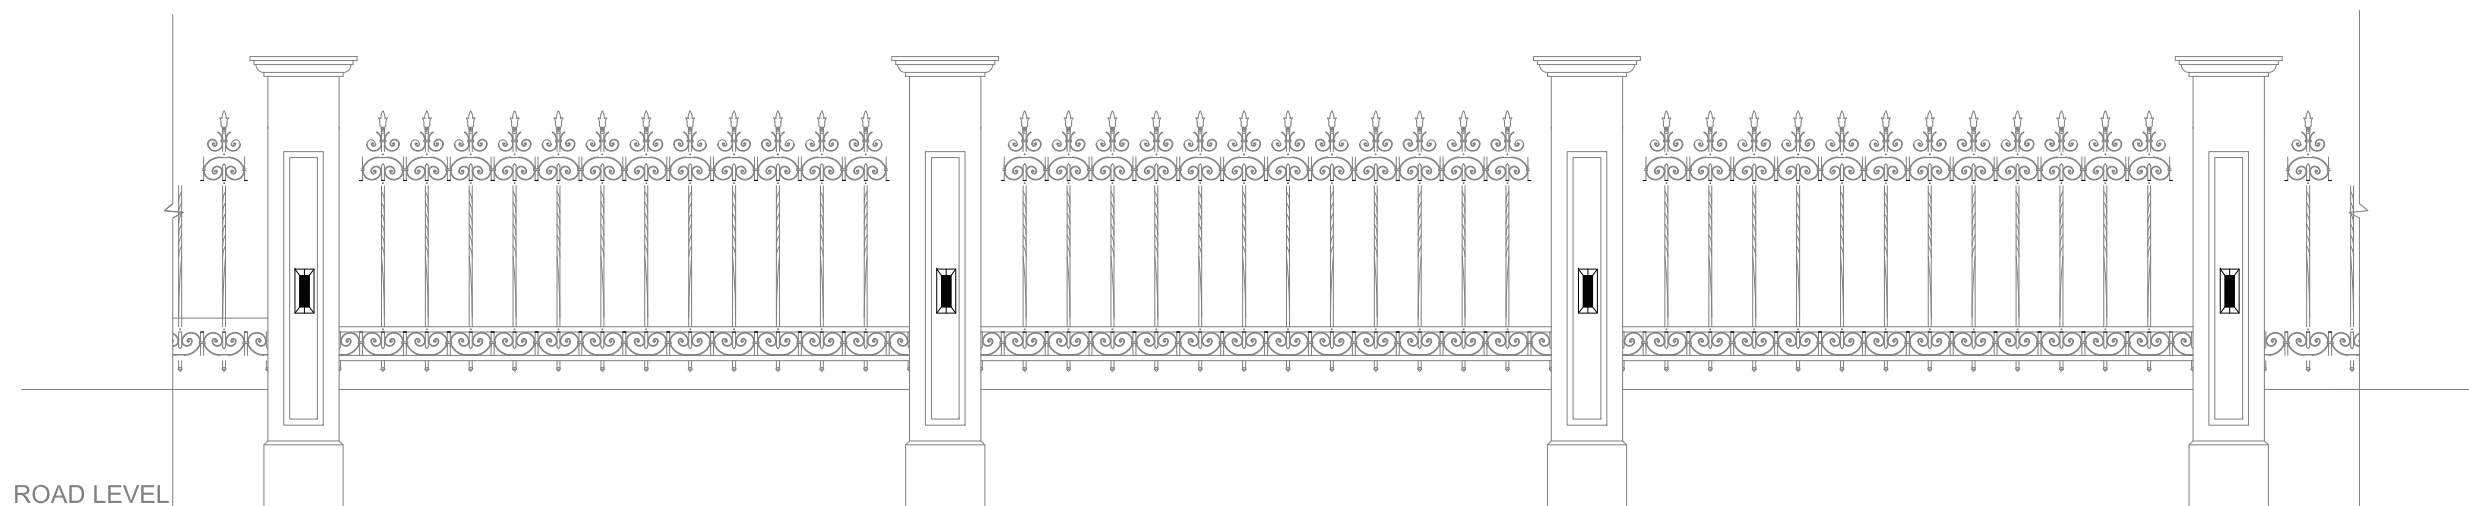

CLIENT:



PROJECT
IMPLEMENTATION
UNIT (PIU) KNIP



CONSULTANTS:

**G3 ENGINEERING
CONSULTANTS (PVT.) LTD.**
House No.57-M Gulberg-II, Lahore, Pakistan

Tel : (92-42) 35441641, 35441642
Fax : (92-42) 35441645
E-mail : Info@g3ec.com
URL : www.g3ec.com

PROJECT:

REHABILITATION & UP GRADATION
OF GIZRI SPORTS GROUND

NOTES:

1. ALL DIMENSIONS ARE IN FEET UNLESS OTHERWISE SPECIFIED.
2. THIS DRAWING IS AN INTELLECTUAL PROPERTY OF G3 ENGINEERING CONSULTANTS (PVT.) LTD. AND CANNOT BE REPRINTED OR REPRODUCED WITHOUT PRIOR APPROVAL OF G3.

REVISIONS:

No.	DESCRIPTION	DATE

TENDER DRAWINGS

DRAWING TITLE:

BOUNDARY WALL
PLAY GROUND

DRAWN BY:

M.RAFFEH

DATE:

Aug 2021

ELECTRICAL ENGINEER:

Engr. Ghulam Daraz Shaikh

APPROVED BY:

Engr. SAYED ALI ABBAS GILLANI

DRAWING NO:

0249/PG/BW/10

REV:



4

SCALE (A3):

N.T.S

SHEET:

10/11

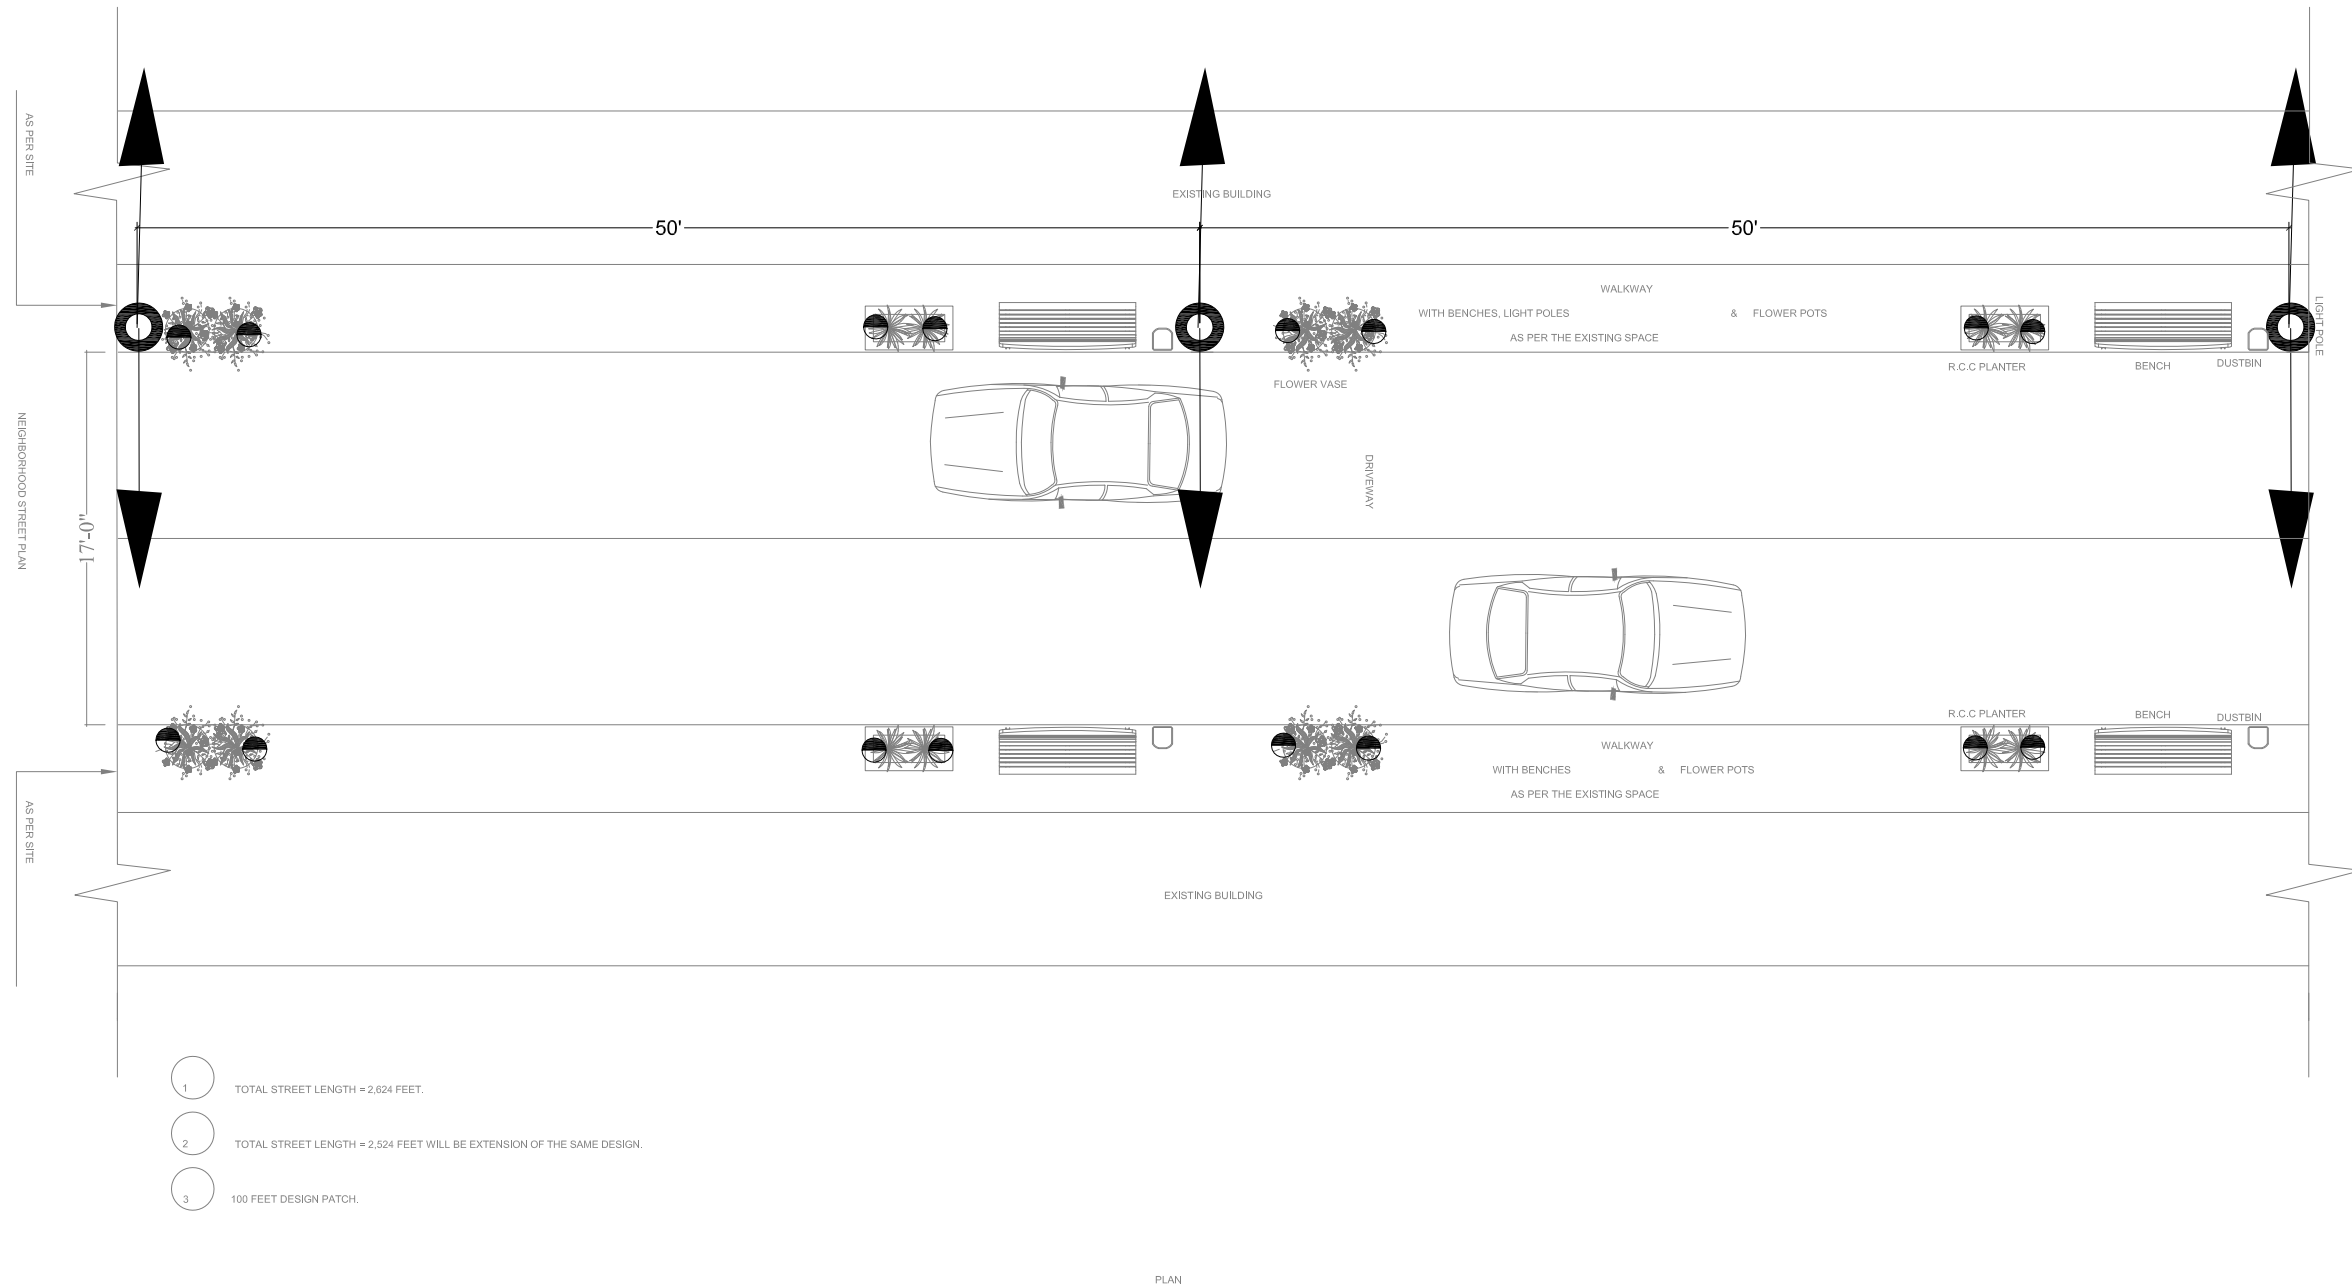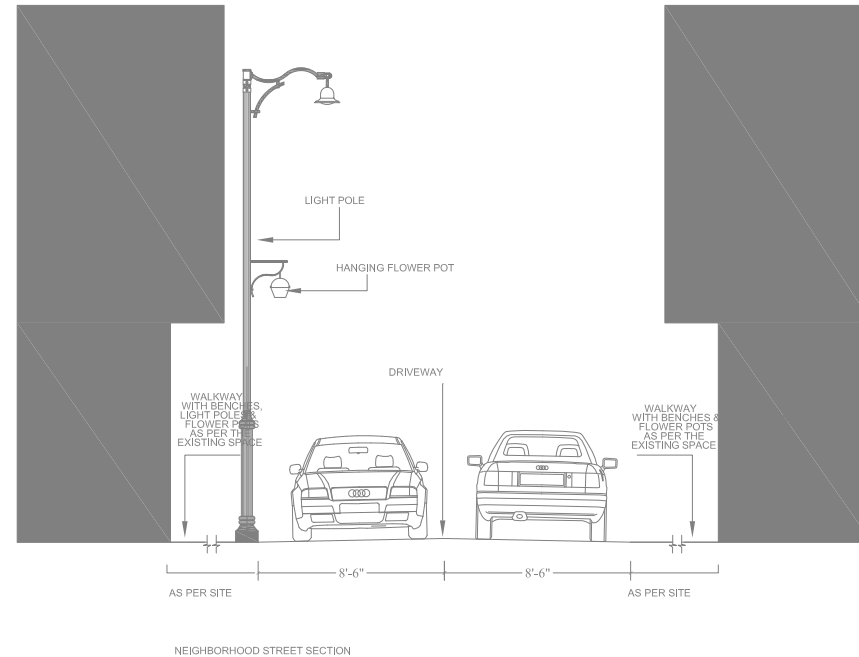

- 1 TOTAL STREET LENGTH = 2,624 FEET.
- 2 TOTAL STREET LENGTH = 2,524 FEET WILL BE EXTENSION OF THE SAME DESIGN.
- 3 100 FEET DESIGN PATCH.

CLIENT:



CONSULTANTS:

G3 ENGINEERING CONSULTANTS (PVT) LTD.
House No.57-M Gulberg-II, Lahore, Pakistan

Tel : (92-42) 35441641, 35441642
Fax : (92-42) 35441645
E-mail : Info@g3ec.com
URL : www.g3ec.com

PROJECT:

REHABILITATION & UP GRADATION OF GIZRI SPORTS GROUND

- NOTES:**
1. ALL DIMENSIONS ARE IN FEET UNLESS OTHERWISE SPECIFIED.
 2. THIS DRAWING IS AN INTELLECTUAL PROPERTY OF G3 ENGINEERING CONSULTANTS (PVT.) LTD. AND CANNOT BE REPRINTED OR REPRODUCED WITHOUT PRIOR APPROVAL OF G3.

REVISIONS:		
No.	DESCRIPTION	DATE

TENDER DRAWINGS


DRAWING TITLE:	
STREET POLE LAYOUT PLAN	
DRAWN BY: M.RAFFEH	DATE: Aug 2021
ELECTRICAL ENGINEER: Engr. Ghulam Daraz Shaikh	
APPROVED BY: Engr. SAYED ALI ABBAS GILLANI	
DRAWING NO: 0249/PG/SP/11	REV: 4
SCALE (A3): N.T.S	SHEET: 11/11



**G3 ENGINEERING
CONSULTANTS (PVT)LTD.**
House No.57-M Gulberg-III, Lahore, Pakistan

[illegible]

DRAWN BY: M.RAFFEH		DATE: Aug 2021	
ELECTRICAL ENGINEER: Engr. Ghulam Daraz Shaikh			
APPROVED BY: Engr. SAYED ALI ABBAS GILLANI			
DRAWING NO: 0249/PG/SLD/12		REV: 4	
SCALE (A3): N.T.S		SHEET: 11/11	

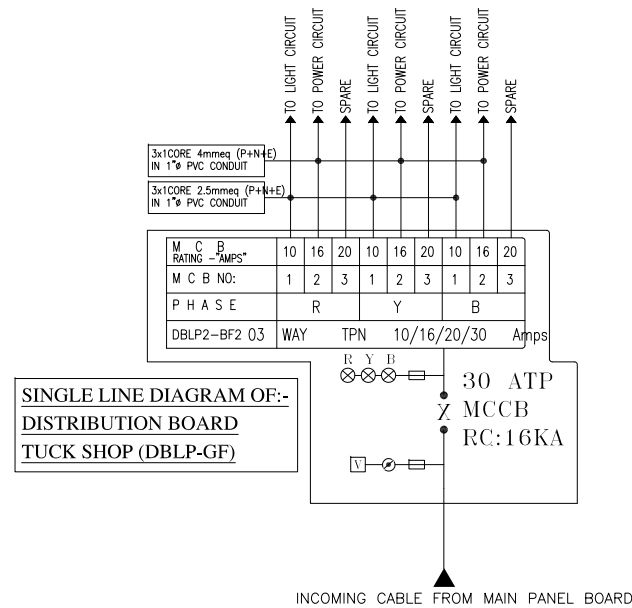

[illegible]

DRAWN BY: M.RAFFEH		DATE: Aug 2021	
ELECTRICAL ENGINEER: Engr. Ghulam Daraz Shaikh			
APPROVED BY: Engr. SAYED ALI ABBAS GILLANI			
DRAWING NO: 0249/PG/SLD/13		REV: 4	
SCALE (A3): N.T.S		SHEET: 11/11	

